


1" = 40'-0" HORIZONTAL
200 FEET
0 40
0 8 10
1" = 4'-0" VERTICAL
2 1.8.2026 TJC RJS/NRB WELDED ACCESS TEE DETAIL REFERENCE
NO. DATE BY CHK'D REVISION

CONTRACT NO. : 6543	FILE NO. : 6543_C-101-C-102
ACCESSION NO. : -----	SECTION NO. : W10
DATE: AUGUST 2025	DESIGNED BY: RJS
	DRAWN BY: TJC
	CHECKED BY: NRB
SCALE: AS NOTED	APPROVED BY: RJS

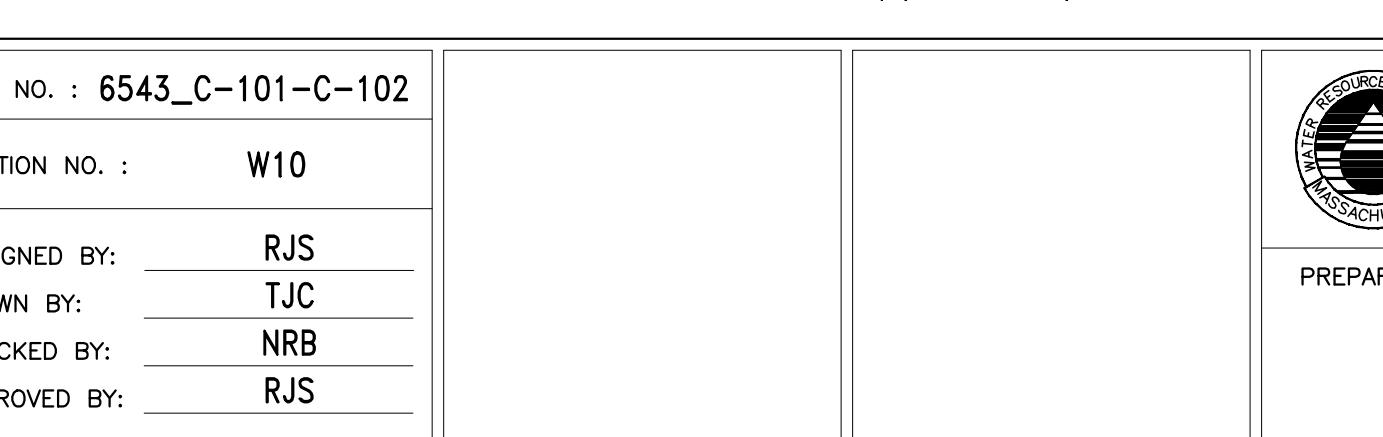

PREPARED BY:

Stantec

45 BLUE SKY DRIVE, 3RD FLOOR
BURLINGTON, MA 01803
www.stantec.com

WESTON AQUEDUCT SUPPLY MAIN 3
REHABILITATION OF WATER MAINS
SECTION W10
SECTION W10 PLAN AND PROFILE STA 110+50
TO STA 121+50

DRAWING NO.
C-101
7 OF 83