

Know what's below.
Call before you dig.
www.cbyd.com



10th Ward Community Center

MILESTONE ROAD

NOBADEER FARM ROAD

North Arrow

NANTUCKET SOUND

DOWNTOWN NANTUCKET

SITE LOCATION

NANTUCKET MEMORIAL AIRPORT

ADD ALTERNATE #4: SPORTS LIGHTING
 PROVIDE AND INSTALL A COMPLETE AND FULLY OPERATIONAL SPORTS LIGHTING SYSTEM, INCLUDING POLES, LUMINAIRES, CROSSARMS, MANUFACTURER-SUPPLIED CONTROL AND MONITORING EQUIPMENT, FOUNDATIONS/FOOTINGS, GROUNDING, SURGE PROTECTION, FIXTURE AIMING, TESTING, COMMISSIONING, OWNER TRAINING, WARRANTIES, AND REQUIRED DARKSKY APPROVALS. ELECTRICAL CONTROL, BRANCH WIRING, AND RELATED INFRASTRUCTURE SPECIFICALLY INDICATED AS BASE BID WORK SHALL BE INCLUDED UNDER THE BASE BID. COORDINATE FINAL POLE LOCATIONS, FOOTING REQUIREMENTS, FIXTURE AIMING, ELECTRICAL CONNECTION POINTS, AND SYSTEM REQUIREMENTS WITH THE CONTRACT DOCUMENTS AND MANUFACTURER'S REQUIREMENTS.

\\P:\Information\MA\Nantucket Farm\GIS\GIS2021_185\DWG\185\GEN\185T001.dwg
Amended: November 11, 2025 9:47 AM

GENERAL NOTES

1.

PROPERTY LINES, SITE SURVEY AND TOPOGRAPHICAL INFORMATION BASED ON THE GROUND SURVEY PERFORMED BY BLACKWELL & ASSOCIATES INC, PROFESSIONAL LAND SURVEYORS & CIVIL ENGINEERS, 20 TEASDALE CIRCLE, NANTUCKET, MA 02554, PHONE: 508-228-0208 EXT. 12, LEO@BLACKWELLSURVEY.COM, JUNE 8, 2025, AMENDED ON DECEMBER 16, 2025.
2.

THE SURVEY INFORMATION SHOWN HEREON WAS PROVIDED BY OTHERS AND IS ASSUMED TO BE CORRECT. THE DESIGN IS BASED ON THIS INFORMATION. ANY DISCREPANCIES IN HORIZONTAL OR VERTICAL CONTROL, INCLUDING GEOLOCATION, SHALL BE REPORTED TO THE ENGINEER/LANDSCAPE ARCHITECT PRIOR TO COMMENCEMENT OF CONSTRUCTION. NO WORK SHALL PROCEED UNTIL DISCREPANCIES ARE RESOLVED.
3.

ALL BIDDERS ARE REQUIRED TO INSPECT THE PROJECT SITE IN ITS ENTIRETY PRIOR TO SUBMITTING THEIR BID, AND BECOME FAMILIAR WITH ALL CONDITIONS AS THEY MAY AFFECT THEIR BID. CONTRACTOR AND SUB-CONTRACTOR SHALL BE FAMILIAR WITH ALL DRAWINGS AND SPECIFICATIONS PRIOR TO COMMENCING THE CONSTRUCTION.
4.

LOCATIONS OF ANY UTILITIES SHOWN ON THESE PLANS ARE APPROXIMATE ONLY. CONTRACTOR SHALL BE RESPONSIBLE FOR VERIFYING THE LOCATION OF SUCH UTILITIES, PROTECTING ALL EXISTING UTILITIES AND REPAIRING ANY DAMAGE DONE DURING CONSTRUCTION. THE CONTRACTOR SHALL BE RESPONSIBLE FOR ALL ON-SITE COORDINATION WITH UTILITY COMPANIES AND PUBLIC AGENCIES AND FOR OBTAINING ALL REQUIRED PERMITS AND PAYING ALL REQUIRED FEES. IN ACCORDANCE WITH M.G.L. CHAPTER 82, SECTION 40, INCLUDING AMENDMENTS, CONTRACTORS SHALL NOTIFY ALL UTILITY COMPANIES AND GOVERNMENT AGENCIES IN WRITING PRIOR TO EXCAVATION. CONTRACTOR SHALL ALSO CALL MASSACHUSETTS DIG SAFE (811) AT (888) 344-7233 NO LESS THAN 72 HOURS (EXCLUSIVE OF WEEKENDS AND HOLIDAYS) PRIOR TO SUCH EXCAVATION, IN ACCORDANCE WITH M.G.L. CHAPTER 82, SECTION 40 AND ALL APPLICABLE AMENDMENTS. DOCUMENTATION OF REQUESTS SHALL BE PROVIDED TO PROJECT REPRESENTATIVE PRIOR TO EXCAVATION WORK.
5.

WHERE AN EXISTING UTILITY IS FOUND TO CONFLICT WITH THE PROPOSED WORK, THE LOCATION, ELEVATION AND SIZE OF THE UTILITY SHALL BE ACCURATELY DETERMINED WITHOUT DELAY BY THE CONTRACTOR AND THE INFORMATION FURNISHED TO THE OWNERS REPRESENTATIVE FOR RESOLUTION OF THE CONFLICT.
6.

THE CONTRACTOR SHALL MAKE ALL ARRANGEMENTS FOR THE ALTERATION AND ADJUSTMENT OF SANITARY SEWER, SEPTIC, COMMUNICATIONS, WATER, GAS, ELECTRIC, TELEPHONE AND ANY OTHER PRIVATE UTILITIES BY THE UTILITY OWNER AT NO ADDITIONAL COST TO THE TOWN OF NANTUCKET.
7.

CONTRACTOR SHALL BE RESPONSIBLE FOR REVIEWING ALL DRAWINGS AND SPECIFICATIONS TO DETERMINE THE EXTENT OF EXCAVATION AND DEMOLITION REQUIRED TO RECEIVE SITE IMPROVEMENTS.
8.

ANY DISCREPANCIES OR CONFLICTS BETWEEN THE DRAWINGS AND EXISTING CONDITIONS, EXISTING CONDITIONS TO REMAIN, TEMPORARY CONSTRUCTION, PERMANENT CONSTRUCTION AND WORK OF ADJACENT CONTRACTS SHALL BE BROUGHT TO THE ATTENTION OF THE OWNER BEFORE PROCEEDING. ITEMS ENCOUNTERED IN AREAS OF EXCAVATION THAT ARE NOT INDICATED ON THE DRAWINGS, BUT ARE VISIBLE ON SURFACE, SHALL BE THE CONTRACTOR'S RESPONSIBILITY AND SHALL BE REMOVED AT NO ADDITIONAL COST TO THE OWNER.
9.

ANY ALTERATIONS TO THESE DRAWINGS MADE IN THE FIELD DURING CONSTRUCTION SHALL BE RECORDED BY THE GENERAL CONTRACTOR ON "AS-BUILT" DRAWINGS.
10.

ALL AREAS DISTURBED BY THE CONTRACTOR'S OPERATIONS OUTSIDE THE PROJECT LIMITS, SHALL BE RESTORED TO THE ORIGINAL CONDITION BY THE CONTRACTOR AT NO ADDITIONAL COST AND TO THE SATISFACTION OF THE OWNER.
11.

EXISTING ITEMS SHOWN ON THE PLANS ARE IDENTIFIED AS 'EXISTING' OR 'EX'. ALL OTHER ITEMS SHALL BE CONSIDERED PART OF THE WORK, UNLESS OTHERWISE NOTED.
12.

ALL KNOWN EXISTING STATE, COUNTY AND TOWN LOCATION LINES AND PRIVATE PROPERTY LINES HAVE BEEN ESTABLISHED FROM AVAILABLE INFORMATION AND ARE INDICATED ON THE PLANS.
13.

THE CONTRACTOR SHALL TAKE ALL NECESSARY PRECAUTIONS TO PROTECT HIS EMPLOYEES, AS WELL AS PUBLIC USERS FROM INJURY DURING THE ENTIRE CONSTRUCTION PERIOD USING ALL NECESSARY SAFEGUARDS, INCLUDING BUT NOT LIMITED TO, THE ERECTION OF TEMPORARY WALKS, STRUCTURES, PROTECTIVE BARRIERS, COVERING, OR FENCES AS NEEDED.
14.

CONTRACTOR SHALL COORDINATE ALL WORK ADJACENT TO ACTIVE OR OCCUPIED FACILITIES WITH THE OWNER AND SHALL MAINTAIN SAFE ACCESS FOR THE PUBLIC AT ALL TIMES.
15.

THE CONTRACTOR SHALL SUPPLY THE OWNER WITH THE NAME OF THE OSHA "COMPETENT PERSON" PRIOR TO CONSTRUCTION.
16.

FILLING OF EXCAVATED AREAS SHALL NOT TAKE PLACE WITHOUT THE PRESENCE OR PERMISSION OF THE OWNER.
17.

EXISTING TREES TO REMAIN SHALL BE PROTECTED FROM CONSTRUCTION ACTIVITIES. NO STOCKPILING OF MATERIAL, EQUIPMENT OR VEHICULAR TRAFFIC SHALL BE ALLOWED WITHIN THE DRIP LINE OF TREES TO REMAIN. NO GUYS SHALL BE ATTACHED TO ANY TREE TO REMAIN. WHEN NECESSARY OR AS DIRECTED BY THE ENGINEER, THE CONTRACTOR SHALL ERECT TEMPORARY BARRIERS FOR THE PROTECTION OF EXISTING TREES DURING CONSTRUCTION.
18.

TREES AND SHRUBS WITHIN THE LIMITS OF WORK SHALL BE REMOVED ONLY UPON THE APPROVAL OF THE OWNER REPRESENTATIVE OR AS NOTED ON THE PLANS.
19.

NO FILLING SHALL OCCUR AROUND EXISTING TREES TO REMAIN WITHOUT THE APPROVAL OF THE OWNER OR OWNER REPRESENTATIVE.
20.

THE CONTRACTOR SHALL REMOVE ALL SURFACE VEGETATION PRIOR TO GRADING THE SITE. TREES AND STUMPS SHALL BE REMOVED AND DISPOSED COMPLETE BY CONTRACTOR. TEMPORARY EROSION CONTROL MEASURES SHOWN ON THE DRAWINGS (INCLUDING SILT FENCE, STRAW WATTLES, OR SILT SOCKS) SHALL BE INSTALLED BY THE CONTRACTOR. THE CONTRACTOR SHALL BE RESPONSIBLE FOR MAINTAINING THESE TEMPORARY EROSION CONTROL MEASURES THROUGHOUT THE PROJECT WHICH COST SHALL BE INCIDENTAL TO THE PROJECT.
21.

ALL UNSUITABLE UNCONTAMINATED EXCESS SOIL FROM CONSTRUCTION ACTIVITIES SHALL BE DISPOSED OF BY THE CONTRACTOR AT NO ADDITIONAL COST TO THE TOWN. REMOVAL ACTIVITIES SHALL BE IN ACCORDANCE WITH STATE AND LOCAL REGULATIONS AT NO ADDITIONAL COST TO THE TOWN. SUITABLE SOIL EXCAVATION AS PART OF THE PROJECT MUST MEET ONE OR MORE OF THE MATERIAL REQUIREMENTS SPECIFIED. ON-SITE FILL MATERIALS, WHICH DO NOT CONFORM TO THE SPECIFICATIONS, SHALL NOT BE USED BELOW ANY STRUCTURES. IF THE CONTRACTOR PROPOSES TO USE THE EXISTING FILL ON SITE BELOW PAVEMENT AREAS, THE CONTRACTOR MUST DEMONSTRATE THAT THE FILL MEETS THE REQUIREMENTS PER THE SPECIFICATIONS. ALL EXCAVATED FILL MATERIAL WHICH DOES NOT MEET THE REQUIREMENTS OF THE CONTRACT DOCUMENTS SHALL BE REMOVED AND DISPOSED OF OFF-SITE AT NO ADDITIONAL COST.
22.

CONTRACTOR IS RESPONSIBLE FOR STAKING CONSTRUCTION BASELINES IN FIELD WITH A MASSACHUSETTS REGISTERED PROFESSIONAL LAND SURVEYOR. NO CONSTRUCTION WILL BE PERFORMED WITHOUT THE PROPOSED BASELINES AND LAYOUTS APPROVED BY THE OWNER REPRESENTATIVE.
23.

NO FILL SHALL CONTAIN HAZARDOUS MATERIALS.
24.

CONTRACTOR SHALL PROVIDE TEMPORARY FENCING AROUND PERIMETER OF WORK AREA (LIMIT OF WORK). FENCE SHALL NOT IMPEDE TRAVEL WAYS.
25.

ANY QUANTITIES SHOWN ON PLANS ARE FOR COMPARATIVE BIDDING PURPOSES ONLY. IT IS THE CONTRACTOR'S RESPONSIBILITY TO VISIT THE PROJECT SITE TO VERIFY ALL QUANTITIES AND CONDITIONS PRIOR TO SUBMITTING BID.
26.

ALL EXISTING DRAINAGE FACILITIES TO REMAIN SHALL BE MAINTAINED FREE OF DEBRIS, SOIL, SEDIMENT, AND FOREIGN MATERIAL AND OPERATIONAL THROUGHOUT THE LIFE OF THE CONTRACT. REMOVE ALL SOIL, SEDIMENT, DEBRIS AND FOREIGN MATERIAL FROM ALL DRAINAGE STRUCTURES, INCLUDING BUT NOT LIMITED TO, DRAINAGE INLETS, MANHOLES AND CATCH BASINS WITHIN THE LIMIT OF WORK AND DRAINAGE STRUCTURES OUTSIDE THE LIMIT OF WORK THAT ARE IMPACTED BY THE WORK FOR THE ENTIRE DURATION OF CONSTRUCTION.
27.

CONTRACTOR'S STAGING AREA MUST BE WITHIN THE CONTRACT LIMIT LINE AND IN AREAS APPROVED BY OWNER. ANY OTHER AREAS THAT THE CONTRACTOR MAY WISH TO USE FOR STAGING MUST BE COORDINATED WITH THE OWNER.
28.

THE CONTRACTOR SHALL KEEP ALL STREETS, PARKING LOTS AND WALKS THAT ARE NOT RESTRICTED FROM PUBLIC USE DURING CONSTRUCTION BROOM CLEAN AT ALL TIMES. THE CONTRACTOR SHALL USE ACCEPTABLE METHODS AND MATERIALS TO MAINTAIN ADEQUATE DUST CONTROL THROUGHOUT CONSTRUCTION.
29.

CONTRACTOR SHALL COORDINATE ALL WORK WITH THE OWNER.
30.

CONTRACTOR SHALL DEWATER AS NECESSARY TO PERFORM THE PROPOSED WORK.
31.

THE LIMIT OF WORK SHALL BE DELINEATED IN THE FIELD PRIOR TO THE START OF SITE CLEARING OR CONSTRUCTION AND AGREED UPON WITH THE LANDSCAPE ARCHITECT.
32.

DEEP SUMP CATCH BASINS AND STORMWATER BASINS SHALL BE CLEANED FOLLOWING CONSTRUCTION AND SHALL FOLLOW THE OPERATION AND MAINTENANCE PLAN THEREAFTER.
33.

HAULING OF EARTH MATERIALS TO AND FROM THE SITE SHALL BE RESTRICTED TO THE HOURS OF 7:30 AM TO 5 PM.
34.

CONTRACTOR SHALL COMPLY WITH ALL TOWN OF NANTUCKET SEASONAL AND SUMMER CONSTRUCTION RESTRICTIONS, INCLUDING ANY LIMITATIONS ON HOURS, DAYS, OR ACTIVITIES, WHETHER OR NOT EXPLICITLY SHOWN ON THE PLANS OR SPECIFICATIONS.
35.

ANY BOULDERS 3 CY OR SMALLER SHALL BE CONSIDERED UNDOCUMENTED FILL AND SHALL BE DISPOSED OF AT NO ADDITIONAL COST TO THE TOWN.
36.

WORK ON SATURDAYS SHALL ONLY BE CONDUCTED IF PRIOR WRITTEN PERMISSION IS PROVIDED BY THE TOWN.
37.

NO TRUCKS LEFT IDLING ON TOWN STREETS DURING CONSTRUCTION. CONSTRUCTION TRAFFIC AT NO TIME SHALL IMPEDE FLOW OF RESIDENT TRAFFIC.
38.

SOCCER FIELD LAYOUT AND STRIPING SHOWN FOR REFERENCE ONLY AND SHALL BE PROVIDED BY OWNER. SOCCER GOALS SHALL ALSO BE PROVIDED BY OWNER.

EROSION AND SEDIMENT CONTROL NOTES

1.

ALL SEDIMENT AND EROSION CONTROL DEVICES SHALL BE PUT INTO PLACE PRIOR TO BEGINNING ANY CONSTRUCTION OR DEMOLITION. REFER TO PLANS FOR APPROXIMATE LOCATION OF EROSION AND SEDIMENT CONTROL. REFER TO SPECS AND DETAILS FOR TYPE OF EROSION AND SEDIMENT CONTROL.
2.

THE CONTRACTOR SHALL BE RESPONSIBLE FOR THE CONTINUAL MAINTENANCE OF ALL CONTROL DEVICES THROUGHOUT THE DURATION OF THE PROJECT.
3.

CONTRACTOR SHALL REPAIR, REPLACE, OR SUPPLEMENT FAILED OR INEFFECTIVE EROSION AND SEDIMENT CONTROL MEASURES IMMEDIATELY UPON DISCOVERY OR AS DIRECTED BY THE OWNER'S REPRESENTATIVE, AT NO ADDITIONAL COST TO THE OWNER.
4.

CONTRACTOR SHALL INSPECT EROSION AND SEDIMENT CONTROL MEASURES FOLLOWING SIGNIFICANT RAIN EVENTS AND REPAIR OR REPLACE AS NECESSARY.
5.

CONTRACTOR SHALL MEET ALL OF THE STATE OF MASSACHUSETTS D.E.P. AND THE TOWN OF NANTUCKET WETLAND ORDINANCE REGULATIONS FOR SEDIMENT AND EROSION CONTROL.
6.

EXCAVATED MATERIAL STOCKPILED ON THE SITE SHALL BE SURROUNDED BY A RING OF UNBROKEN SEDIMENT AND EROSION CONTROL FENCE. THE LIMITS OF ALL GRADING AND DISTURBANCE SHALL BE KEPT TO A MINIMUM WITHIN THE APPROVED AREA OF CONSTRUCTION. ALL AREAS OUTSIDE OF THE LIMIT OF CONTRACT SHALL REMAIN TOTALLY UNDISTURBED UNLESS OTHERWISE APPROVED BY OWNER'S REPRESENTATIVE.
7.

ALL CATCH BASINS AND DRAIN GRATES WITHIN LIMIT OF CONTRACT SHALL BE PROTECTED WITH SILT SACKS DURING THE ENTIRE DURATION OF CONSTRUCTION.
8.

EROSION CONTROL BARRIERS TO BE INSTALLED AT THE TOE OF SLOPES. SEE GRADING & DRAINAGE PLANS, NOTES, DETAILS AND SPECIFICATIONS.
9.

THE CONTRACTOR SHALL PROVIDE DUST CONTROL FOR CONSTRUCTION OPERATIONS AS APPROVED BY OWNER.
10.

ALL POINTS OF CONSTRUCTION EGRESS OR INGRESS SHALL BE MAINTAINED TO PREVENT TRACKING OR FLOWING OF SEDIMENT ON TO PUBLIC/PRIVATE ROADS.

DEMOLITION & SITE PREPARATION NOTES

1.

THE CONTRACTOR SHALL INCLUDE IN THE BID THE COST OF REMOVING ANY EXISTING SITE FEATURES AND APPURTENANCES NECESSARY TO ACCOMPLISH THE CONSTRUCTION OF THE PROPOSED SITE IMPROVEMENTS. THE CONTRACTOR SHALL ALSO INCLUDE IN THE BID THE COST NECESSARY TO RESTORE SUCH ITEMS IF THEY ARE SCHEDULED TO REMAIN AS PART OF THE FINAL SITE IMPROVEMENTS. REFER TO PLANS TO DETERMINE EXCAVATION, DEMOLITION AND TO DETERMINE THE LOCATION OF THE PROPOSED SITE IMPROVEMENTS.
2.

THE OWNER RESERVES THE RIGHT TO REVIEW ALL MATERIALS DESIGNATED FOR REMOVAL AND TO RETAIN OWNERSHIP OF SUCH MATERIALS. IF THE OWNER RETAINS ANY MATERIAL THE CONTRACTOR SHALL MAKE ARRANGEMENTS WITH THE OWNER TO HAVE THOSE MATERIALS REMOVED OFF SITE AT NO ADDITIONAL COST.
3.

UNLESS SPECIFICALLY NOTED TO BE REMOVED / SALVAGED (R&S), ALL SITE FEATURES CALLED FOR REMOVAL (REM) SHALL BE REMOVED WITH THEIR FOOTINGS, ATTACHMENTS, BASE MATERIAL, ETC. TRANSPORTED FROM THE SITE TO BE DISPOSED OF IN A LAWFUL MANNER AT AN ACCEPTABLE DISPOSAL SITE AND AT NO ADDITIONAL COST TO THE OWNER.
4.

ALL EXISTING SITE FEATURES TO REMAIN SHALL BE PROTECTED THROUGHOUT THE CONSTRUCTION PERIOD. ANY FEATURES DAMAGED DURING CONSTRUCTION OPERATIONS SHALL BE REPAIRED OR REPLACED TO THE SATISFACTION OF THE OWNER'S REPRESENTATIVE AT NO ADDITIONAL COST.
5.

DURING EARTHWORK OPERATIONS, CONTRACTOR SHALL TAKE CARE TO NOT DISTURB EXISTING MATERIALS TO REMAIN, OUTSIDE THE LIMITS OF EXCAVATION AND BACKFILL AND SHALL TAKE WHATEVER MEASURES NECESSARY, AT THE CONTRACTOR'S EXPENSE, TO PREVENT ANY EXCAVATED MATERIAL FROM COLLAPSING. ALL BACKFILL MATERIALS SHALL BE PLACED AND COMPACTED AS SPECIFIED TO THE SUBGRADE REQUIRED FOR THE INSTALLATION OF THE REMAINDER OF THE CONTRACT WORK.
6.

IT SHALL BE THE CONTRACTOR'S OPTION, WITH CONCURRENCE OF THE OWNER, TO REUSE EXISTING GRAVEL IF IT MEETS THE REQUIREMENTS OF THE SPECIFICATIONS FOR GRAVEL BORROW.
7.

STRIP AND REMOVE TURF SHALL INCLUDE REMOVAL OF GRASS, SHRUBS, AND UNDERBRUSH, REMOVAL OF ROOTS, ROUGH GRADING, INSTALLATION OF LOAM (IF APPLICABLE), FINE GRADING, SEEDING AND TURF ESTABLISHMENT BY THE CONTRACTOR.
8.

TREES DESIGNATED FOR REMOVAL SHALL BE TAGGED BY CONTRACTOR AND APPROVED BY OWNER'S REPRESENTATIVE PRIOR TO COMMENCEMENT OF CONSTRUCTION.
9.

THE STORAGE OF MATERIALS AND EQUIPMENT WILL BE PERMITTED AT LOCATIONS DESIGNATED BY OWNER OR OWNER'S REPRESENTATIVE. PROTECTION OF STORED MATERIALS AND EQUIPMENT SHALL BE THE SOLE RESPONSIBILITY OF THE CONTRACTOR.
10.

LOAM / TOP SOIL DESIGNATED FOR REUSE AS GENERAL FILL SHALL BE BLENDED WITH SUITABLE BORROW MATERIAL AS SPECIFIED.
11.

THE CONTRACTOR SHALL PROTECT EXISTING TREES TO REMAIN. CONTRACTOR SHALL INSTALL TREE PROTECTION BARRIER AFTER CLEARING UNDERBRUSH AND TAKE DUE CARE TO PREVENT INJURY TO TREES DURING CLEARING OPERATIONS.

LAYOUT & MATERIALS NOTES

1.

COORDINATE ALL LAYOUT ACTIVITIES WITH THE SCOPE OF WORK CALLED FOR BY DEMOLITION, GRADING AND UTILITIES OPERATIONS ENCOMPASSED BY THIS CONTRACT. SET, PROTECT AND REPLACE REFERENCE STAKES AS NECESSARY OR AS REQUIRED BY THE OWNERS REPRESENTATIVE.
2.

ALL WORK SHALL BE PERFORMED BY CONTRACTOR UNLESS SPECIFICALLY INDICATED THAT THE WORK WILL BE PERFORMED "BY OTHERS" OR "UNDER SEPARATE CONTRACT".
3.

TO FACILITATE LAYOUT OF PROPOSED SITE FEATURES AND FACILITIES, LAYOUT INFORMATION FOR CERTAIN FUTURE WORK, WHICH IS NOT INCLUDED WITHIN THE SCOPE OF THIS CONTRACT HAS BEEN PROVIDED ON THE LAYOUT AND MATERIALS PLAN FOR INFORMATION ONLY. SOME ITEMS ARE "NOT IN CONTRACT" (NIC) AND SHOWN FOR REFERENCE ONLY.
4.

THE LAYOUT OF SITE AMENITIES AND FENCES MUST BE APPROVED BY THE OWNER REPRESENTATIVE PRIOR TO INSTALLATION.
5.

THE LAYOUT OF ALL NEW PATHWAYS / WALKWAYS AND THE GRADING OF ALL SLOPES AND CROSS SLOPES SHALL CONFORM TO THE RULES AND REGULATIONS FOR HANDICAP ACCESS CODE OF MASSACHUSETTS REGULATIONS TITLE 821, AND THE AMERICANS WITH DISABILITIES ACT (ADA), TITLE 3. THE CONTRACTOR SHALL NOTIFY THE OWNER IMMEDIATELY OF ANY DISCREPANCIES BETWEEN ACTUAL CONDITIONS AND THOSE REQUIRED.
6.

ALL LAYOUT LINES, OFFSETS, OR REFERENCES TO LOCATING OBJECTS ARE EITHER PARALLEL OR PERPENDICULAR UNLESS OTHERWISE DESIGNATED WITH ANGLE OFFSETS NOTED.
7.

ALL PROPOSED SITE FEATURES SHALL BE LAID OUT AND STAKED FOR REVIEW AND APPROVAL BY THE OWNER'S REPRESENTATIVE PRIOR TO COMMENCEMENT OF INSTALLATION. ANY REQUIRED ADJUSTMENTS TO THE LAYOUT SHALL BE UNDERTAKEN AS DIRECTED, AT NO ADDITIONAL COST TO THE OWNER. ALL LAYOUT SHALL BE PERFORMED BY A MASSACHUSETTS REGISTERED PROFESSIONAL LAND SURVEYOR.
8.

ALL PROPOSED PAVEMENTS SHALL MEET THE LINE AND GRADE OF EXISTING ADJACENT PAVEMENT SURFACES. ALL BITUMINOUS CONCRETE / ASPHALT SHALL BE TREATED WITH AN RS-1 TACK COAT AT POINT OF CONNECTION. ALL PATHWAY WIDTHS SHALL BE AS NOTED ON THE LAYOUT AND MATERIALS PLAN.
9.

THE CONTRACTOR SHALL VERIFY ALL DIMENSIONS AND GRADES ON THE GROUND AND REPORT ANY DISCREPANCIES IMMEDIATELY TO THE OWNER.
10.

THE CONTRACTOR SHALL BE RESPONSIBLE FOR FIELD MEASUREMENT OF ALL PROPOSED FENCES AND GATES.
11.

THE DEPTH OF LOAM BORROW FOR ALL PROPOSED LAWN AREAS SHALL BE 6" MINIMUM. ALL DISTURBED AREAS SHALL BE RESTORED WITH LOAM AND SEED UNLESS OTHERWISE NOTED
12.

REFER TO DETAIL DRAWINGS FOR CONSTRUCTION DETAILS.
13.

SURVEY CONTROL POINTS AND COORDINATES ARE INDICATED ON THE PLANS. IT IS THE RESPONSIBILITY OF THE CONTRACTOR TO PROTECT OR CREATE HIS OWN PROTECTED CONTROL POINTS FROM THIS INFORMATION. THE CONTRACTOR IS RESPONSIBLE FOR ENSURING ALL LAYOUT POINTS ARE CONSISTENT WITH CONTROL INFORMATION. RESETTING OF DAMAGED OR MISSING LAYOUT MARKERS AS NECESSARY IS AT NO ADDITIONAL COST TO THE OWNER.

GRADING, UTILITIES & DRAINAGE NOTES

1.

ALL WORK RELATING TO INSTALLATION, RENOVATION OR MODIFICATION OF WATER, DRAINAGE AND/OR SEWER SERVICES SHALL BE PERFORMED IN ACCORDANCE WITH THE STANDARDS OF THE TOWN OF NANTUCKET DPW.
2.

THE CONTRACTOR SHALL VERIFY ALL DIMENSIONS AND GRADES ON THE GROUND AND REPORT ANY DISCREPANCIES IMMEDIATELY TO THE OWNER.
3.

ALL GRADING IS TO BE SMOOTH AND CONTINUOUS WHERE PROPOSED SURFACES MEET EXISTING SURFACES. ELIMINATE ROUGH SPOTS AND ABRUPT GRADE CHANGES AND MEET LINE AND GRADE OF EXISTING CONDITIONS WITH NEW IMPROVEMENTS.
4.

CONTRACTOR SHALL MAINTAIN POSITIVE DRAINAGE (1.5% MINIMUM) AWAY FROM ALL BUILDING FOUNDATIONS AND STRUCTURES.
5.

CONTRACTOR SHALL ENSURE ALL AREAS ARE PROPERLY PITCHED TO DRAIN, WITH NO SURFACE WATER PONDING OR PUDDLING.
6.

MINIMUM CROSS SLOPE ON ALL WALKWAYS WILL BE 1.0% TO PROVIDE POSITIVE DRAINAGE. ANY DISCREPANCIES NOT ALLOWING THIS TO OCCUR SHALL BE REPORTED TO THE OWNER PRIOR TO CONTINUING WORK.
7.

ALL UTILITY GRATES, COVERS OR OTHER SURFACE ELEMENTS INTENDED TO BE EXPOSED AT GRADE SHALL BE FLUSH WITH THE ADJACENT FINISHED GRADE AND ADJUSTED TO PROVIDE A SMOOTH TRANSITION AT ALL EDGES.
8.

THE CONTRACTOR SHALL SET SUBGRADE ELEVATIONS TO ALLOW FOR POSITIVE DRAINAGE AND PROVIDE EROSION CONTROL DEVICES, STRUCTURES, MATERIALS AND CONSTRUCTION METHODS TO DIRECT SILT MIGRATION AWAY FROM DRAINAGE AND OTHER UTILITY SYSTEMS, PUBLIC/PRIVATE STREETS AND WORK AREAS. CLEAN BASINS REGULARLY AS NEEDED AND AT THE END OF THE PROJECT.
9.

EXCAVATION REQUIRED WITHIN PROXIMITY OF KNOWN EXISTING UTILITY LINES SHALL BE DONE BY HAND. CONTRACTOR SHALL REPAIR ANY DAMAGE TO EXISTING UTILITY LINES OR STRUCTURES INCURRED DURING CONSTRUCTION OPERATIONS AT NO COST TO THE OWNER.
10.

WHERE NEW EARTHWORK MEETS EXISTING GRADE CONTRACTOR SHALL BLEND NEW EARTHWORK SMOOTHLY INTO EXISTING, PROVIDING VERTICAL CURVES OR ROUNDS AT ALL TOP AND BOTTOM OF SLOPES.
11.

WHERE A SPECIFIC LIMIT OF WORK LINE IS NOT OBVIOUS OR IMPLIED, BLEND GRADES TO EXISTING CONDITIONS WITHIN 5 FEET OF PROPOSED CONTOURS.
12.

RESTORE ALL DISTURBED AREAS AND LIMITS OF ALL REMOVALS TO LOAM AND SEED (L&S) UNLESS OTHERWISE NOTED.
13.

SEE EARTHWORK SECTION OF SPECIFICATIONS FOR SPECIFIC EXCAVATION AND FILLING PROCEDURES.

ABBREVIATIONS

GENERAL

ABAN
ADJ
B
BIT. CONC.
B.M.
BVCL
BWV
BWLL
CEM. CONC.
CLF
CTE
E.C.
EOP
EQ
EXIST. (OR EX.)
FON
FF
F.L. (OR F)
G.C.
GRAN. CURB
H.C.
HMA
LOW
MB
M.H.B.
NIC
N.T.S.
P
P.C.
PROP
PROT
PVMT
P.W.W.
RC
REM
REMOD
RET
RL
R.O.W.
RAD
R&S
R&S
SB
SB/DH
SWEL
SYEL
T.
TYP.
VIF
WCR

ABANDON
ADJUST
BASELINE
BITUMINOUS CONCRETE (ASPHALT)
BENCH MARK
BLACK VINYL CHAIN LINK
BORDERING VEGETATED WETLAND
BROKEN WHITE LANE LINE
CEMENT CONCRETE
CHAIN LINK FENCE
CONNECT TO EXISTING
ELECTRICAL CONTRACTOR
EDGE OF PAVEMENT
EQUIPMENT
EXISTING
FOUNDATION
FINISHED FLOOR
FLOW LINE
GENERAL CONTRACTOR
GRANITE CURB
HANDICAP
HOT MIX ASPHALT
LIMIT OF WORK
MAIL BOX
MASSACHUSETTS HIGHWAY BOUND
NOT IN CONTRACT
NOT TO SCALE
PROPERTY LINE
PLUMBING CONTRACTOR
PROPOSED
PROTECT
PAVEMENT
PAVED WATERWAY
REINFORCED CONCRETE
REMOVE
REMODEL
RETAIN
ROOF LEADER
RIGHT-OF-WAY
REMOVE AND DISPOSE
REMOVE AND SALVAGE
REMOVE, RELOCATE AND SALVAGE
STONE BOUND
STONE BOUND/ DRILL HOLE
SOLID WHITE EDGE LINE
SOLID YELLOW EDGE LINE
TEMPORARY
TYPICAL
VERIFY IN FIELD
WHEEL CHAIR RAMP

UTILITIES

ACOM PIPE
CB
CBCI
CI
C.IRON
C.I.T.
CIP
CMP
CO
CU
DI
DMH
DS
F&C
F&G
GI
GICI
GV
GW
HDPE
HH
HYD
INV.
LB
LC
LG
LP
OCS
OGT
ONW
PVC
RCP
SMH
SWTU
UP
UPLP
VC
WG

ASPHALT COATED CORRUGATED METAL PIPE
CATCH BASIN
CATCH BASIN W/ CURB INLET
CURB INLET
CAST IRON
CHANGE IN TYPE
CAST IRON PIPE
CORRUGATED METAL PIPE
CLEANOUT
CONNECTION UNKNOWN
DRAIN INLET
DRAIN MANHOLE
DOWN SPOUT
FRAME AND COVER
FRAME AND GRATE
GUTTER INLET
GUTTER INLET W/ CURB INLET
GATE VALVE
GARAGE WASTE
HIGH DENSITY POLYETHYLENE PIPE
HANDHOLE
HYDRANT
INVERT ELEVATION
LEACHING BASIN
LEACHING CHAMBER
LEACHING GALLEY
LIGHT POLE
OUTLET CONTROL STRUCTURE
OIL AND GRIT TRAP
OVERHEAD WIRE
POLYVINYL CHLORIDE
REINFORCED CONCRETE PIPE
SEWER MANHOLE
STORM WATER TREATMENT UNIT
UTILITY POLE
UTILITY POLE WITH LIGHT
VITRIFIED CLAY PIPE
WATER GATE

ALIGNMENT/GRADING

BC
BW
CC
ELEV
H.P.
L.P.
PC
PCC
PI
PRC
PT
PVC
PVI
PVT
R
S.S.D.
STA
TC
TW

BOTTOM OF CURB
BOTTOM OF WALL
CENTER OF CURVE
ELEVATION
HIGH POINT
LOW POINT
POINT OF CURVATURE
POINT OF COMPOUND CURVATURE
POINT OF INTERSECTION
POINT OF REVERSE CURVATURE
POINT OF TANGENCY
POINT OF VERTICAL CURVATURE
POINT OF VERTICAL INTERSECTION
POINT OF VERTICAL TANGENCY
RADIUS OF CURVATURE
STOPPING SIGHT DISTANCE
STATION
TOP OF CURB
TOP OF WALL

Project: TOWN OF NANTUCKET



NOBADEER ATHLETIC FIELDS
IMPROVEMENTS

7 NOBADEER FARM ROAD



Weston & Sampson Engineers, Inc.
1 Washington Mall, 10th Floor
Boston, MA 02108
978.532.1900 800.SAMPSON

www.westonandsampson.com

Consultants:

Revisions:		
No.	Date	Description

COA:

Seal:



Issued For:

BID DOCUMENTS

Scale: AS NOTED

Date: AUGUST 7, 2026

Drawn By:

Reviewed By:

Approved By:

W&S Project No.: ENG24-1207


W&S File No.:

Drawing Title:

GENERAL NOTES


Sheet Number:

L001

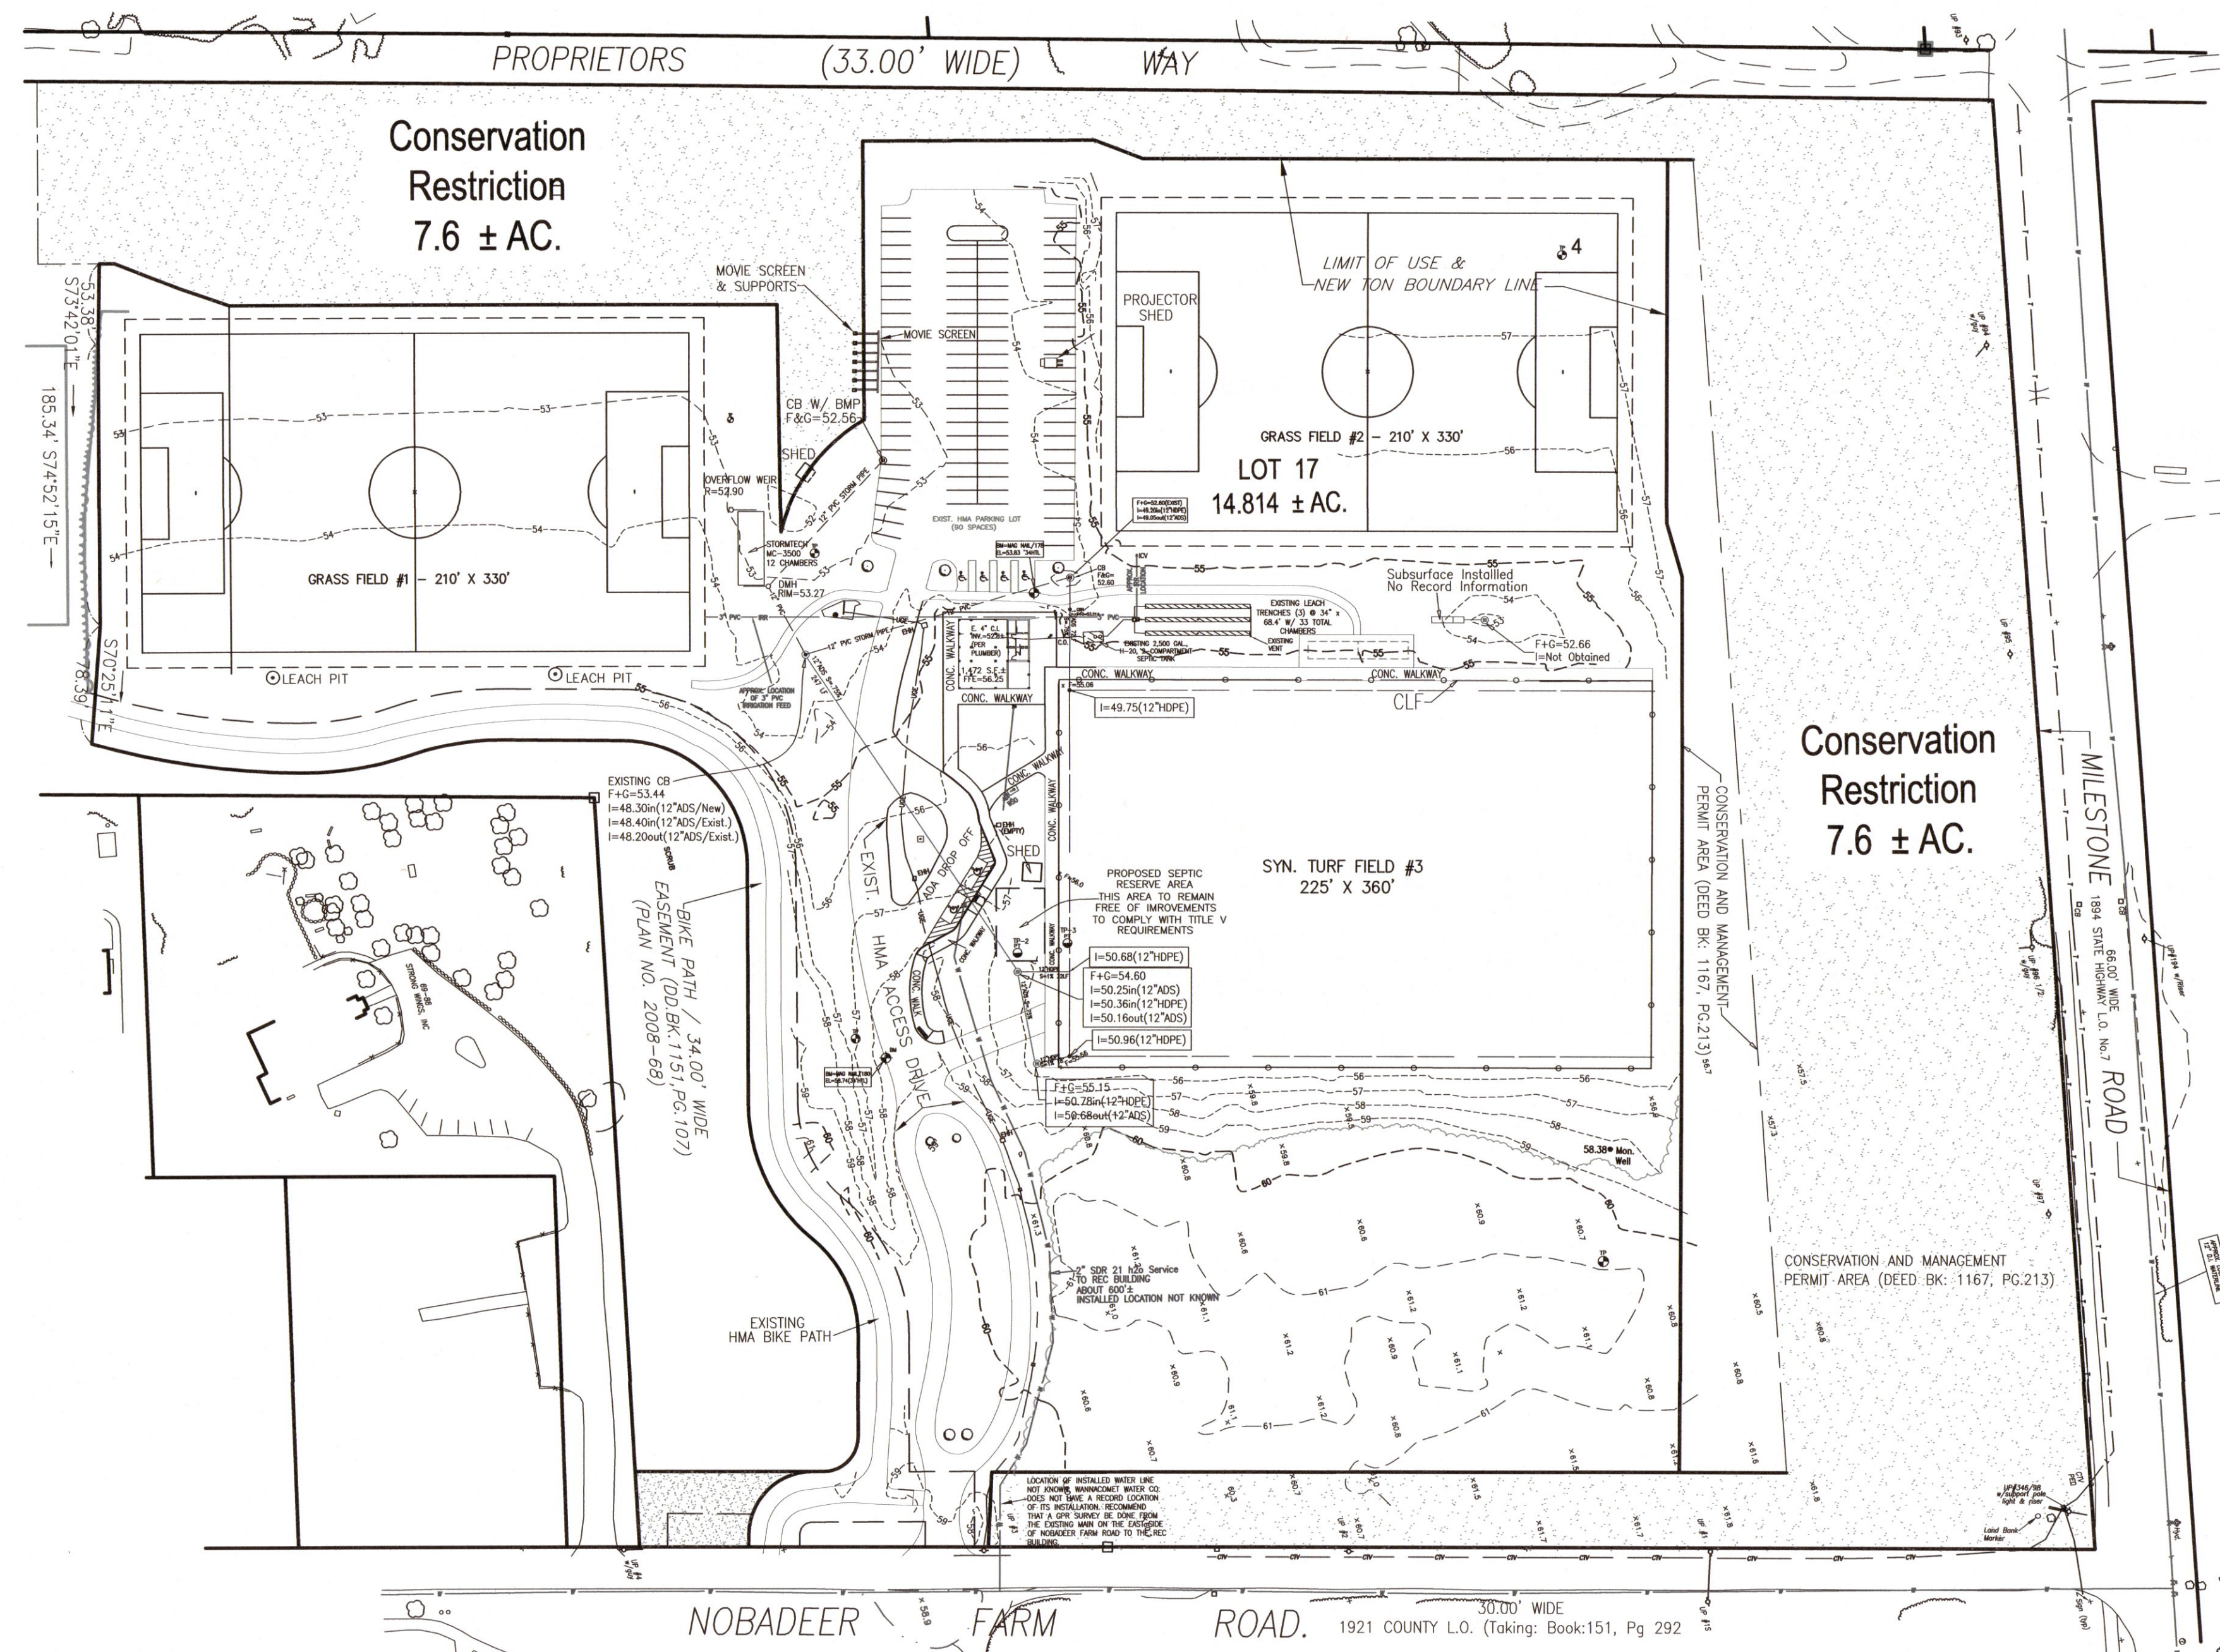

NO.	DATE	DESCRIPTION	BY

OWNER INFORMATION
TOWN OF NANTUCKET
DEED: 1980/ 083
PLAN NO. 2023-36
14.814 Acres
ASSESSOR'S MAP 69, PARCEL 1.1
#5 NOBADEER FARM ROAD

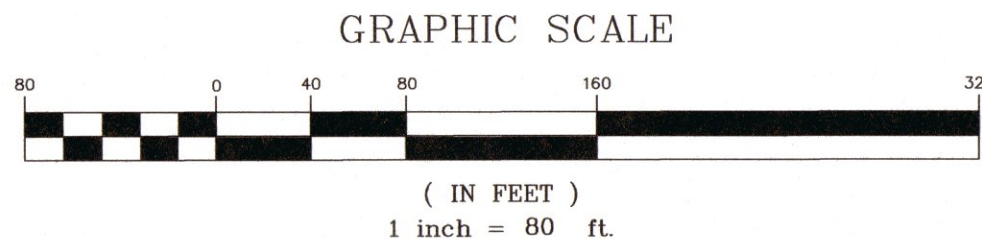

BLACKWELL & ASSOCIATES, Inc.
PROFESSIONAL LAND SURVEYORS & CIVIL ENGINEERS
20 TEASDALE CIRCLE
NANTUCKET, MASSACHUSETTS 02554
(508) 228-9026
www.blackwellsurvey.com

EXISTING CONDITIONS PLAN

NOBADEER REC FIELDS
prepared for:

WESTON & SAMPSON / TOWN of NANTUCKET
Nobadeer Farm Road, Nantucket, MA.

SCALE: 1"=80' DECEMBER 19, 2025

Design/Drawn by: LCA
Approved by: LCA

SHEET 1 OF 1 **B-8739.3**

Conservation
Restriction
7.6 ± AC.

LEGEND

- PROPERTY LINE
- **LOW** --- LIMIT OF WORK LINE (L.O.W.)
- SAWCUT
- SILT FENCE
- CONSTRUCTION FENCE
- ✕ R&D EXISTING TREES
- PROTECT EXISTING SITE FEATURE
- INLET SEDIMENT CONTROLS
- TEMPORARY CONSTRUCTION ENTRANCE
- TYP. TYPICAL
- EX. EXISTING
- R&D REMOVE AND DEMOLISH
- R&S REMOVE AND STOCKPILE
- P&P PRESERVE AND PROTECT
- R&D BITUMINOUS CONCRETE PAVING / ASPHALT & BASE MATERIAL, COMPLETE
- STRIP, SCREEN & STOCKPILE TOPSOIL (6" DEPTH)
- STRIP, SCREEN & STOCKPILE TOPSOIL (12" DEPTH)
- CLEAR & GRUB ALL EXISTING TREES, STUMPS, ROOTS & ALL DELETERIOUS MATERIAL. STRIP, SCREEN, AND STOCKPILE TOPSOIL FOR REUSE. CHIP & REMOVE ALL CLEARED TREES FROM THE SITE IMMEDIATELY.

GENERAL NOTES:

- ALL DRAINS WITHIN LIMIT OF WORK SHALL BE PROTECTED DURING CONSTRUCTION.
- CONTRACTOR IS RESPONSIBLE FOR DEWATERING DURING CONSTRUCTION IN ACCORDANCE WITH THE MASSACHUSETTS EROSION AND SEDIMENT CONTROL GUIDELINES.
- ALL EXISTING DRAINAGE STRUCTURES AND PIPING THAT RECEIVE RUNOFF FROM THE PROJECT OR THAT ARE DIRECTLY CONNECTED TO PROPOSED DRAINAGE FROM THE PROJECT SHALL BE INSPECTED AND CLEANED UPON PROJECT COMPLETION.
- NO HEAVY EQUIPMENT ALLOWED ON EXISTING LEACHFIELD AND SEPTIC TANKS. INSTALL CONSTRUCTION FENCING IN THESE AREAS.
- STRIP, STOCKPILE, AND PROTECT EXISTING TOPSOIL AT ALL AREAS OF IRRIGATION AND ELECTRICAL TRENCHING FOR REUSE.
- REMOVE AND SALVAGE EXISTING SIGNAGE ON SITE FOR REINSTALLATION. SOME SIGNAGE MAY NOT BE SHOWN ON THE SURVEY AND SHALL BE INCLUDED.
- FOR REMOVAL OF EXISTING ELECTRICAL LINES, REFER TO ELECTRICAL DRAWINGS

Project: TOWN OF NANTUCKET



NOBADEER ATHLETIC FIELDS
IMPROVEMENTS

7 NOBADEER FARM ROAD

Weston & Sampson

Weston & Sampson Engineers, Inc.
1 Washington Mall, 10th Floor
Boston, MA 02108

978.532.1900 800.SAMPSON

www.westonandsampson.com


Consultants:

Revisions:

No.	Date	Description

COA:

Seal:

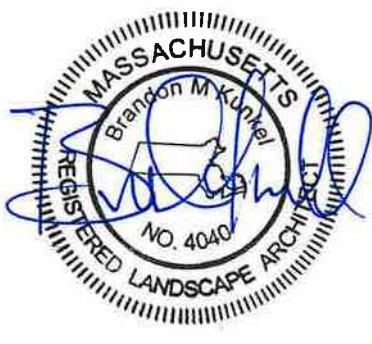

Issued For:

BID DOCUMENTS

Scale: AS NOTED

Date: AUGUST 7, 2026

Drawn By:

Reviewed By:

Approved By:

W&S Project No.: ENG24-1207

 

W&S File No.:

Drawing Title:

SITE
PREPARATION &
DEMOLITION PLAN

Sheet Number:

L200

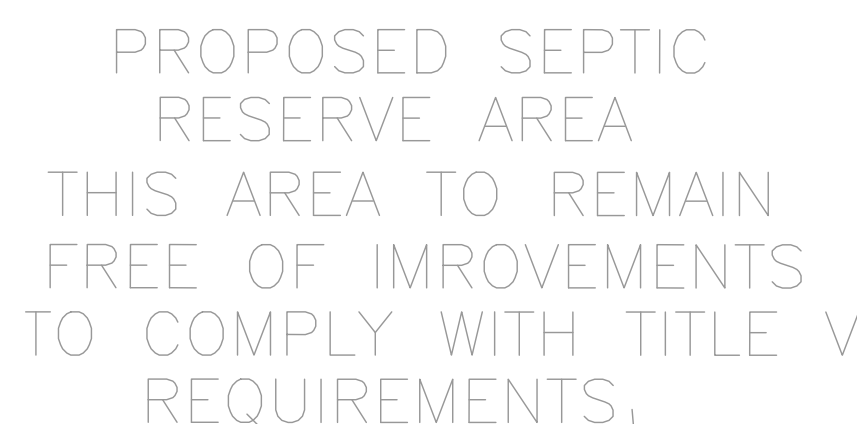

	PROPERTY LINE		INTEGRAL VERTICAL CONCRETE CURB	EQ	EQUAL
	LIMIT OF WORK LINE (L.O.W.)		VERTICAL PRECAST CONCRETE CURB	EJ	EXPANSION JOINT
	ENLARGEMENT		TRANSITION PRECAST CONCRETE CURB	HT.	HEIGHT
	CAST-IN-PLACE CONCRETE PAVEMENT		FLUSH PRECAST CONCRETE CURB	SJ	SCORE JOINT
	VEHICULAR ASPHALT PAVING		WOOD SPLIT RAIL FENCE	TCC	TRANSITION CONCRETE CURB
	SODDED ATHLETIC FIELD		TYP. DIMENSION	TYP.	TYPICAL
	LOAM AND SEED		TYP. ARC DIMENSION		
	PLAYGROUND INSTALLATION BY OTHERS		TYP. ANGLE DIMENSION		
	ATHLETIC FIELD LIGHT		TYP. RADIUS DIMENSION		

7 NOBADEER FARM ROAD

Weston & Sampson Engineers, Inc.
1 Washington Mall, 10th Floor
Boston, MA 02108

978.532.1900 800.SAMPSON

www.westonandsampson.com

Consultants

[illegible]

COA-

Seal:



Issued For:

BID DOCUMENTS

Scale: AS NOTED

Date: AUGUST 7, 2026

Drawn By:

Reviewed

Approved By:

W&S Project No.: ENG24-1207


W&S File No.:

Drawing Title:




LAYOUT & MATERIALS ENLARGEMENT


Sheet Number:


L301

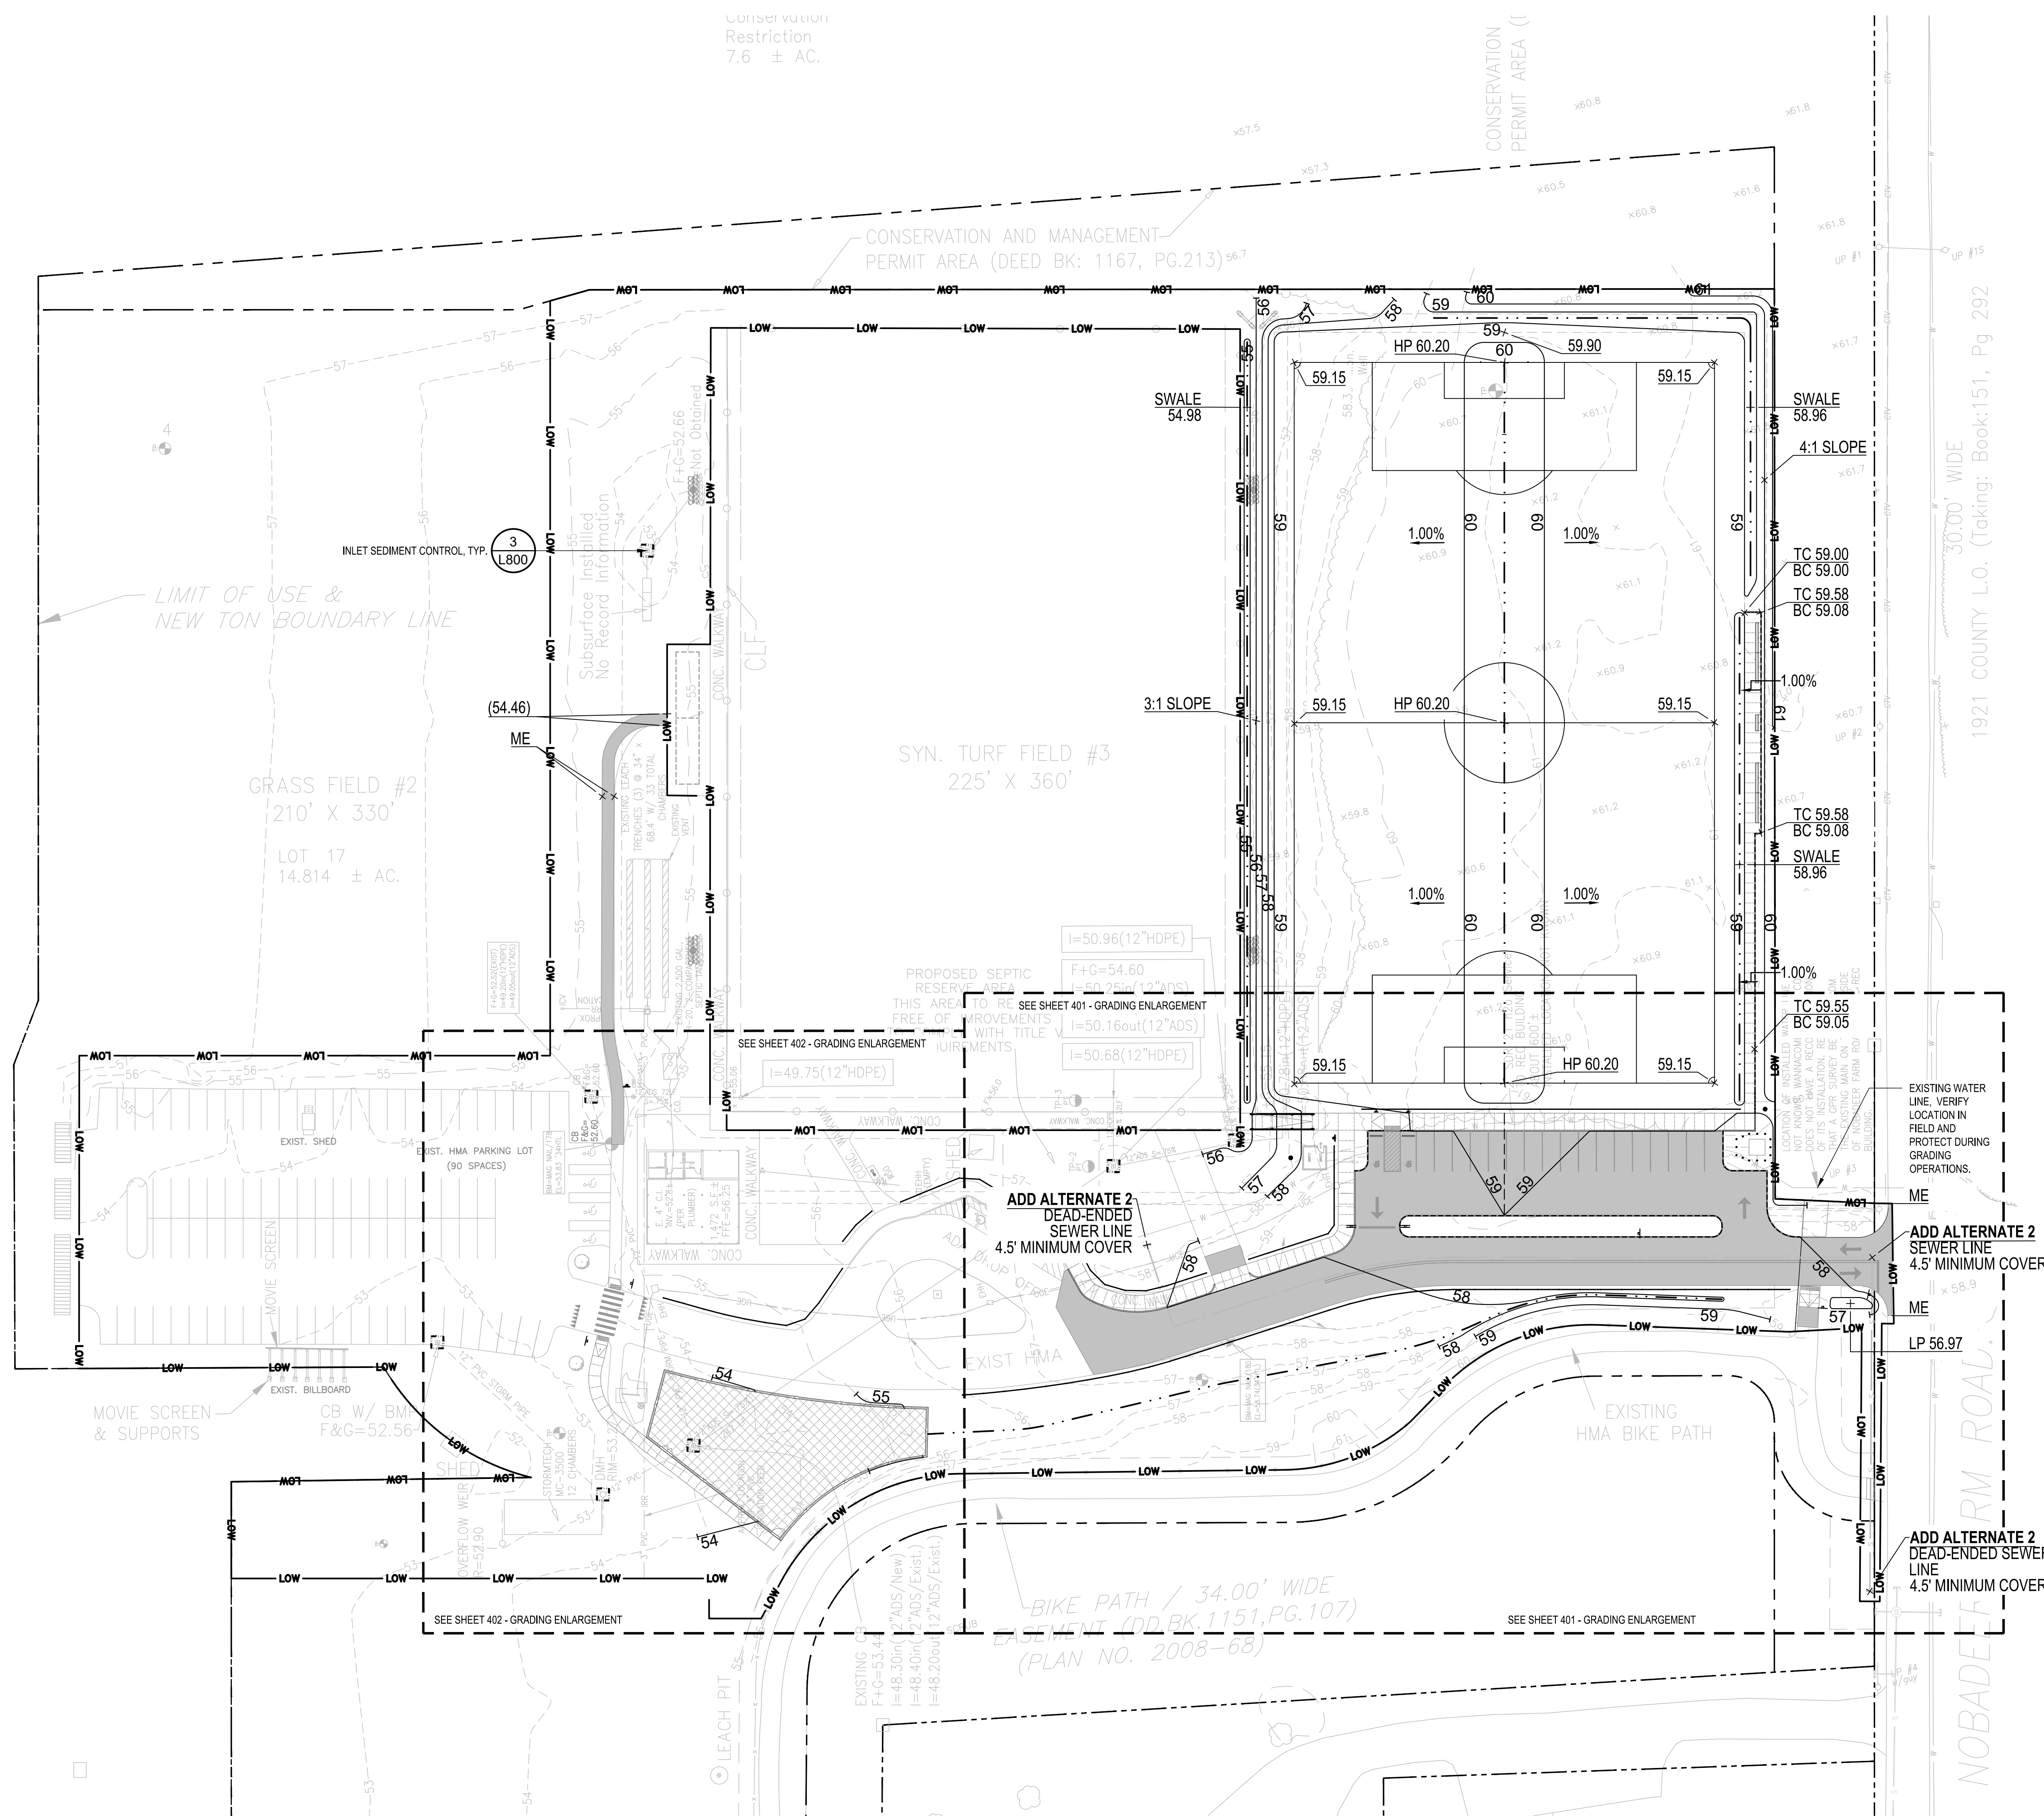

LEGEND

   	PROPERTY LINE
	LIMIT OF WORK LINE (L.O.W.)
	ENLARGEMENT
	PROPOSED MINOR CONTOUR
	PROPOSED MAJOR CONTOUR
	EXISTING MINOR CONTOUR
	EXISTING MAJOR CONTOUR
	EXISTING SPOT ELEVATION
	PROPOSED SPOT ELEVATION
	TOP & BOTTOM OF CURB
	SLOPE AND DIRECTION
BR	BOTTOM OF RAMP
TR	TOP OF RAMP
ME	MATCH EXISTING GRADE, FLUSH
	INLET SEDIMENT CONTROL

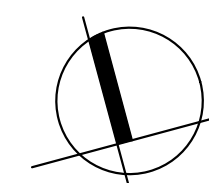

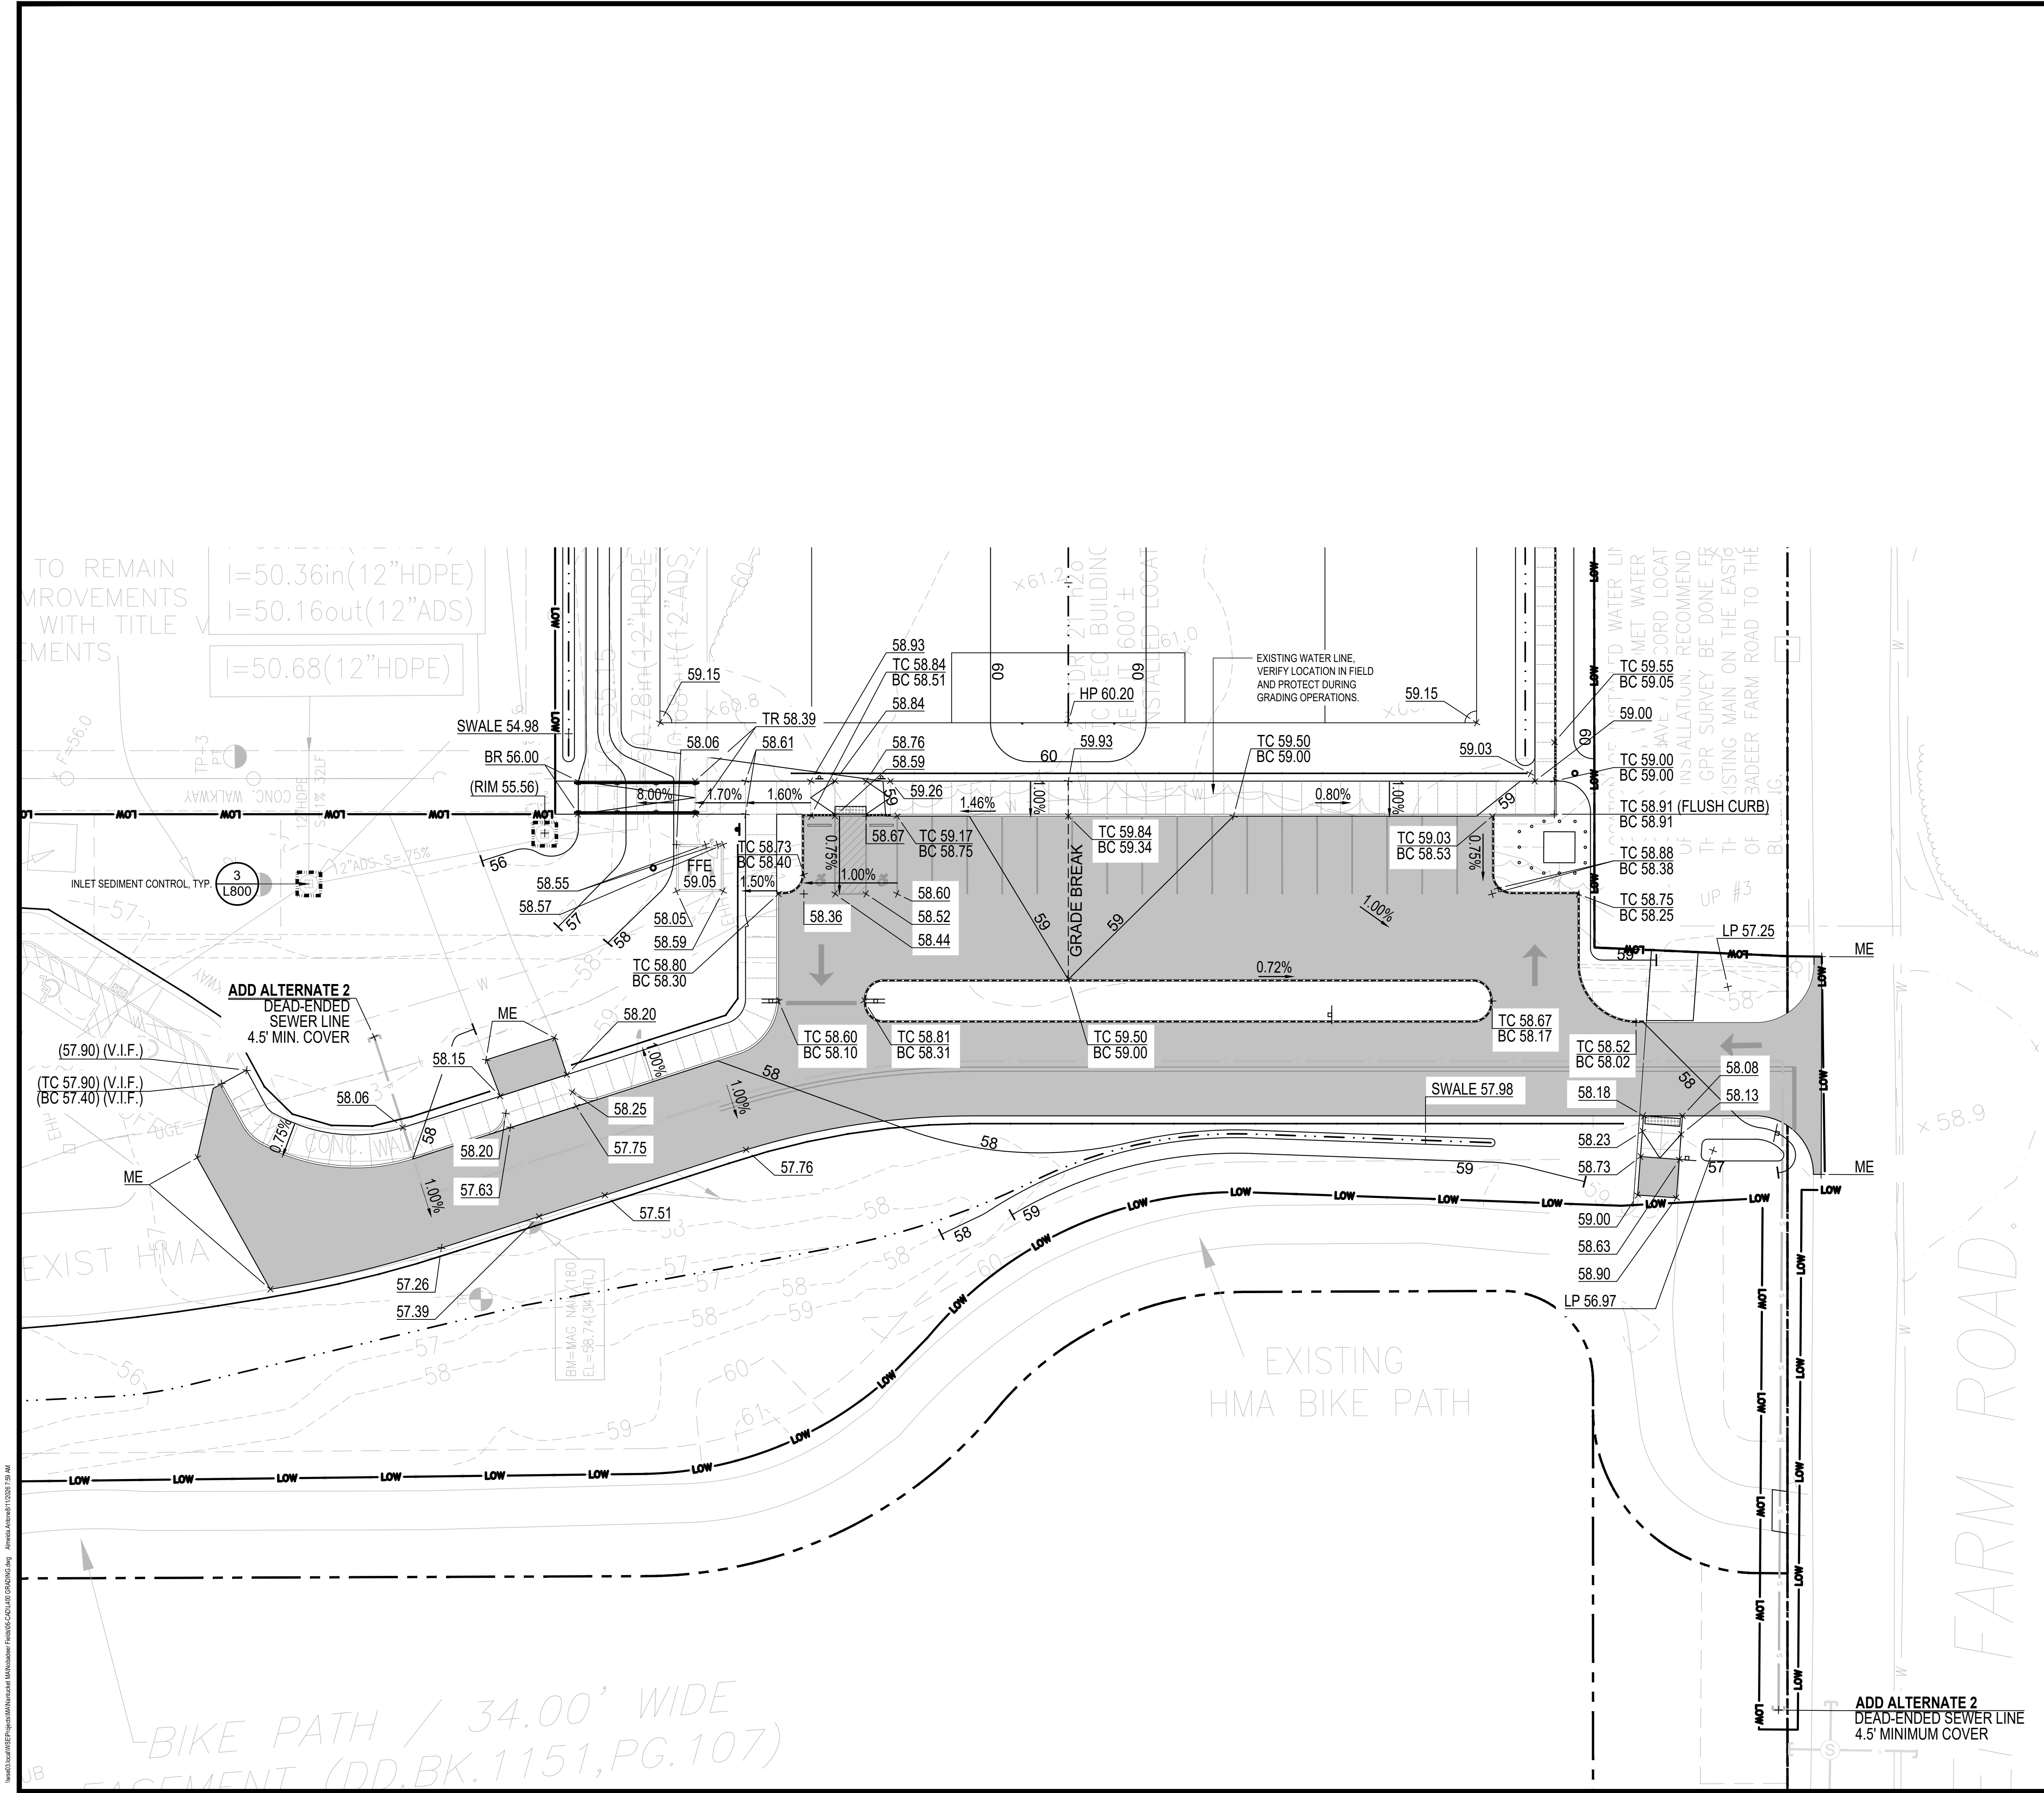

LEGEND

- PROPERTY LINE
- LOW — LIMIT OF WORK LINE (L.O.W.)
- 2 — PROPOSED MINOR CONTOUR
- 10 — PROPOSED MAJOR CONTOUR
- - - 2 - - - EXISTING MINOR CONTOUR
- - - 10 - - - EXISTING MAJOR CONTOUR
- x 50.00 EXISTING SPOT ELEVATION
- + 50.00 PROPOSED SPOT ELEVATION
- TC 50.50
BC 50.00 TOP & BOTTOM OF CURB
- 2% SLOPE AND DIRECTION
- BR BOTTOM OF RAMP
- TR TOP OF RAMP
- ME MATCH EXISTING GRADE FLUSH
- INLET SEDIMENT CONTROL

NOTE:
ADD ALTERNATE 2
SEWER LINES ARE GENERALLY DESIGNED WITH A MINIMUM OF 5 FEET OF COVER. WHERE A 4.5-FOOT MINIMUM COVER IS SHOWN, THIS CONDITION IS PROVIDED AT THE DIRECTION OF THE TOWN OF NANTUCKET DUE TO SITE SOIL CONDITIONS AND SHALL BE ACCEPTED BY THE AUTHORITY HAVING JURISDICTION.

Project: TOWN OF NANTUCKET



NOBADEER ATHLETIC FIELDS IMPROVEMENTS
7 NOBADEER FARM ROAD

Weston & Sampson

Weston & Sampson Engineers, Inc.
1 Washington Mall, 10th Floor
Boston, MA 02108
978.532.1900 800.SAMPSON
www.westonandsampson.com

Consultants:

Revisions:

No.	Date	Description

COA:

Seal:



Issued For:

BID DOCUMENTS

Scale: AS NOTED

Date: AUGUST 7, 2026

Drawn By:

Reviewed By:

Approved By:

W&S Project No.: ENG24-1207

 
W&S File No.:

Drawing Title:

GRADING ENLARGEMENT

Sheet Number:

L401

	EXISTING SPOT ELEVATION
	PROPOSED SPOT ELEVATION
	TOP & BOTTOM OF CURB
	SLOPE AND DIRECTION
	BOTTOM OF RAMP
	TOP OF RAMP
	MATCH EXISTING GRADE FLUSH
	INLET SEDIMENT CONTROL

Weston & SampsonSM
Weston & Sampson Engineers, Inc.
1 Washington Mall, 10th Floor
Boston, MA 02108
978.532.1900 800.SAMPSON
www.westonandsampson.com

COA:	
------	--


Issued For:

BID DOCUMENTS

Date:	AUGUST 7, 2026
Drawn By:	
Reviewed By:	
Approved By:	
W&S Project No.: ENG24-1207	
W&S File No.:	

Sheet Number:

L402

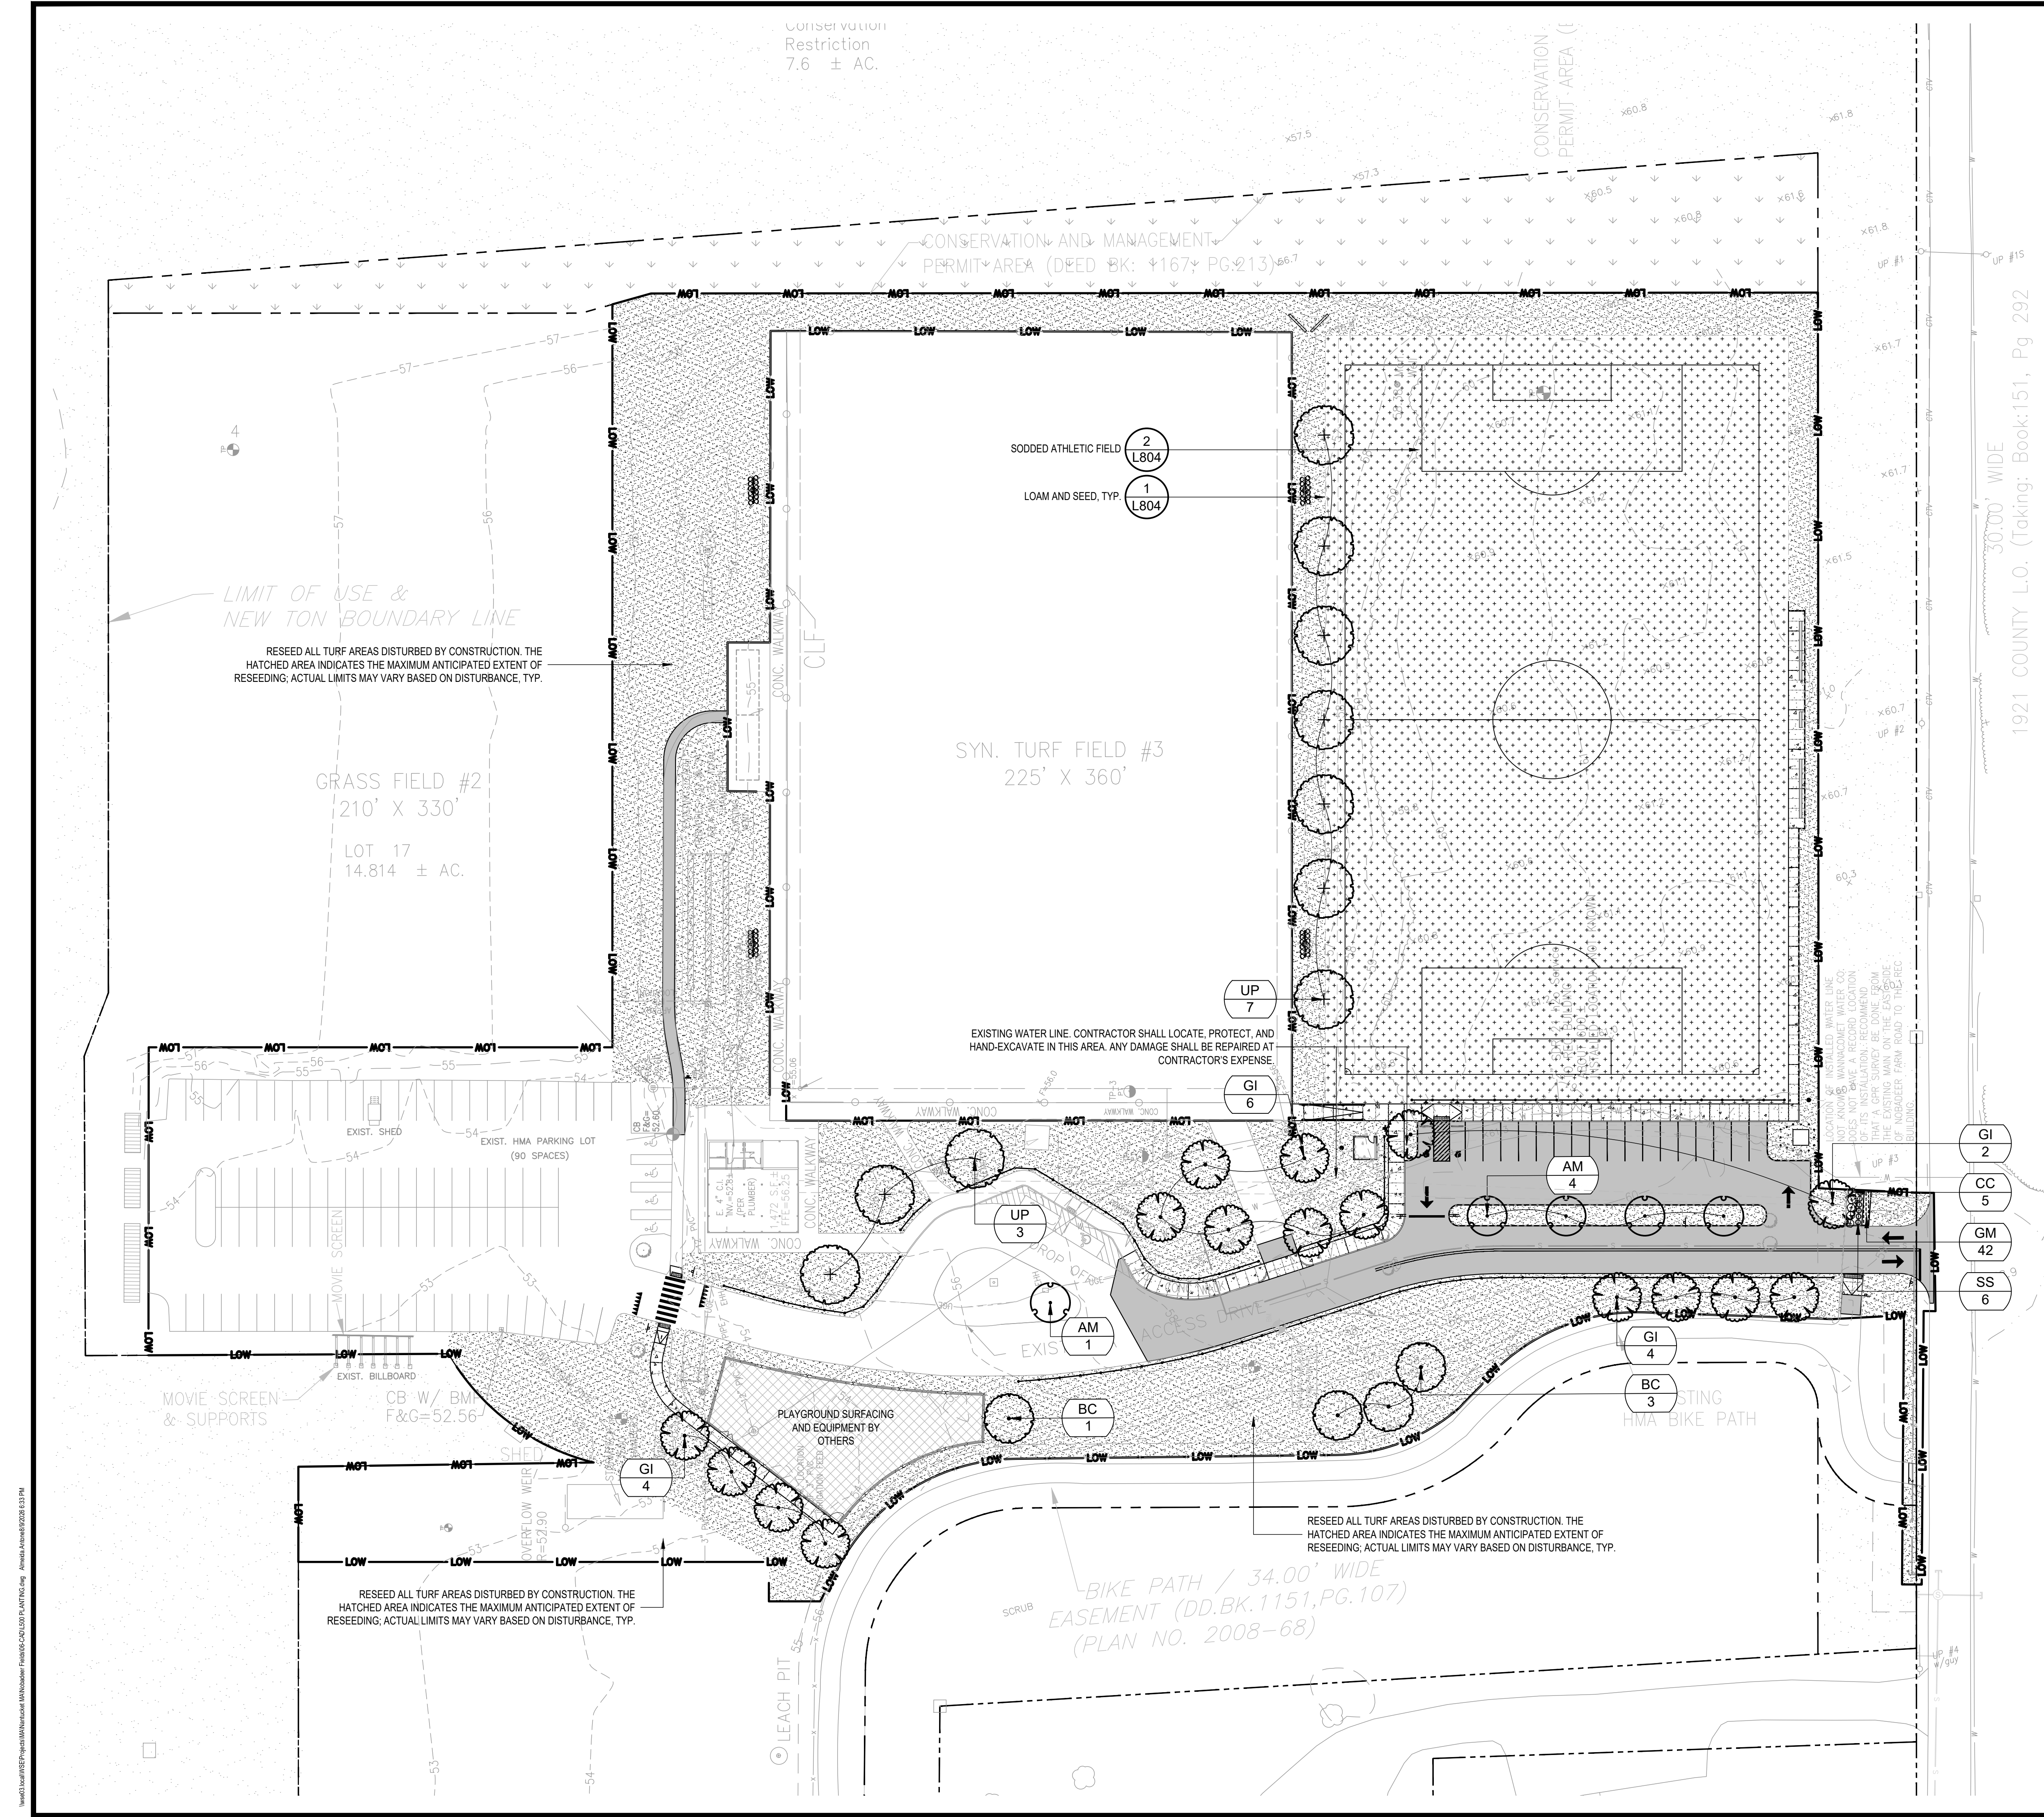

PLANT SCHEDULE

SYMBOL	CODE	BOTANICAL NAME	COMMON NAME	SIZE	CONTAINER	QTY	DETAIL	REMARKS	
TREES									
	AM	AMELANCHIER CANADENSIS	CANADIAN SERVICEBERRY MULTI-TRUNK	2.5-3" CAL	B&B	5			
	BC	BETULA NIGRA 'CULLY'	HERITAGE® RIVER BIRCH	6`-7` HT.	B&B	4		SINGLE STEM	
	GI	GLEDTISIA TRIACANTHOS INERMIS `SKYCOLE`	SKYLINE® HONEY LOCUST	2.5-3" CAL	B&B	16			
	UP	ULMUS AMERICANA `PRINCETON`	PRINCETON AMERICAN ELM	2.5-3" CAL	B&B	10			
SHRUBS									
	CC	CLETHRA ALNIFOLIA `CALEB`	VANILLA SPICE® SUMMERSWEET	#3	CONTAINER	5			
	SS	SCHIZACHYRIUM SCOPARIUM	LITTLE BLUESTEM	12'-24" HT.	#1	6			
SYMBOL	CODE	BOTANICAL NAME	COMMON NAME	SIZE	CONTAINER	SPACING	QTY	DETAIL	REMARKS
GROUND COVERS									
	GM	GERANIUM MACULATUM	SPOTTED GERANIUM	FLAT		15" o.c.	42		

D:\wz03\local\NISE\Projects\MA\Narrucket MA\Notaboeer Fields 06-CAD\LS10 PLANTING.dwg Arredas Arredas 8/19/2026 6:33 PM

Project: TOWN OF NANTUCKET



NOBADEER ATHLETIC FIELDS IMPROVEMENTS

7 NOBADEER FARM ROAD



Weston & Sampson Engineers, Inc.
1 Washington Mall, 10th Floor
Boston, MA 02108
978.532.1900 800.SAMPSON
www.westonandsampson.com

Consultants

[illegible]

COA:



Issued For:

BID DOCUMENTS

Scale: AS NOTED

Date: AUGUST 7, 2021

Drawn By:

Reviewed By:

Approved By:

W&S Project No.: ENG24-1207

W&S File No.


Drawing Title:

PLANT SCHEDULE

Sheet Number:

L501



© 2025 IRRIGATION CONSULTING, INC. ALL RIGHTS RESERVED. THIS DRAWING IS THE PROPERTY OF IRRIGATION CONSULTING, INC. AND IS NOT TO BE REPRODUCED, COPIED, OR TRANSMITTED IN ANY FORM OR BY ANY MEANS, WITHOUT THE WRITTEN PERMISSION OF IRRIGATION CONSULTING, INC.

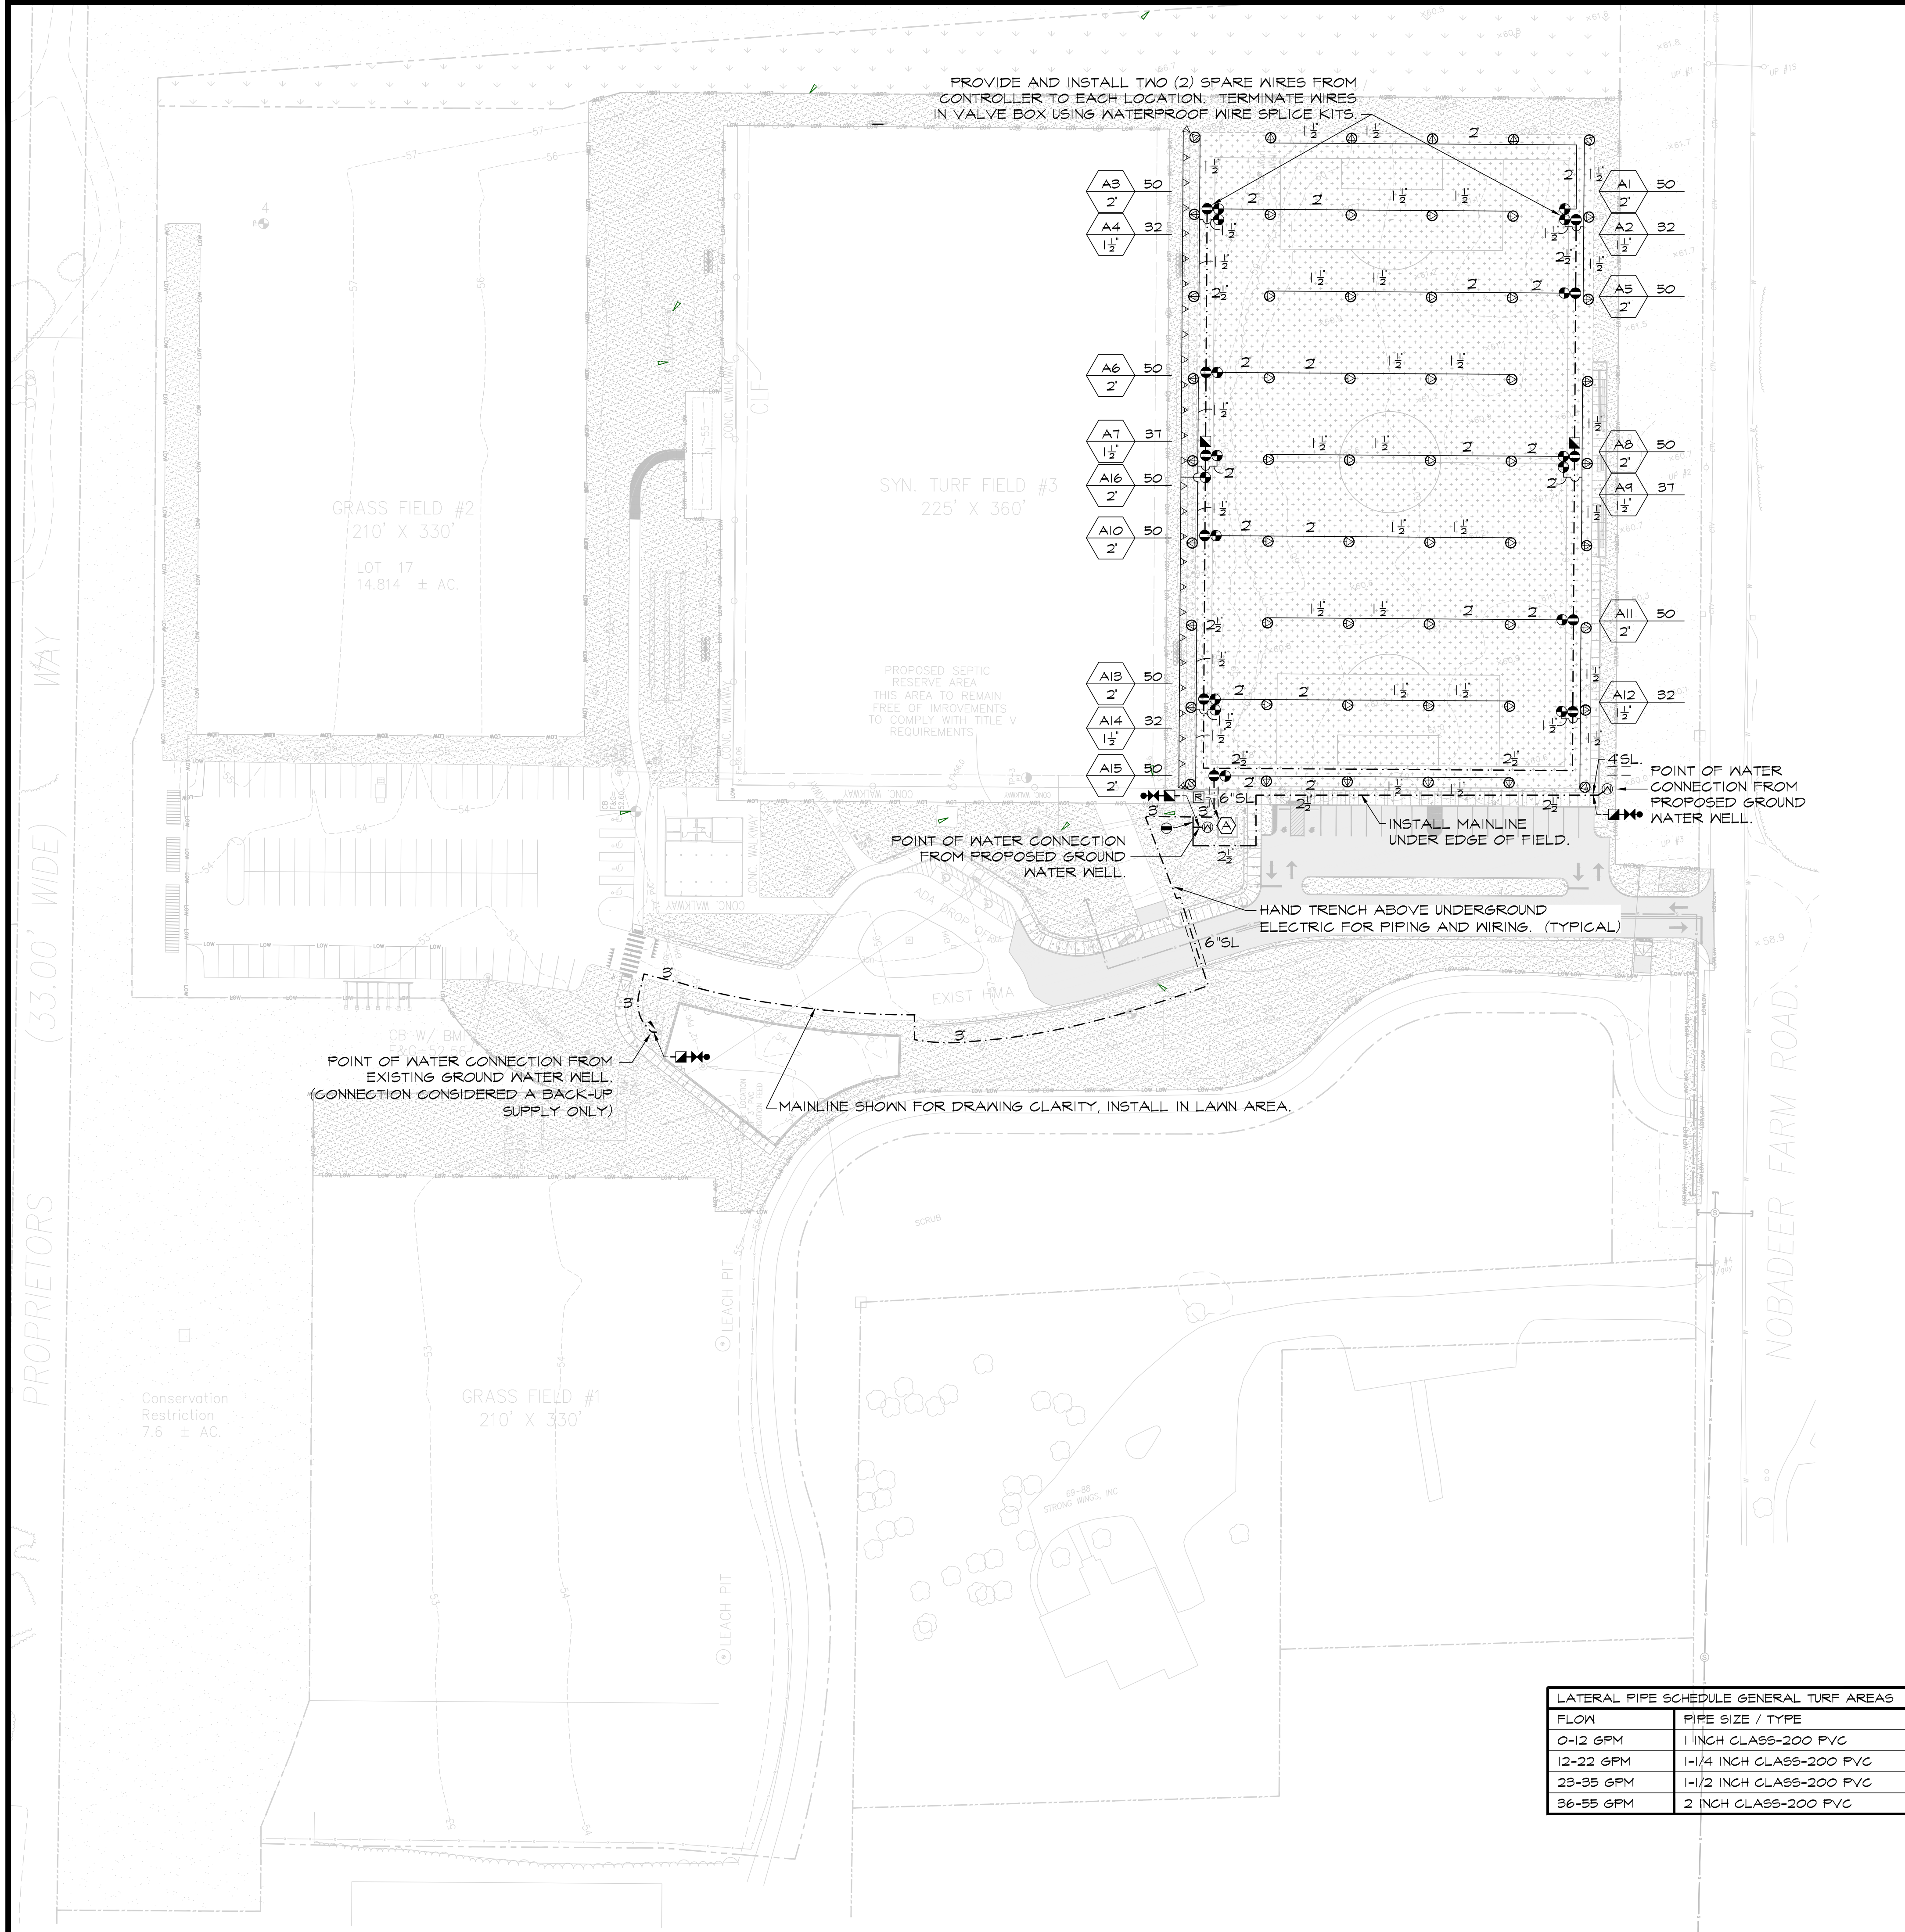

LATERAL PIPE SCHEDULE GENERAL TURF AREAS	
FLOW	PIPE SIZE / TYPE
0-12 GPM	1 INCH CLASS-200 PVC
12-22 GPM	1-1/4 INCH CLASS-200 PVC
23-35 GPM	1-1/2 INCH CLASS-200 PVC
36-55 GPM	2 INCH CLASS-200 PVC

IRRIGATION LEGEND			
SYMBOL	PSI	SPACING	DESCRIPTION
	60	50'	ROTARY SPRINKLER WITH CHECK VALVE (STANDARD NOZZLES)
	50	35'	MEDIUM ROTARY SPRINKLER WITH CHECK VALVE (STANDARD NOZZLES)
	40	25'	6-INCH POP UP SPRAY SPRINKLER WITH CHECK VALVE AND PRESSURE REGULATION
	30	15'	6-INCH POP UP SPRAY SPRINKLER WITH CHECK VALVE AND PRESSURE REGULATION
	30	12'	6-INCH POP UP SPRAY SPRINKLER WITH CHECK VALVE AND PRESSURE REGULATION
	30	10'	6-INCH POP UP SPRAY SPRINKLER WITH CHECK VALVE AND PRESSURE REGULATION
	30	8'	6-INCH POP UP SPRAY SPRINKLER WITH CHECK VALVE AND PRESSURE REGULATION
	30	5'	6-INCH POP UP SPRAY SPRINKLER WITH CHECK VALVE AND PRESSURE REGULATION
	30	4'x30'	6-INCH POP UP SPRAY SPRINKLER WITH CHECK VALVE AND PRESSURE REGULATION
			24 VOLT ELECTRIC ZONE VALVE (SEE VALVE DESIGNATOR FOR FLOW AND SIZES)
			2-1/2" ISOLATION GATE VALVE
			BRONZE ISOLATION VALVE FOR CONTROL VALVES
			1" QUICK COUPLING VALVE
			2" MASTER VALVE AND FLOW SENSOR
			CLASS-200 PVC LATERAL PIPING (SIZE AS INDICATED FOR SOCCER FIELD) (SEE LATERAL PIPE SCHEDULE SIZES FOR GENERAL TURF AREAS)
			CLASS-200 PVC MAINLINE PIPING
			CLASS-200 PVC PIPE SLEEVE (SIZE AS INDICATED) INSTALL SCH-40 PVC WIRE CONDUIT ADJACENT TO MAINLINE PIPE SLEEVES. MINIMUM WIRE CONDUIT SIZE TO BE 2-INCH. SEE SLEEVING DETAIL.
			AUTOMATIC RAIN SENSOR
			AUTOMATIC CONTROLLER
			EXISTING GROUNDWATER WELL (BACK-UP, 100 GPM)
			PROPOSED GROUNDWATER WELL (TWO LOCATIONS) (+/- 50 GPM EACH)
VALVE DESIGNATION:			
	STATION NO.		
	40 ← FLOW		
	VALVE SIZE		

- IRRIGATION NOTES
- COORDINATE FINAL LOCATION OF SPRINKLERS AND NOZZLE SELECTION WITH FINAL APPROVED SOCCER FIELD LAYOUT AND GENERAL TURF AREAS.
 - PIPE AND VALVE LOCATIONS ARE DIAGRAMMATIC, CONTRACTOR SHALL FIELD VERIFY.
 - VALVES AND VALVE BOXES FOR SOCCER FIELD SHALL BE PLACED AWAY FROM PLAYING SURFACE.
 - CONTROL WIRE SHALL BE #14 GAUGE SINGLE STRAND, RED FOR TURF ZONES. COMMON WIRE SHALL BE #14 GAUGE SINGLE STRAND WHITE AND SPARE WIRES, INSTALLED WHERE SHOWN, SHALL BE #14 GAUGE SINGLE STRAND BLUE.
 - QUICK COUPLING VALVES SHALL BE INSTALLED ON 1 INCH PVC SWING JOINTS WITH BRASS INSERTS AND STABILIZERS. (SEE DETAIL)
 - SPRAY AND MEDIUM ROTARY SPRINKLERS SHALL BE INSTALLED ON SWING PIPE ASSEMBLIES, MINIMUM LENGTH TO BE 6 INCHES, 18 INCH MAXIMUM. LARGE ROTARY SPRINKLERS SHALL BE INSTALLED ON 1-INCH PVC PREFABRICATED UNITIZED SWING JOINT ASSEMBLIES WITH INTEGRAL O-RINGS.
 - IRRIGATION SYSTEM IS DESIGNED FOR SEPARATE WATER SUPPLY TO PROVIDE 100 GPM MAX EACH FROM ONE EXISTING AND TWO PROPOSED GROUND WATER WELL SERVICES. SYSTEM TO PRODUCE 80-PSI DYNAMIC PRESSURE AT IRRIGATION CONTRACTOR'S POINT OF CONNECTION IN LANDSCAPED AREA.
 - CONTRACTOR SHALL TEST DYNAMIC PRESSURE BEFORE STARTING WORK, REPORT ANY DEVIATION FROM PRESSURE REQUIRED TO OWNER'S REPRESENTATIVE BEFORE CONTINUING.
 - INSTALL CONTROLLER IN IRRIGATION CONTROL SHED AS DIRECTED BY OWNER'S REPRESENTATIVE, HARD WIRE TO 120 VOLT, DEDICATED 20 AMP CIRCUIT, BUILDING POWER SUPPLY USING LICENSED ELECTRICIAN. ROUTE TWO-WIRE COMMUNICATION CABLES TO CONTROLLER VIA 3-INCH CONDUIT.
 - INSTALL WIRELESS RAIN SENSOR ON EXTERIOR IRRIGATION CONTROL SHED WALL WHERE DIRECTED BY OWNER'S REPRESENTATIVE. INSTALL WIRELESS RECEIVER NEXT TO CONTROLLER.
 - ABOVE GROUND WIRING, INSIDE AND OUTSIDE OF BUILDING, SHALL BE INSTALLED IN RIGID, METALLIC CONDUIT FOR VANDALISM PROTECTION.
 - COORDINATE LOCATION OF EXISTING AND FUTURE UTILITIES ON SITE AND CONTACT PROPER AUTHORITIES AND UTILITY COMPANIES BEFORE THE START OF WORK.
 - CONTRACTOR MUST SUBMIT SHOP PRODUCT DRAWINGS AS PER THE WRITTEN SPECIFICATIONS TO THE IRRIGATION CONSULTANT FOR APPROVAL PRIOR TO ORDERING MATERIAL AND BEGINNING WORK.
 - ANY AND ALL MATERIAL SUBSTITUTIONS WHICH VARY FROM THE SPECIFIED PRODUCTS MUST BE SUBMITTED TO THE IRRIGATION CONSULTANT FOR APPROVAL AS PART OF THE SUBMITTAL PROCESS.
 - ONCE APPROVED SUBMITTALS HAVE BEEN RETURNED TO THE CONTRACTOR, WORK MAY BEGIN. THE IRRIGATION CONSULTANT MUST BE NOTIFIED A MINIMUM OF 7-DAYS IN ADVANCE OF THE START OF WORK TO COORDINATE ON-SITE SUPERVISION AND ADMINISTRATION.
 - SEE IRRIGATION DETAILS AND SPECIFICATIONS SECTION FOR ADDITIONAL NECESSARY INFORMATION.

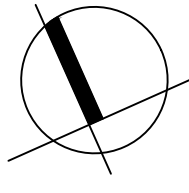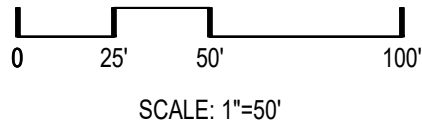

Project: TOWN OF NANTUCKET




NOBADER ATHLETIC FIELDS IMPROVEMENTS

7 NOBADER FARM ROAD

Weston & Sampson

Weston & Sampson Engineers, Inc.
1 Washington Mall, 10th Floor
Boston, MA 02108
978.532.1900 800.SAMPSON
www.westonandsampson.com

Consultants:

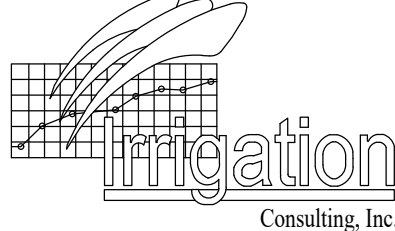

Providing innovative design solutions for irrigation worldwide.

— 20 Merritt Parkway
Nashua, NH 03062
(603) 883-9412

— 14501 S. Old Statesville Rd., Suite 104
Huntersville, NC 28078
(704) 843-3688

www.irrigationconsulting.com

Revisions:

No.	Date	Description

COA:

Seal:

Issued For:

BID DOCUMENTS

Scale: AS NOTED

Date: AUGUST 7, 2026

Drawn By: GD

Reviewed By: JB

Approved By: JB

W&S Project No.: ENG24-1207

W&S File No.: ---


Drawing Title:


 

 
 
 
 
 
 
 
 
 
 
IRRIGATION PLAN BASE

Sheet Number:

L700

COPYRIGHT © 2026 WESTON & SAMPSON, INC.

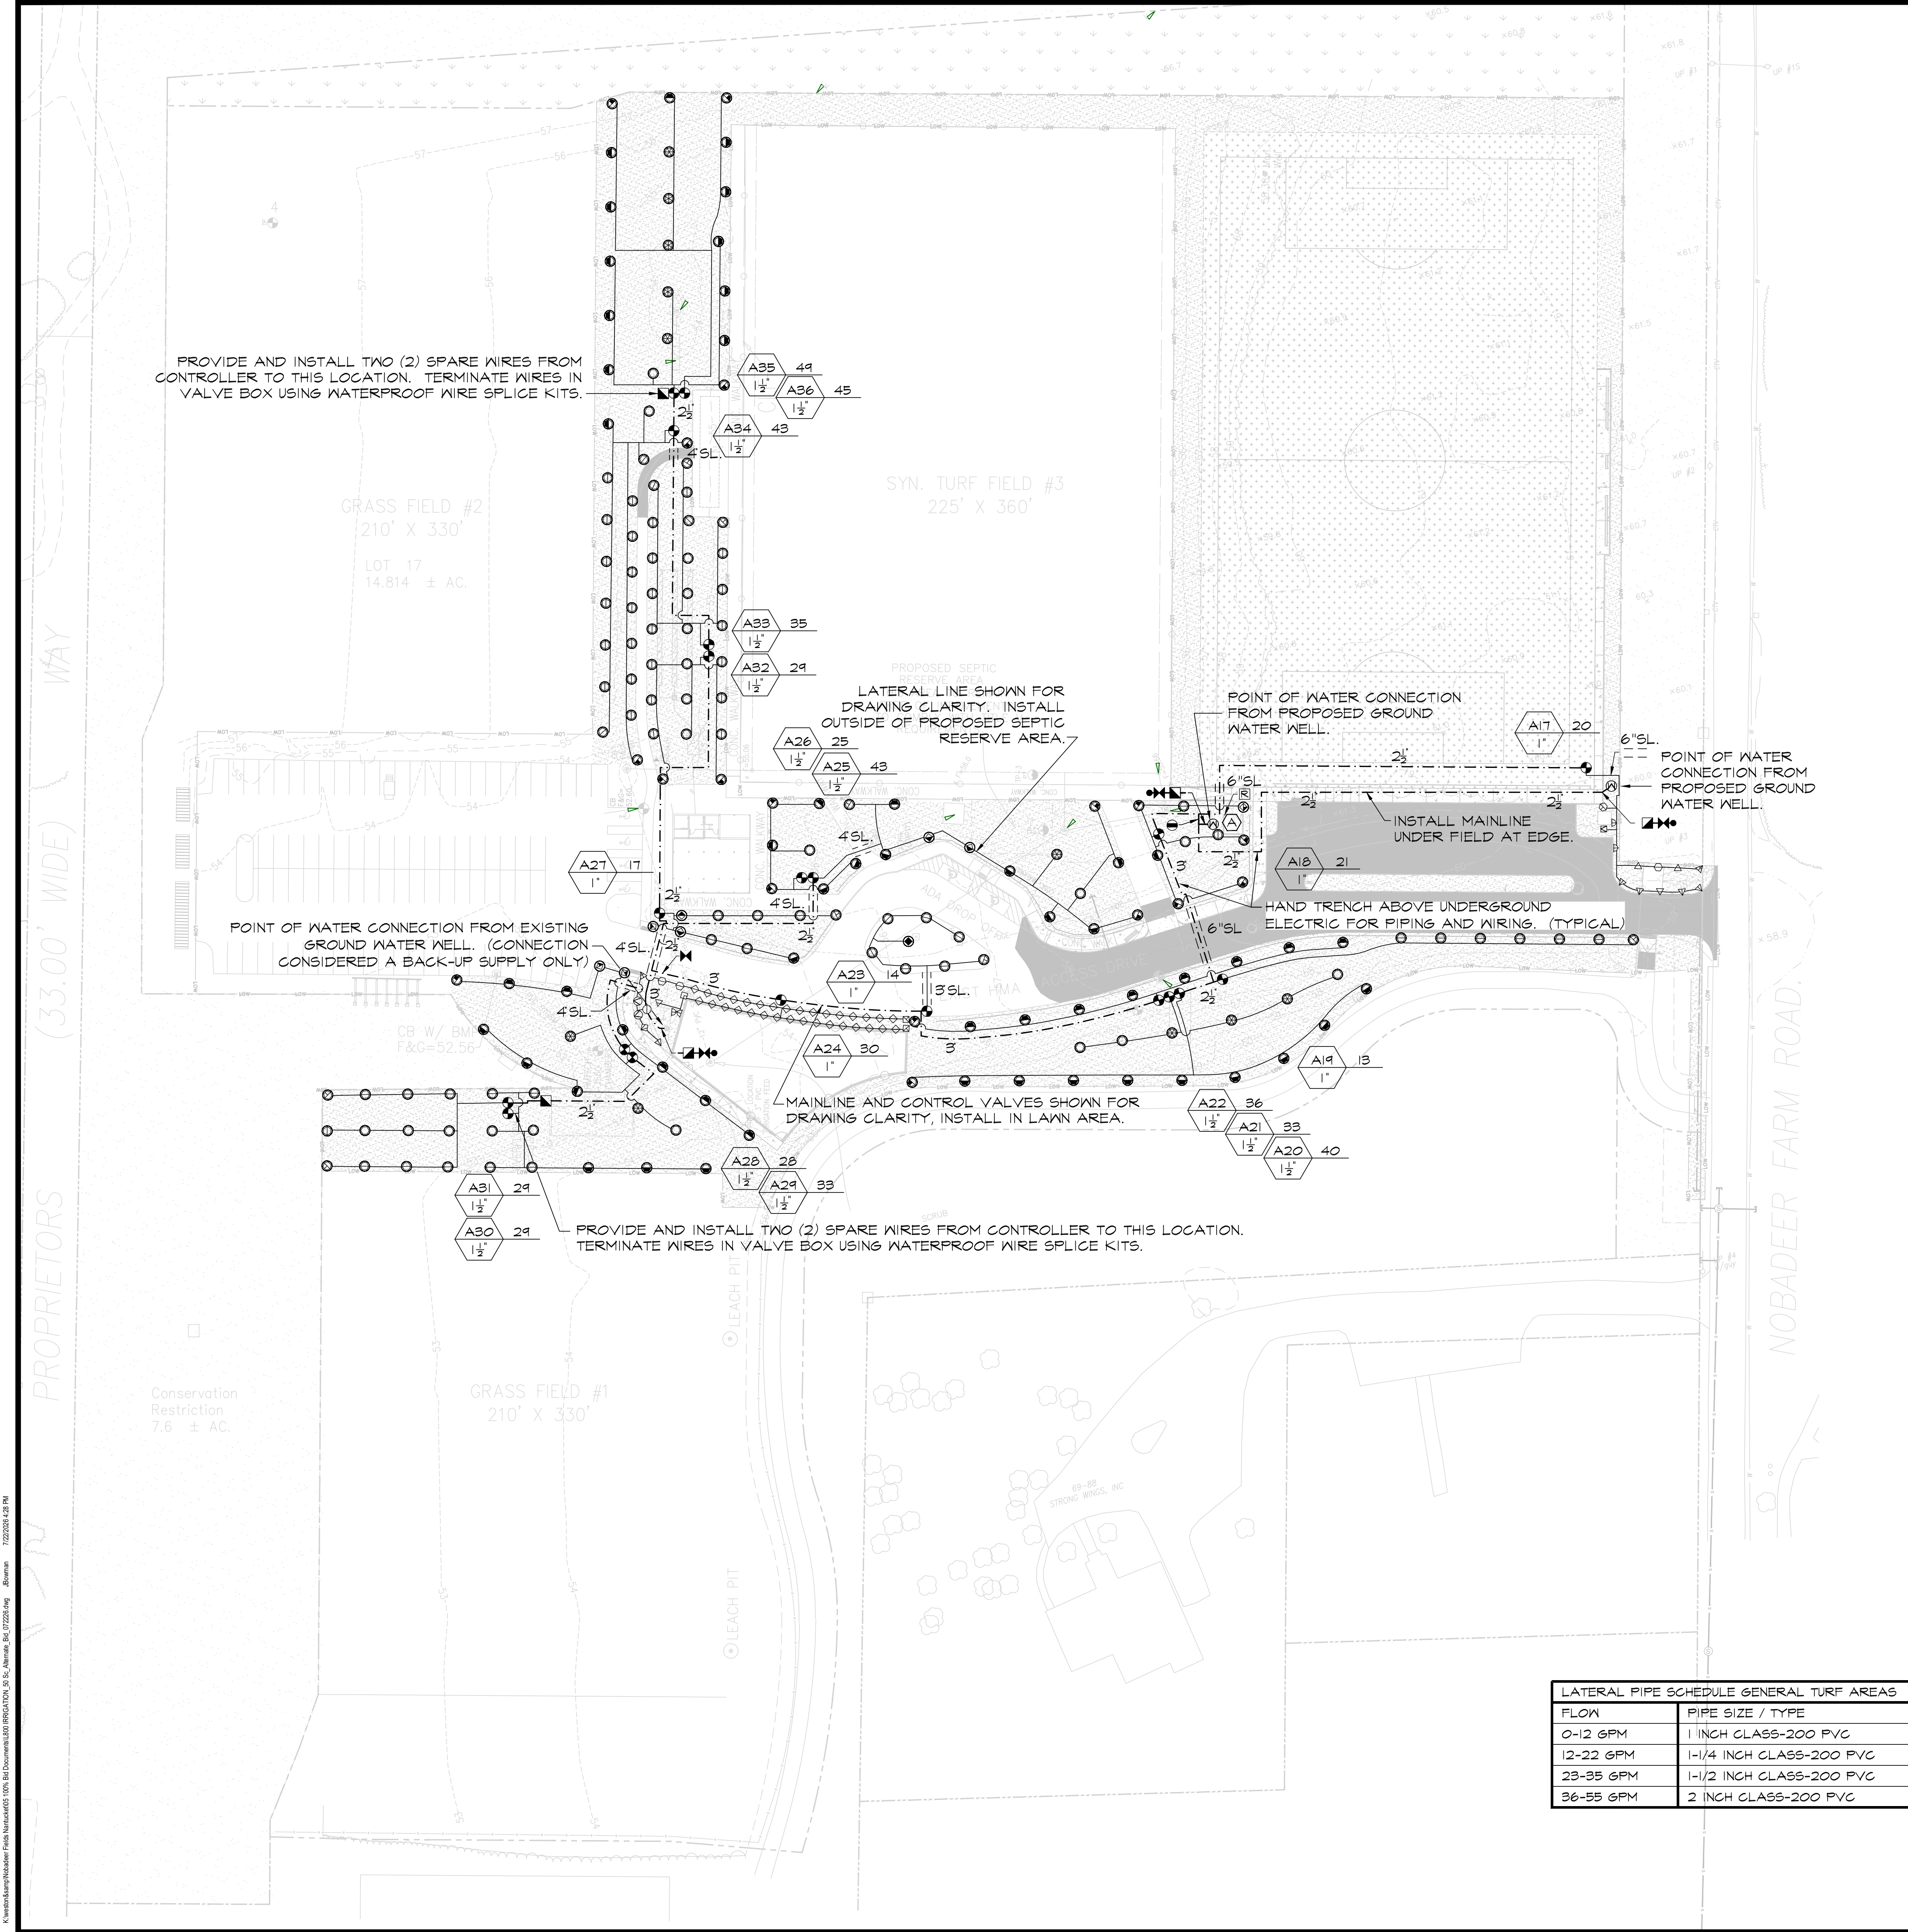

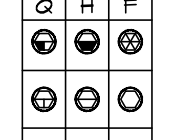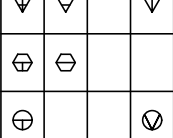IRRIGATION LEGEND			
SYMBOL	PSI	SPACING	DESCRIPTION
	60	50'	ROTARY SPRINKLER WITH CHECK VALVE (STANDARD NOZZLES)
	50	35'	MEDIUM ROTARY SPRINKLER WITH CHECK VALVE (STANDARD NOZZLES)
	50	25'	
	40	18'	
	30	15'	6-INCH POP UP SPRAY SPRINKLER WITH CHECK VALVE AND PRESSURE REGULATION
	30	12'	
	30	10'	
	30	8'	
	30	5'	
		4'x30'	24 VOLT ELECTRIC ZONE VALVE (SEE VALVE DESIGNATOR FOR FLOW AND SIZES)
			2-1/2" ISOLATION GATE VALVE
			BRONZE ISOLATION VALVE FOR CONTROL VALVES
			1" QUICK COUPLING VALVE
			2" MASTER VALVE AND FLOW SENSOR
			CLASS-200 PVC LATERAL PIPING (SIZE AS INDICATED FOR SOCCER FIELD) (SEE LATERAL PIPE SCHEDULE SIZES FOR GENERAL TURF AREAS)
			CLASS-200 PVC MAINLINE PIPING
			CLASS-200 PVC PIPE SLEEVE (SIZE AS INDICATED) INSTALL SCH-40 PVC WIRE CONDUIT ADJACENT TO MAINLINE PIPE SLEEVES. MINIMUM WIRE CONDUIT SIZE TO BE 2-INCH. SEE SLEEVING DETAIL.
			AUTOMATIC RAIN SENSOR
			AUTOMATIC CONTROLLER
			EXISTING GROUNDWATER WELL (BACK-UP, 100 GPM)
			PROPOSED GROUNDWATER WELL (TWO LOCATIONS) (+/- 50 GPM EACH)
VALVE DESIGNATION:			
	STATION NO.		
	40 ← FLOW		
	VALVE SIZE		

- IRRIGATION NOTES
- COORDINATE FINAL LOCATION OF SPRINKLERS AND NOZZLE SELECTION WITH FINAL APPROVED SOCCER FIELD LAYOUT AND GENERAL TURF AREAS.
 - PIPE AND VALVE LOCATIONS ARE DIAGRAMMATIC, CONTRACTOR SHALL FIELD VERIFY.
 - VALVES AND VALVE BOXES FOR SOCCER FIELD SHALL BE PLACED AWAY FROM PLAYING SURFACE.
 - CONTROL WIRE SHALL BE #14 GAUGE SINGLE STRAND, RED FOR TURF ZONES. COMMON WIRE SHALL BE #14 GAUGE SINGLE STRAND WHITE AND SPARE WIRES, INSTALLED WHERE SHOWN, SHALL BE #14 GAUGE SINGLE STRAND BLUE.
 - QUICK COUPLING VALVES SHALL BE INSTALLED ON 1 INCH PVC SWING JOINTS WITH BRASS INSERTS AND STABILIZERS. (SEE DETAIL)
 - SPRAY AND MEDIUM ROTARY SPRINKLERS SHALL BE INSTALLED ON SWING PIPE ASSEMBLIES, MINIMUM LENGTH TO BE 6 INCHES, 18 INCH MAXIMUM. LARGE ROTARY SPRINKLERS SHALL BE INSTALLED ON 1-INCH PVC PREFABRICATED UNITIZED SWING JOINT ASSEMBLIES WITH INTEGRAL O-RINGS.
 - IRRIGATION SYSTEM IS DESIGNED FOR SEPARATE WATER SUPPLY TO PROVIDE 100 GPM MAX EACH FROM ONE EXISTING AND TWO PROPOSED GROUND WATER WELL SERVICES. SYSTEM TO PRODUCE 80-PSI DYNAMIC PRESSURE AT IRRIGATION CONTRACTOR'S POINT OF CONNECTION IN LANDSCAPED AREA.
 - CONTRACTOR SHALL TEST DYNAMIC PRESSURE BEFORE STARTING WORK, REPORT ANY DEVIATION FROM PRESSURE REQUIRED TO OWNER'S REPRESENTATIVE BEFORE CONTINUING.
 - INSTALL CONTROLLER IN IRRIGATION CONTROL SHED AS DIRECTED BY OWNER'S REPRESENTATIVE, HARD WIRE TO 120 VOLT, DEDICATED 20 AMP CIRCUIT, BUILDING POWER SUPPLY USING LICENSED ELECTRICIAN. ROUTE TWO-WIRE COMMUNICATION CABLES TO CONTROLLER VIA 3-INCH CONDUIT.
 - INSTALL WIRELESS RAIN SENSOR ON EXTERIOR IRRIGATION CONTROL SHED WALL WHERE DIRECTED BY OWNER'S REPRESENTATIVE. INSTALL WIRELESS RECEIVER NEXT TO CONTROLLER.
 - ABOVE GROUND WIRING, INSIDE AND OUTSIDE OF BUILDING, SHALL BE INSTALLED IN RIGID, METALLIC CONDUIT FOR VANDALISM PROTECTION.
 - COORDINATE LOCATION OF EXISTING AND FUTURE UTILITIES ON SITE AND CONTACT PROPER AUTHORITIES AND UTILITY COMPANIES BEFORE THE START OF WORK.
 - CONTRACTOR MUST SUBMIT SHOP PRODUCT DRAWINGS AS PER THE WRITTEN SPECIFICATIONS TO THE IRRIGATION CONSULTANT FOR APPROVAL PRIOR TO ORDERING MATERIAL AND BEGINNING WORK.
 - ANY AND ALL MATERIAL SUBSTITUTIONS WHICH VARY FROM THE SPECIFIED PRODUCTS MUST BE SUBMITTED TO THE IRRIGATION CONSULTANT FOR APPROVAL AS PART OF THE SUBMITTAL PROCESS.
 - ONCE APPROVED SUBMITTALS HAVE BEEN RETURNED TO THE CONTRACTOR, WORK MAY BEGIN. THE IRRIGATION CONSULTANT MUST BE NOTIFIED A MINIMUM OF 7-DAYS IN ADVANCE OF THE START OF WORK TO COORDINATE ON-SITE SUPERVISION AND ADMINISTRATION.
 - SEE IRRIGATION DETAILS AND SPECIFICATIONS SECTION FOR ADDITIONAL NECESSARY INFORMATION.

LATERAL PIPE SCHEDULE GENERAL TURF AREAS	
FLOW	PIPE SIZE / TYPE
0-12 GPM	1 INCH CLASS-200 PVC
12-22 GPM	1-1/4 INCH CLASS-200 PVC
23-35 GPM	1-1/2 INCH CLASS-200 PVC
36-55 GPM	2 INCH CLASS-200 PVC

Project: TOWN OF NANTUCKET



NOBADEER ATHLETIC FIELDS IMPROVEMENTS

7 NOBADEER FARM ROAD

Weston & Sampson

Weston & Sampson Engineers, Inc.
1 Washington Mall, 10th Floor
Boston, MA 02108
978.532.1900 800.SAMPSON
www.westonandsampson.com

Consultants:



Providing innovative design solutions for irrigation worldwide.

— 20 Merritt Parkway
Nashua, NH 03062
(603) 883-8412

— 14501 S. Old Statesville Rd., Suite 104
Huntersville, NC 28078
(704) 843-3688

www.irrigationconsulting.com

Revisions:

No.	Date	Description

COA:

Seal:

Issued For:

BID DOCUMENTS

Scale: AS NOTED

Date: AUGUST 7, 2026

Drawn By: GD

Reviewed By: JB

Approved By: JB

W&S Project No.: ENG24-1207

W&S File No.: ---


















Drawing Title:

IRRIGATION PLAN
ALTERNATE #3

Sheet Number:

L701

Copyright © 2026 Weston & Sampson, Inc.

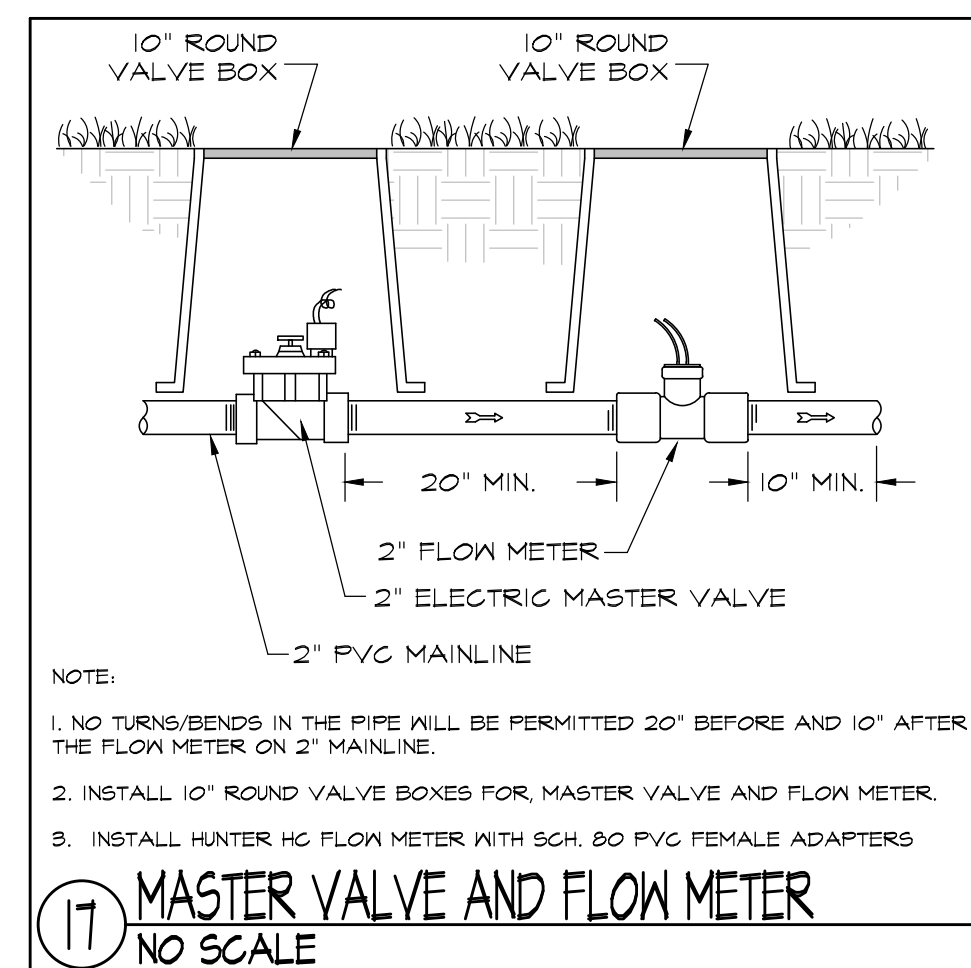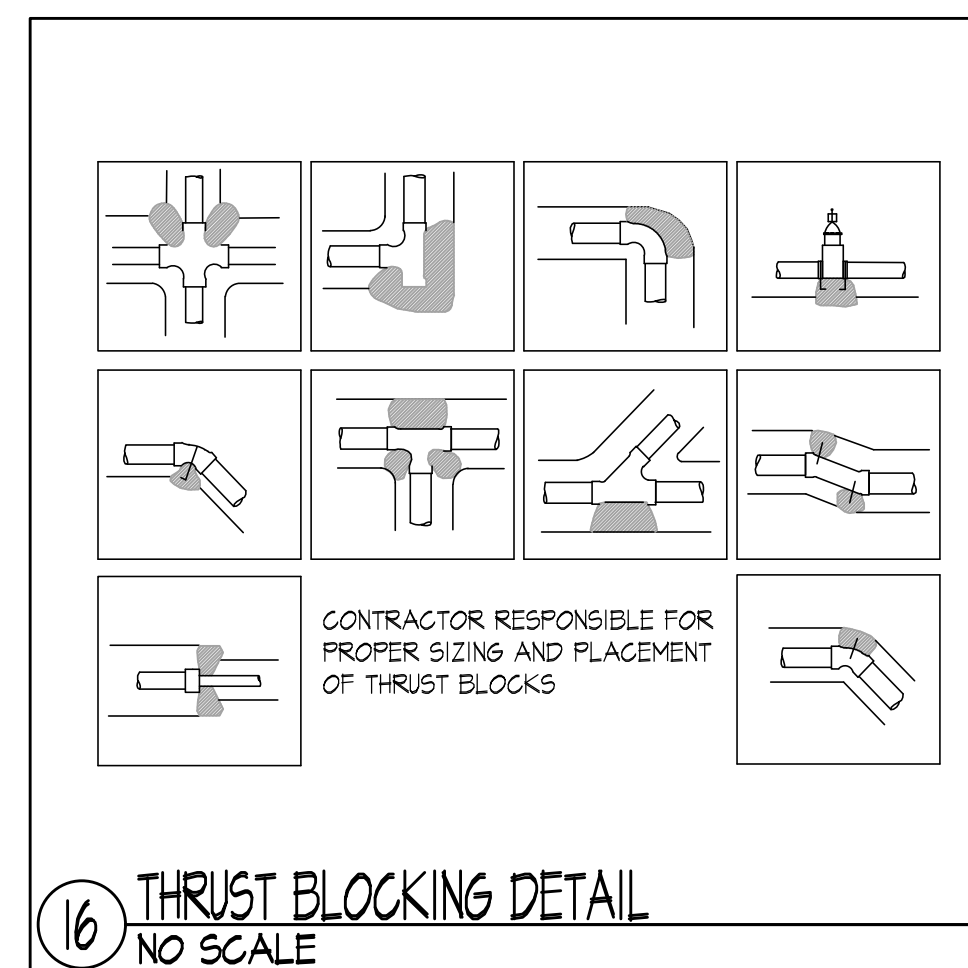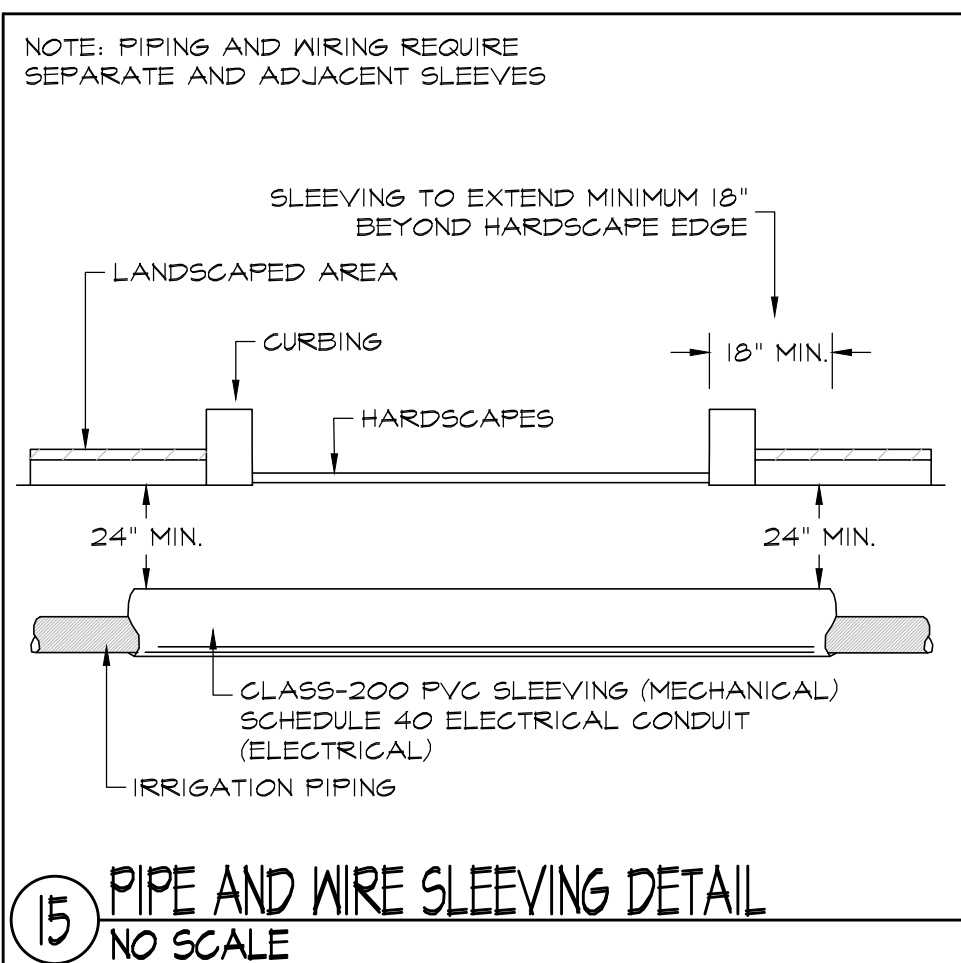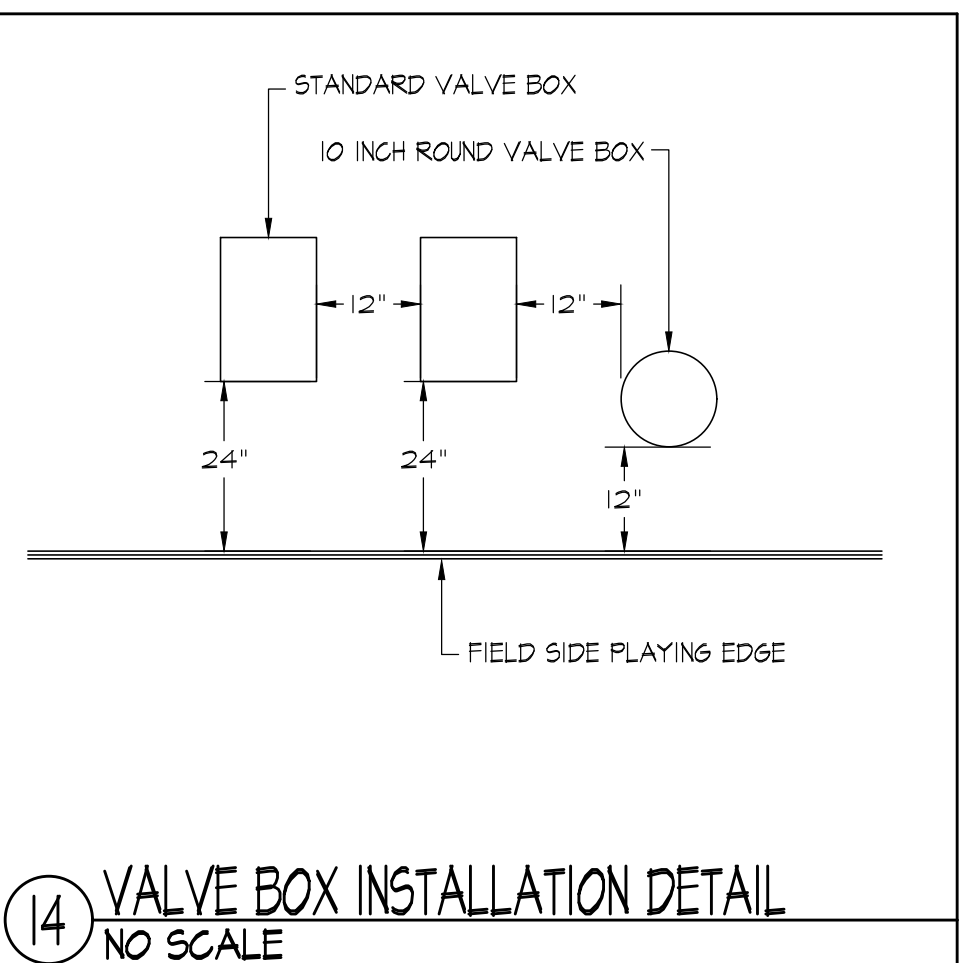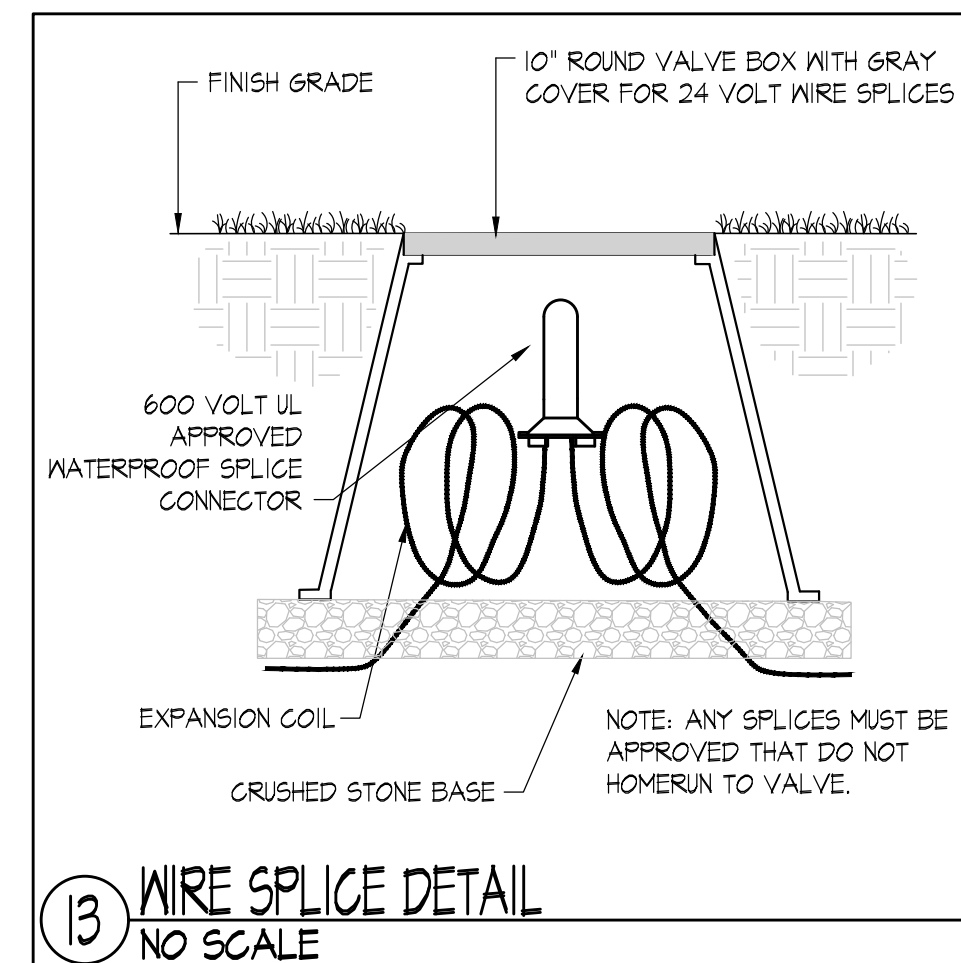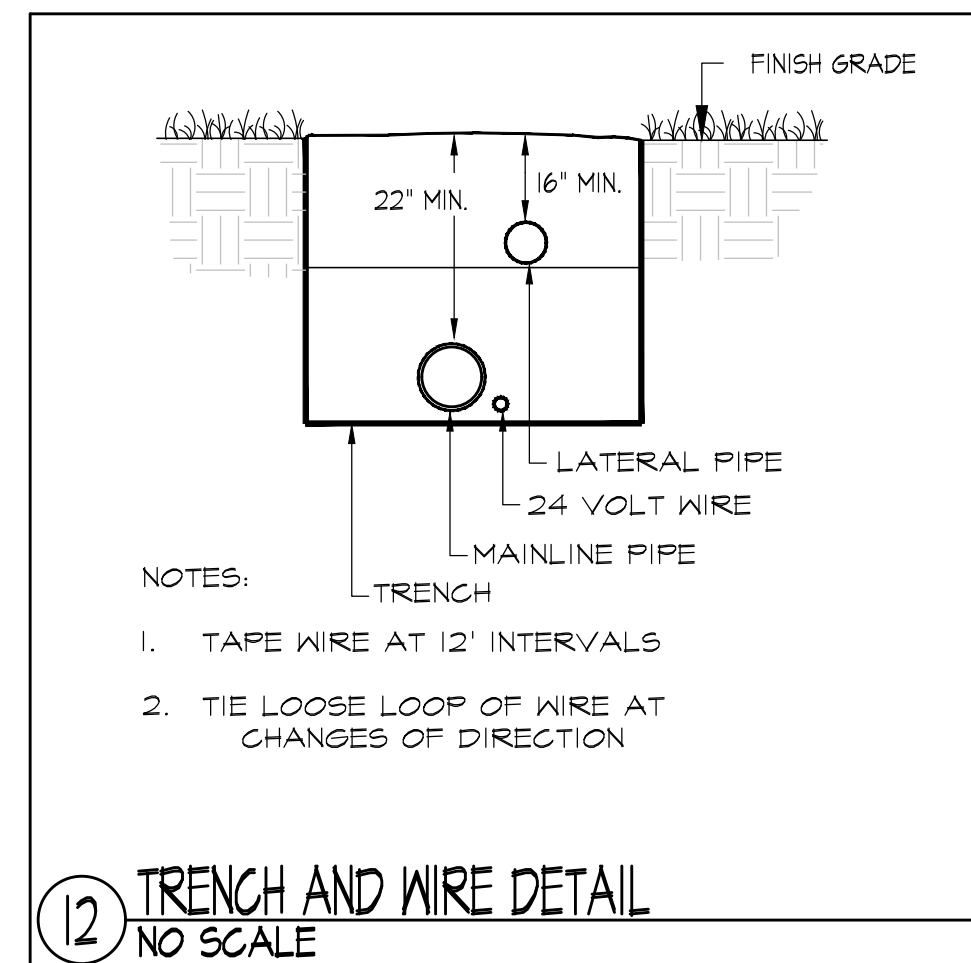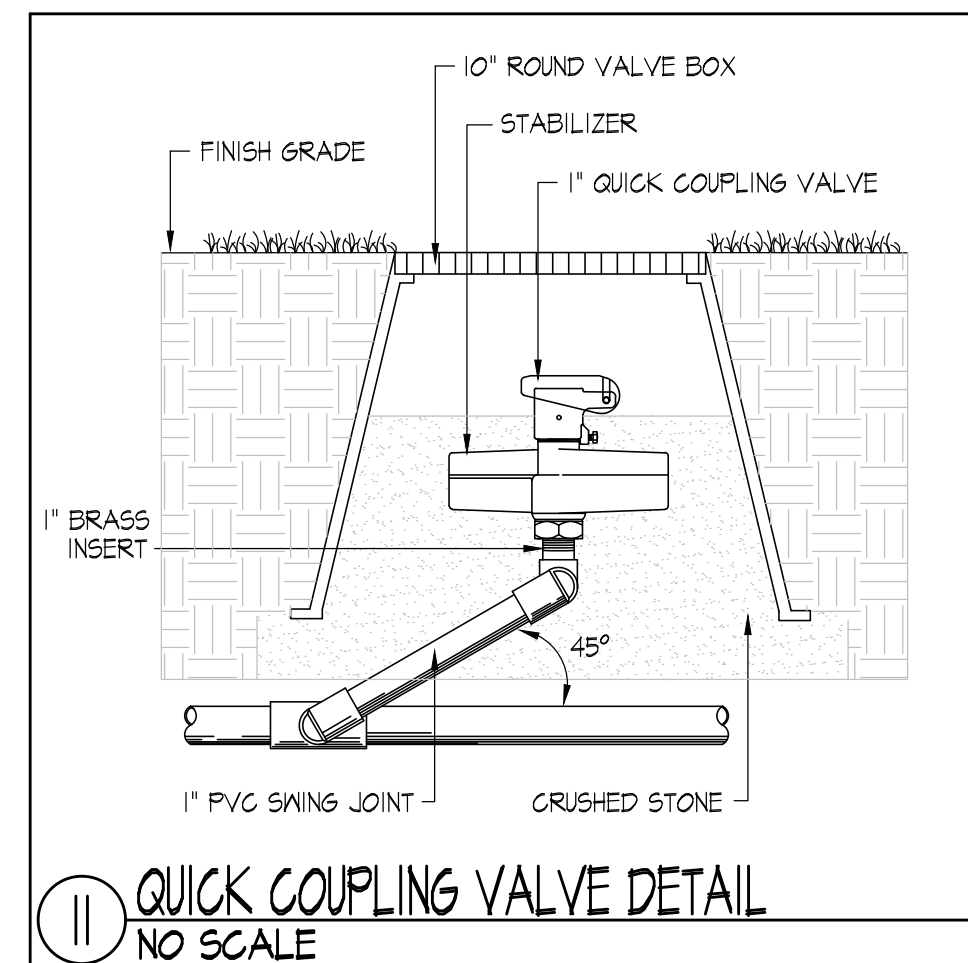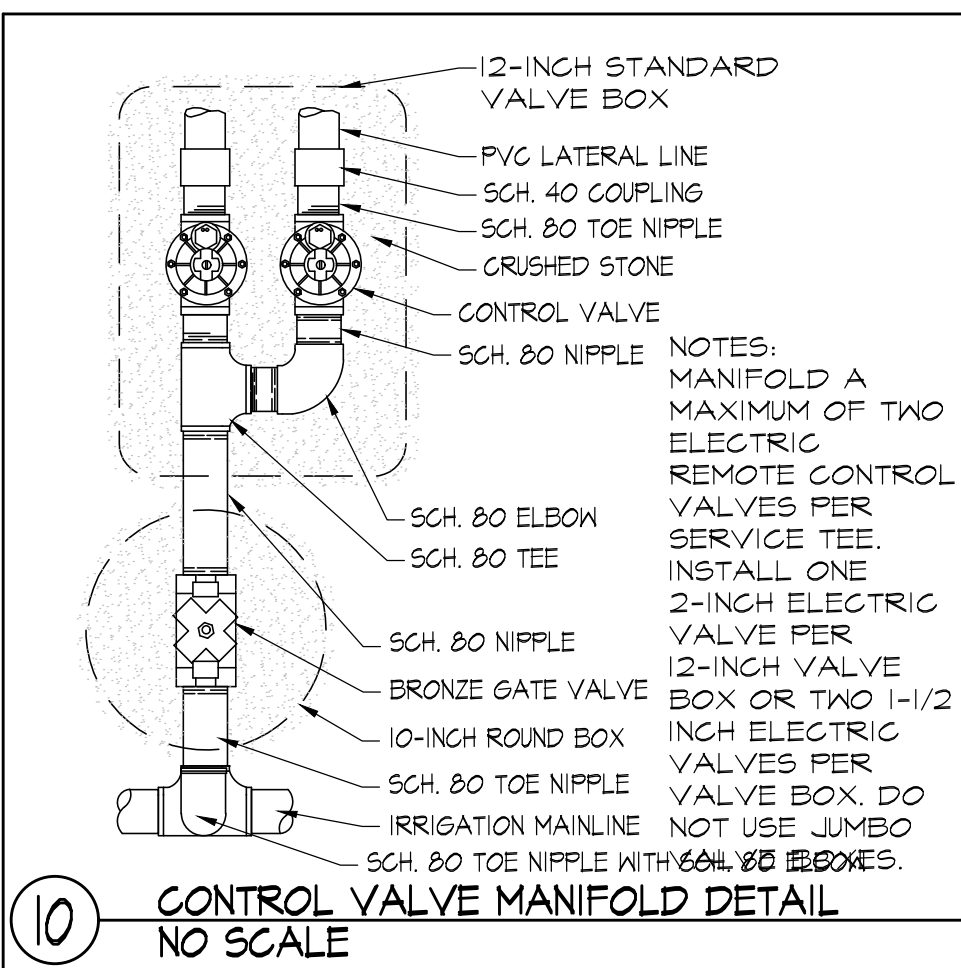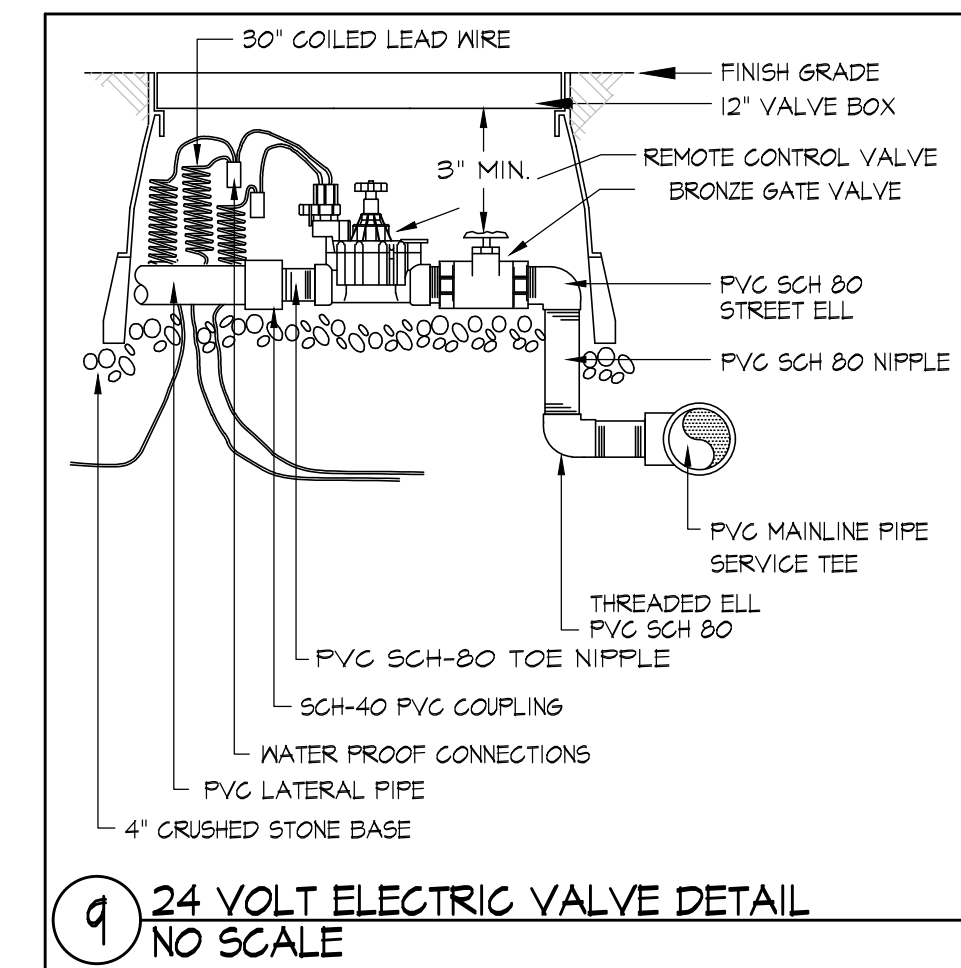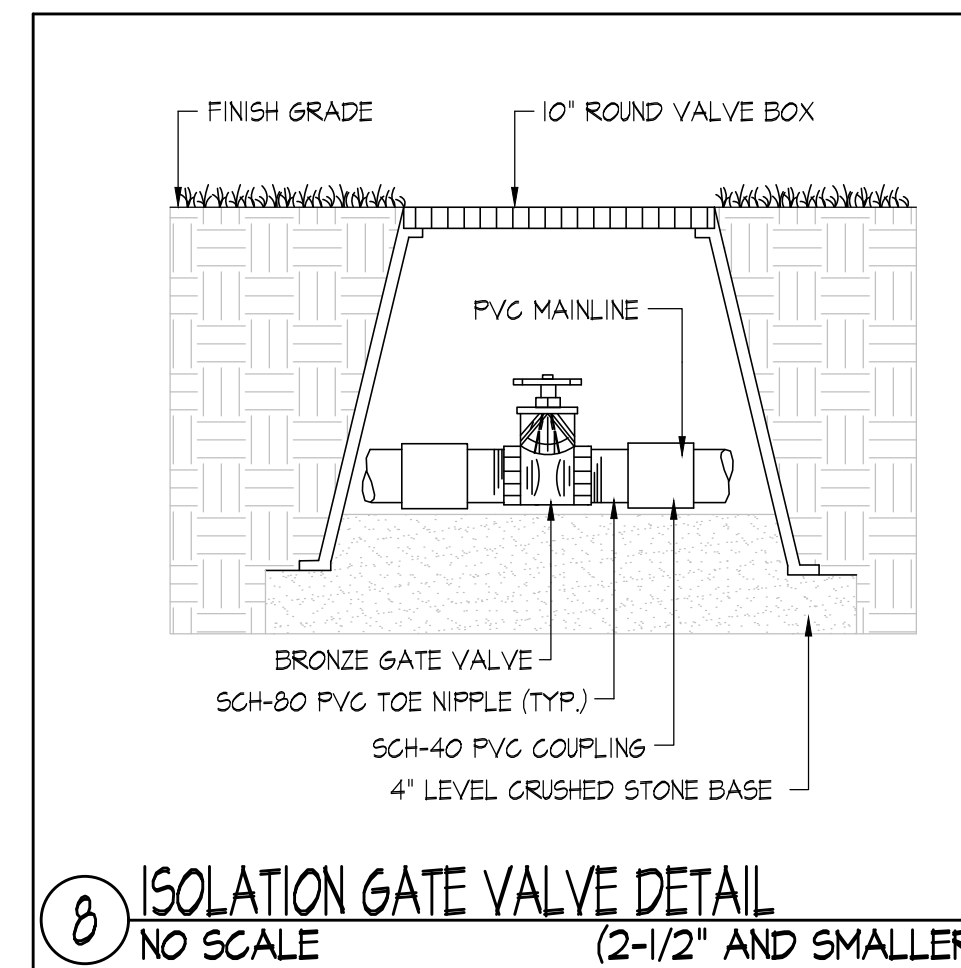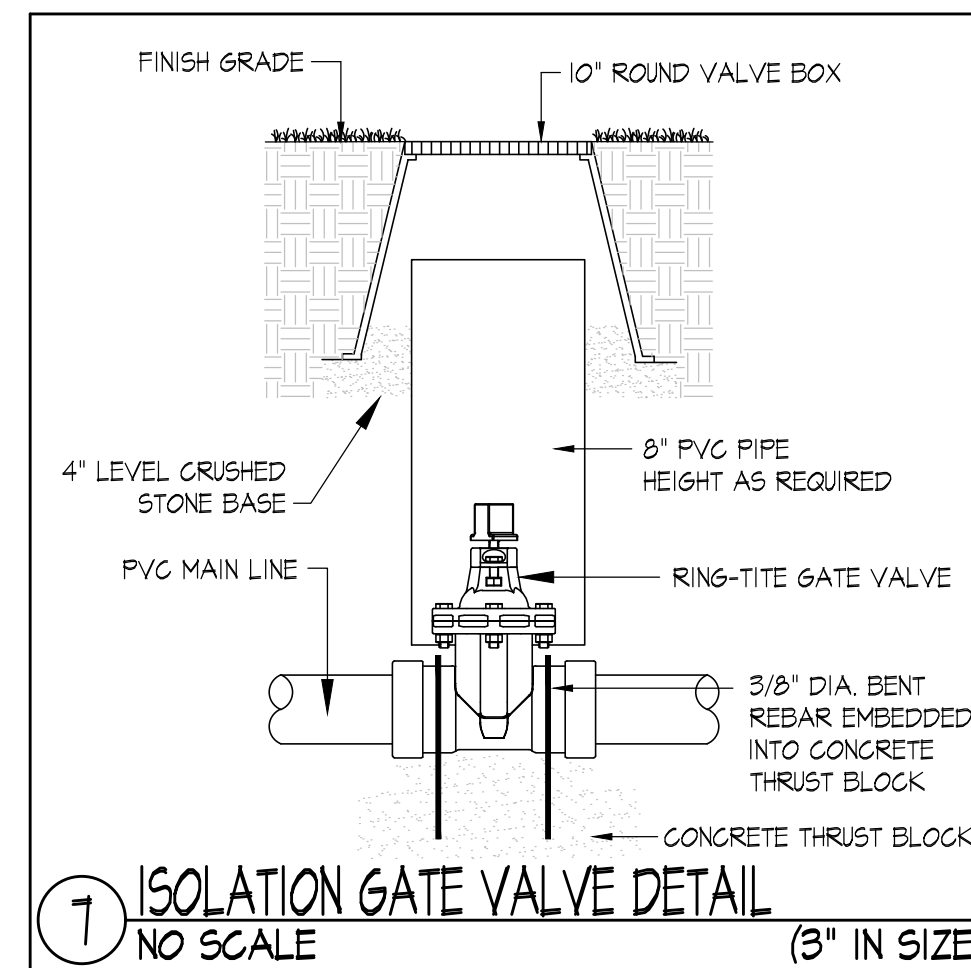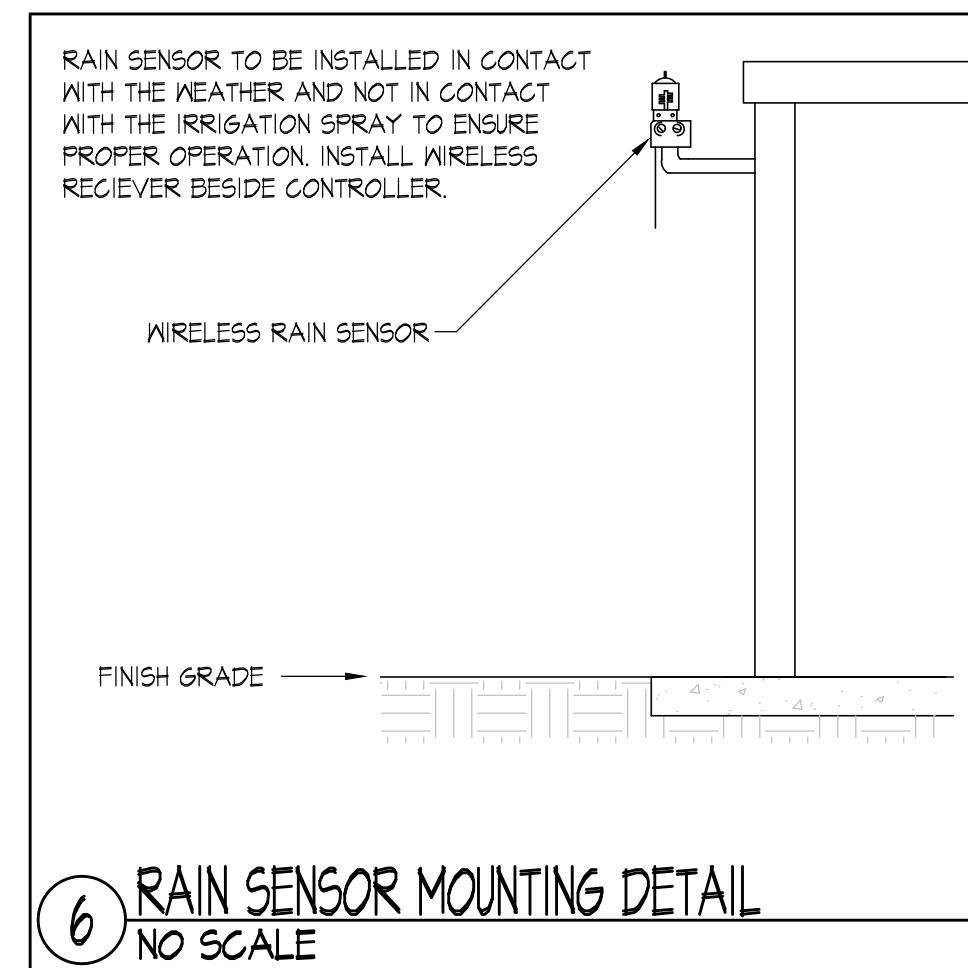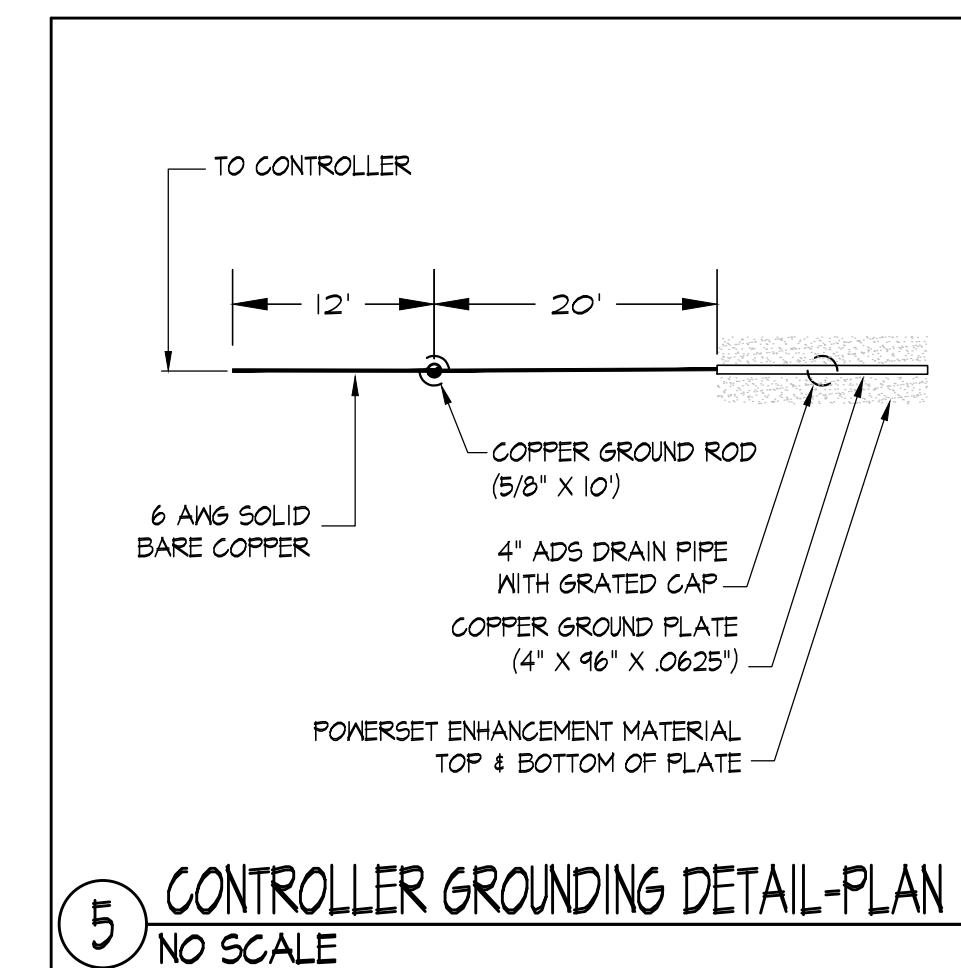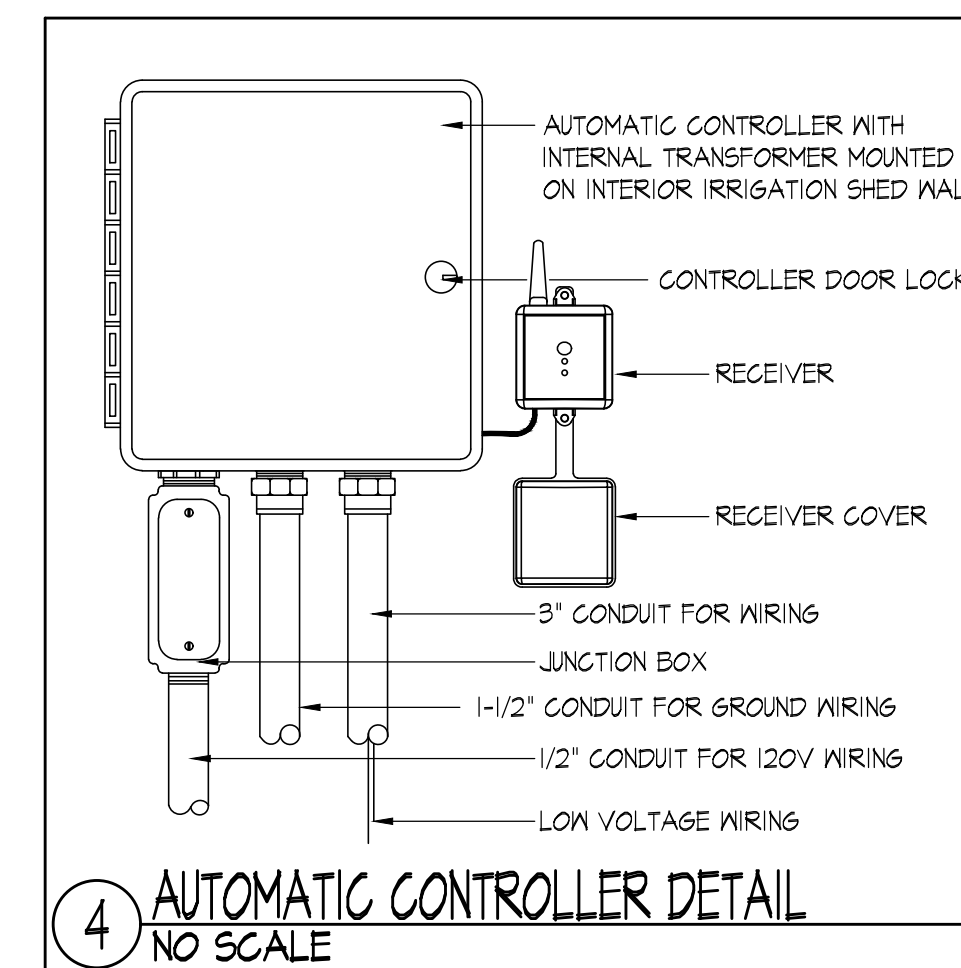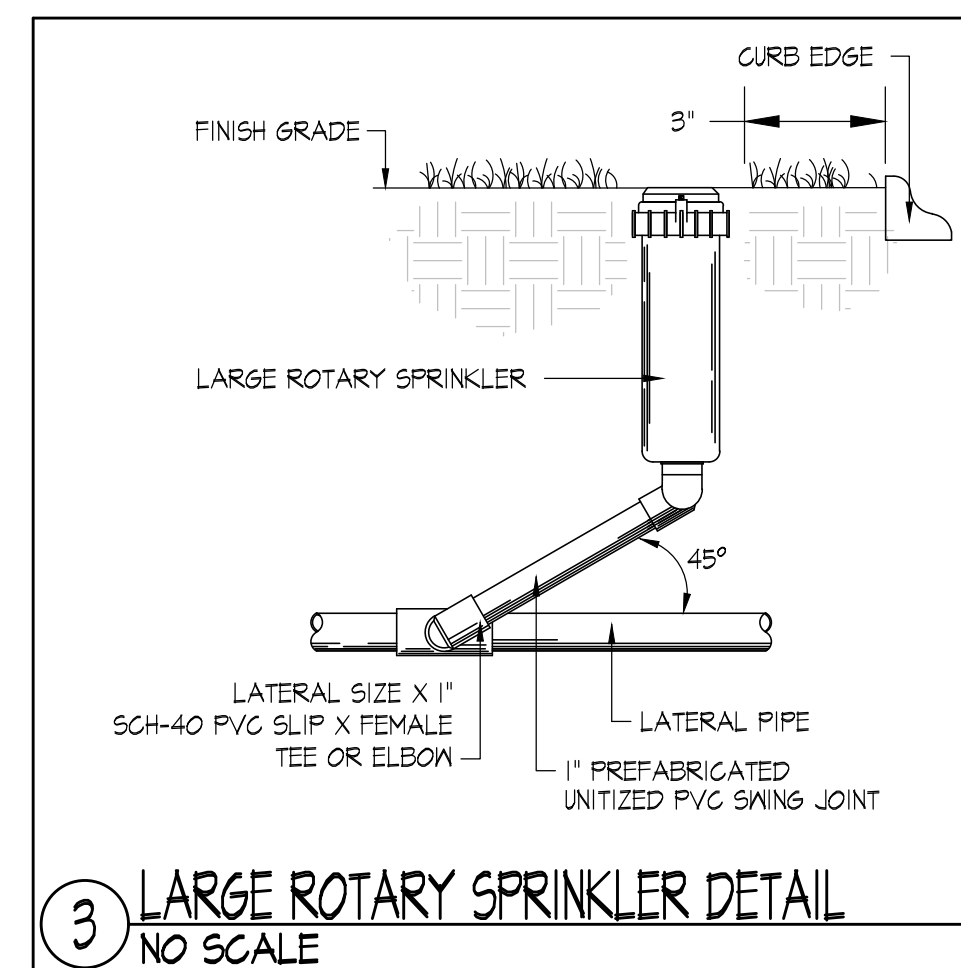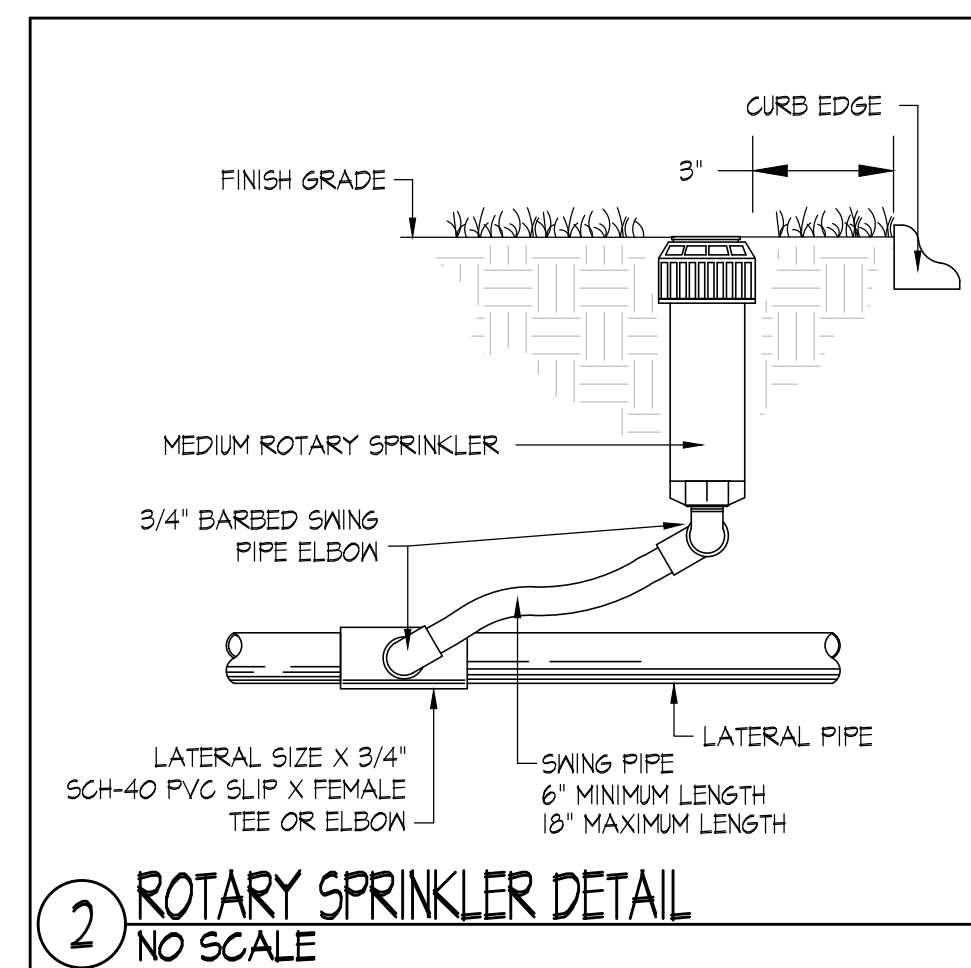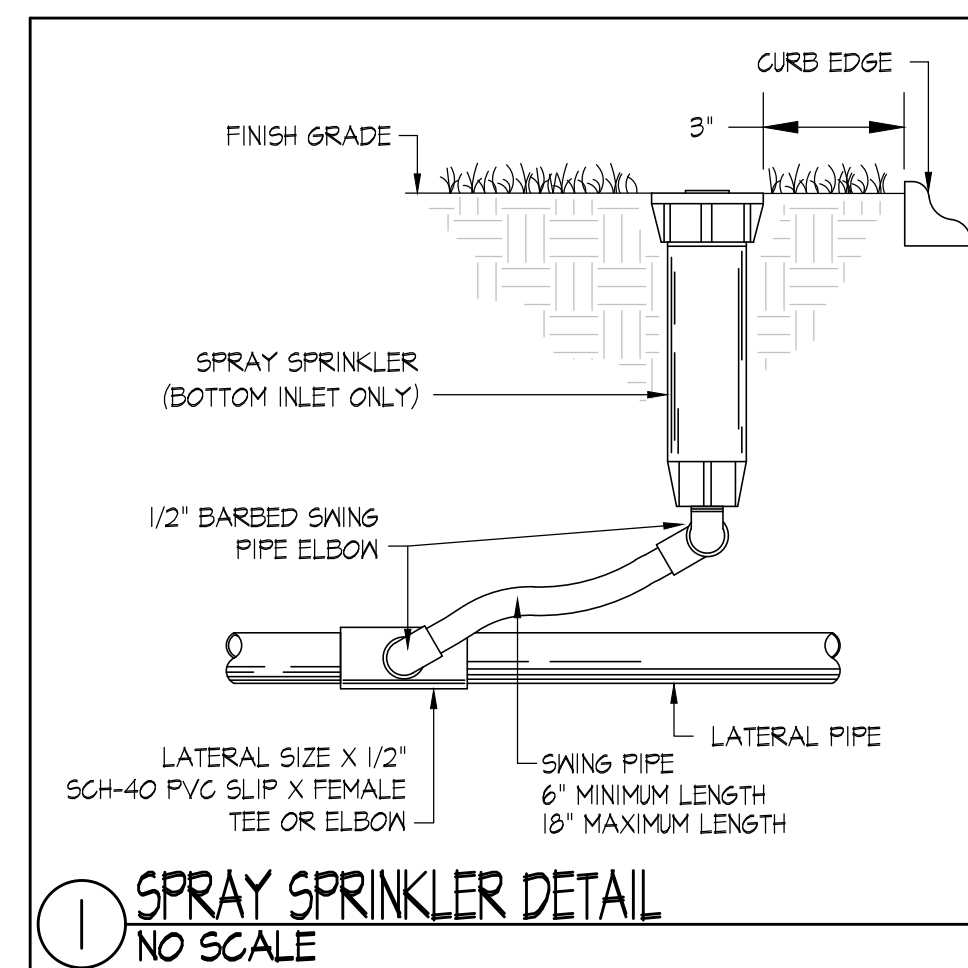[illegible]

COA-

Seal:

Issued For:

BID DOCUMENTS

Scale: AS NOTED

Date: AUGUST 7, 2026

Drawn By: GD

Reviewed By: JB

Approved By: JB

W&S Project No.: ENG24-1207







W&S File No.:

Drawing Title:

IRRIGATION DETAILS

Sheet Number:

L702

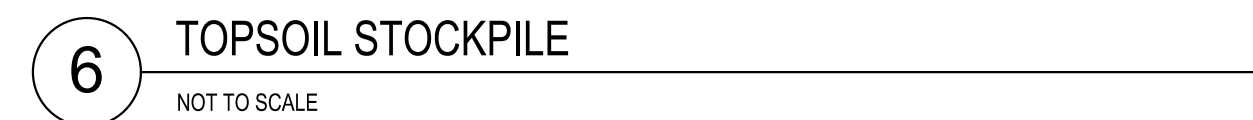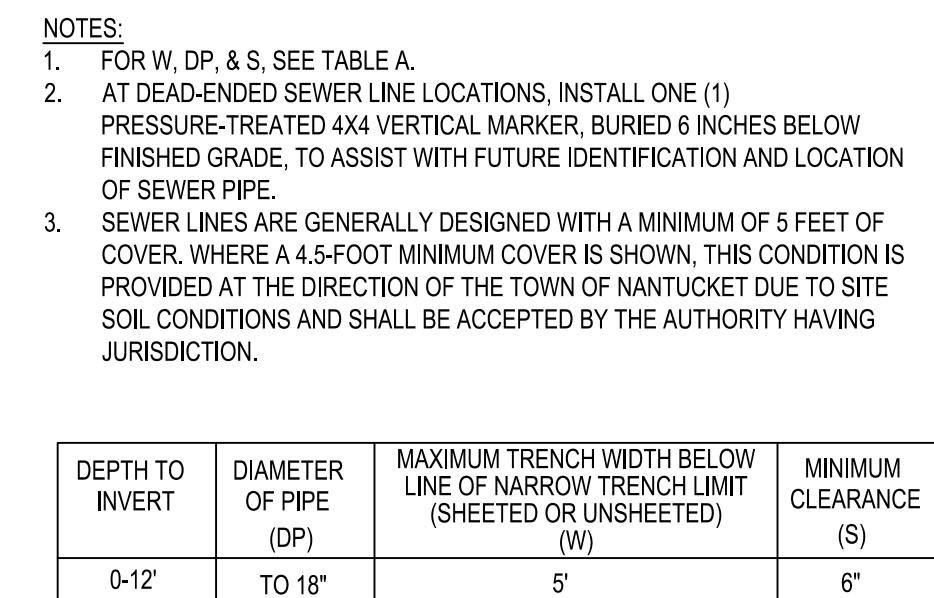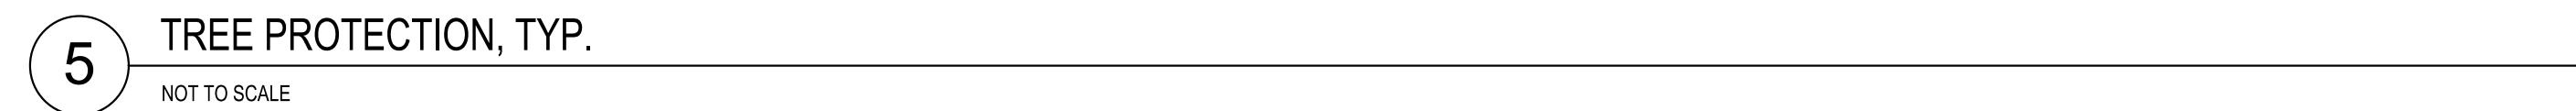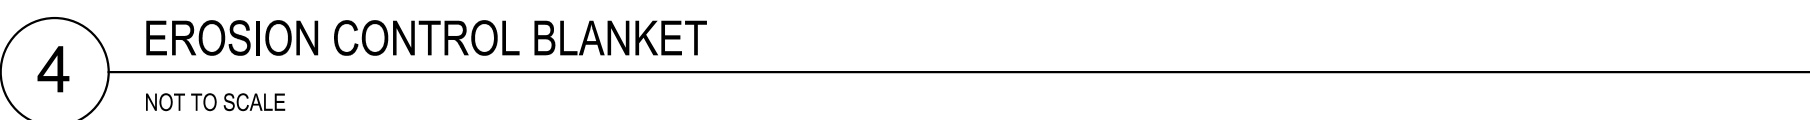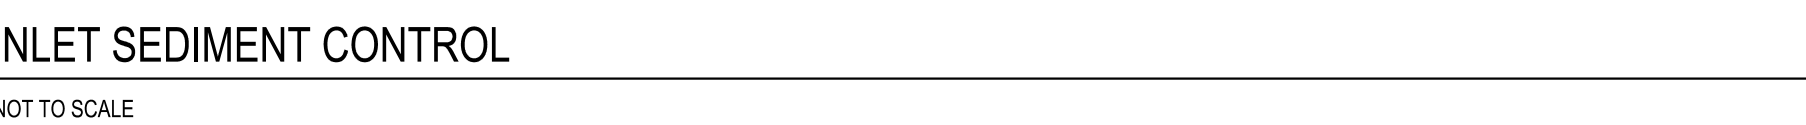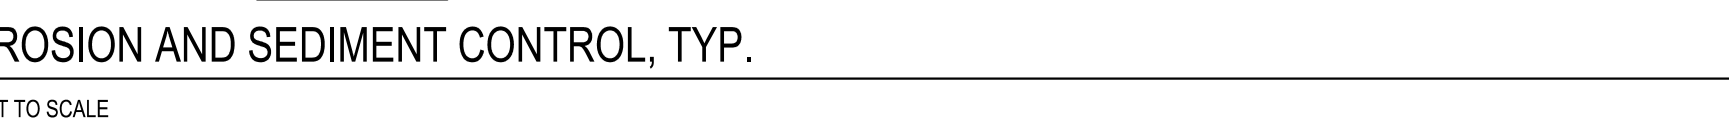

COA:


Issued For:

BID DOCUMENTS


Date:	AUGUST 7, 2026
Drawn By:	
Reviewed By:	
Approved By:	
W&S Project No.:	ENG24-1207
W&S File No.:	

Sheet Number:


L800

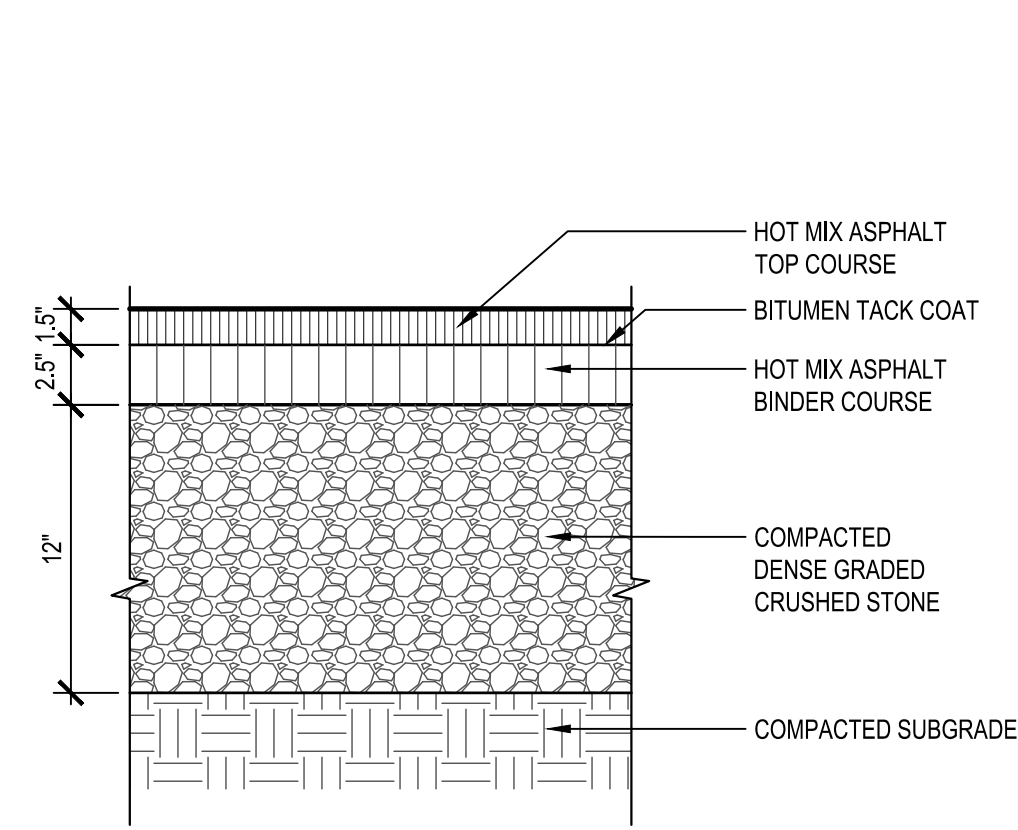


- NOTE:
- CONTRACTOR TO SAW-CUT, TACK COAT AND PROVIDE SMOOTH TRANSITION WHERE EXISTING PAVEMENT ABUTS NEW PAVEMENT.
 - ALL EDGES TO BE NEATLY TAMPED.

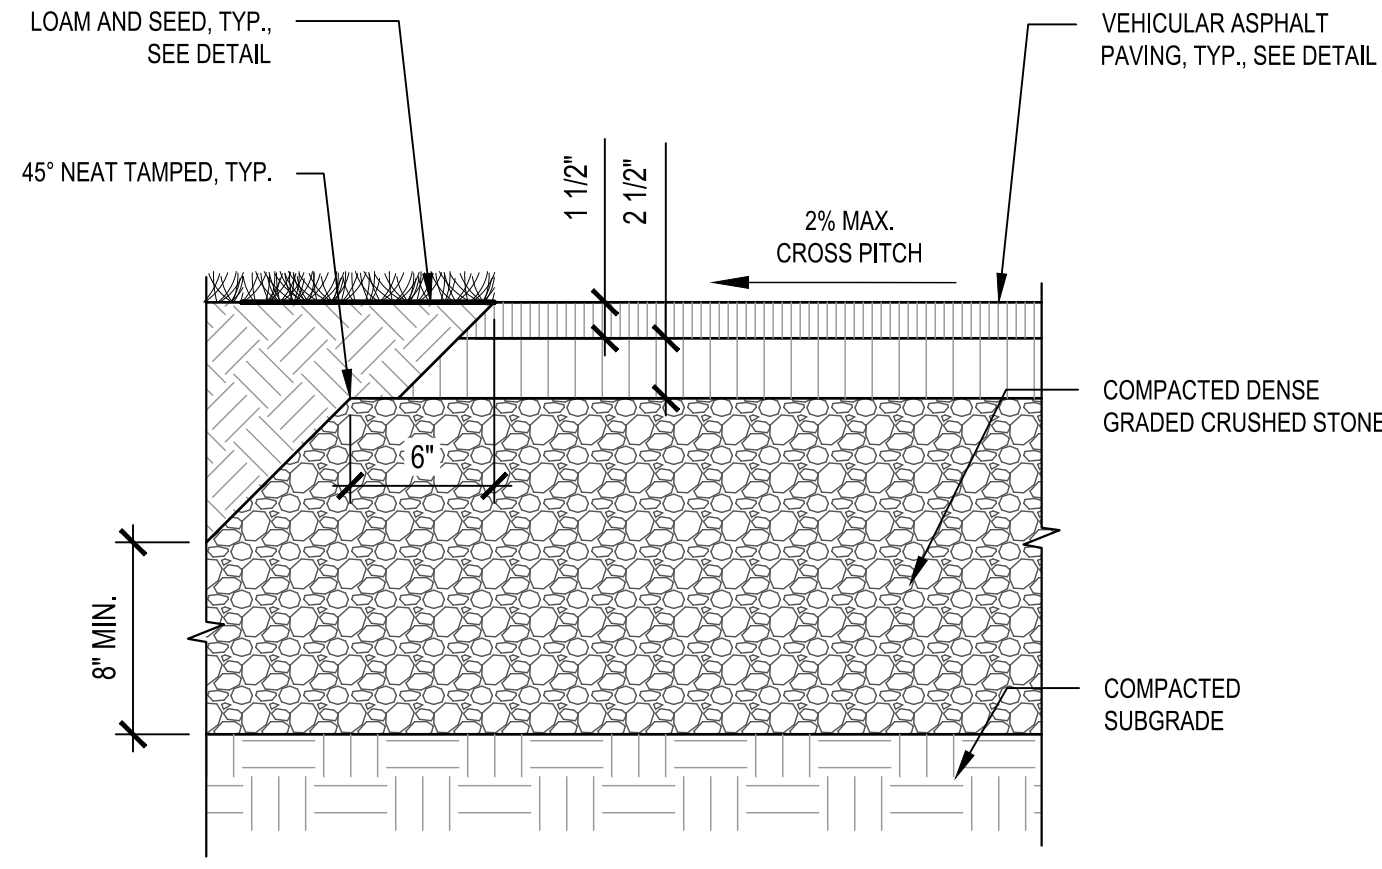

- NOTES:
- CONTRACTOR TO PROVIDE SMOOTH TRANSITION WHERE NEW PAVEMENT ABUTS EXISTING PAVEMENT, TYP.

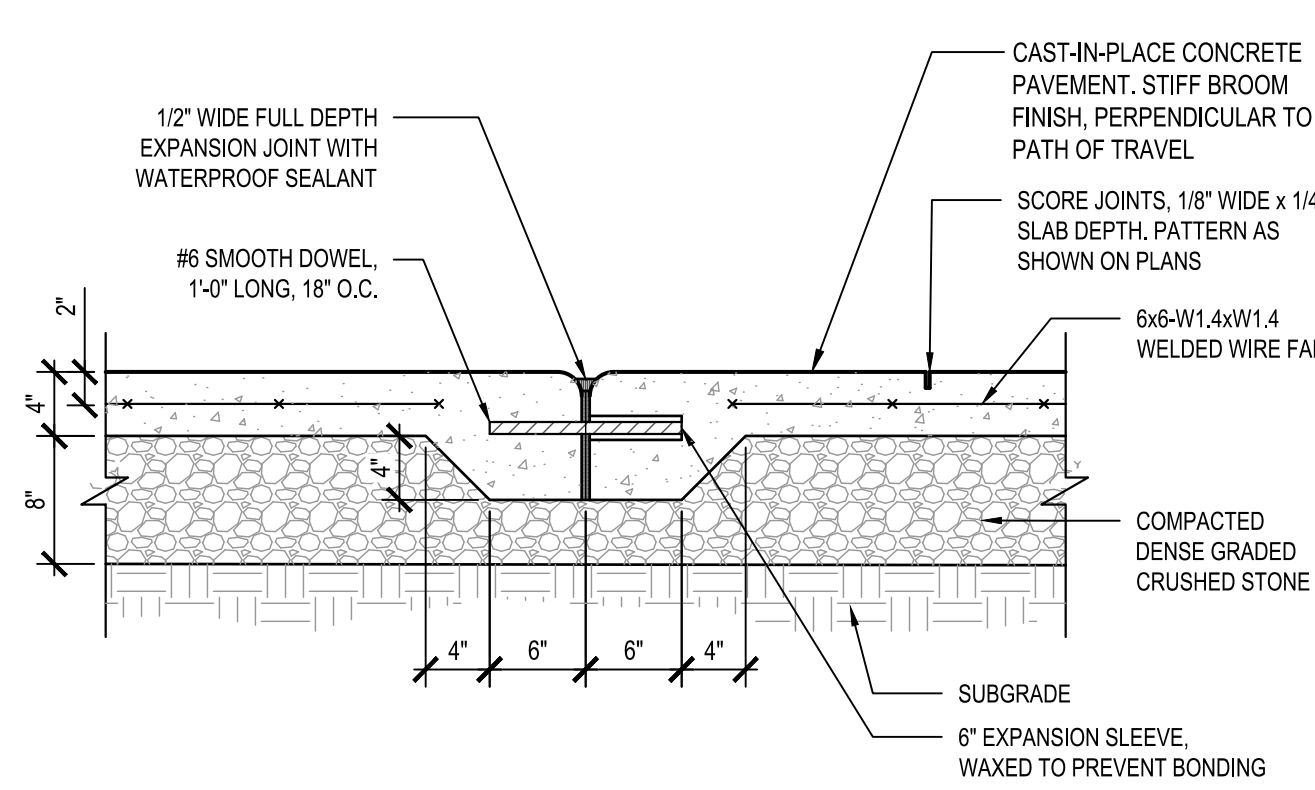

- NOTE:
- EXPANSION JOINT MAX. 25'-0" O.C., UNLESS SHOWN OTHERWISE.
 - SCORE JOINTS MAX. 5'-0" O.C., UNLESS SHOWN OTHERWISE.
 - DOWEL IS TYPICAL AT ALL EXPANSION JOINTS (18" O.C.) WITHIN CONCRETE PAVING, BETWEEN NEW CONCRETE PAVING AND EXISTING CONCRETE, AND BUILDING FOUNDATIONS.
 - ALL SCORE JOINTS SHALL BE SAW CUT.
 - PROVIDE PICTURE-FRAME EDGES TO MATCH EXISTING CONDITIONS, TOOL EDGE AT SCORE JOINTS, DO NOT TOOL EDGE AT EXPANSION JOINT

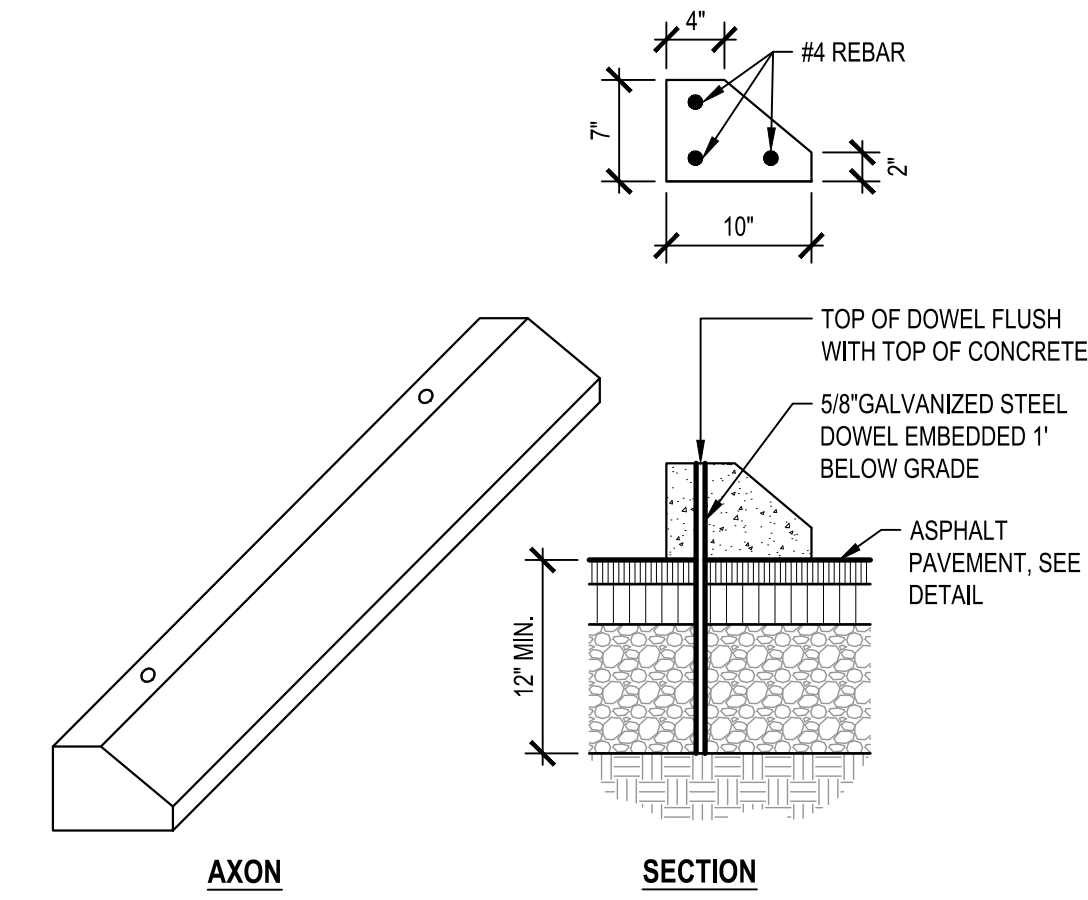

- NOTES:
- WHEEL STOPS SHALL BE PRECAST CONCRETE SINGLE FACE
 - DIMENSION SHALL BE 6'-0" LONG WITH (2) 5/8" DIA. GALVANIZED STEEL DOWELS.
 - REINFORCING STEEL DEFORMED BARS CONFORM TO THE LATEST ASTM SPECIFICATION A615.
 - MANUFACTURED TO MASSDOT SPECIFICATIONS.
 - ALL FINAL LOCATIONS ARE TO BE APPROVED IN THE FIELD BY THE ENGINEER.

1 VEHICULAR ASPHALT PAVING

NOT TO SCALE

2 HOT MIX ASPHALT AT LAWN


NOT TO SCALE

3 CAST-IN-PLACE CONCRETE PAVEMENT

NOT TO SCALE

4 CONCRETE WHEEL STOP

NOT TO SCALE

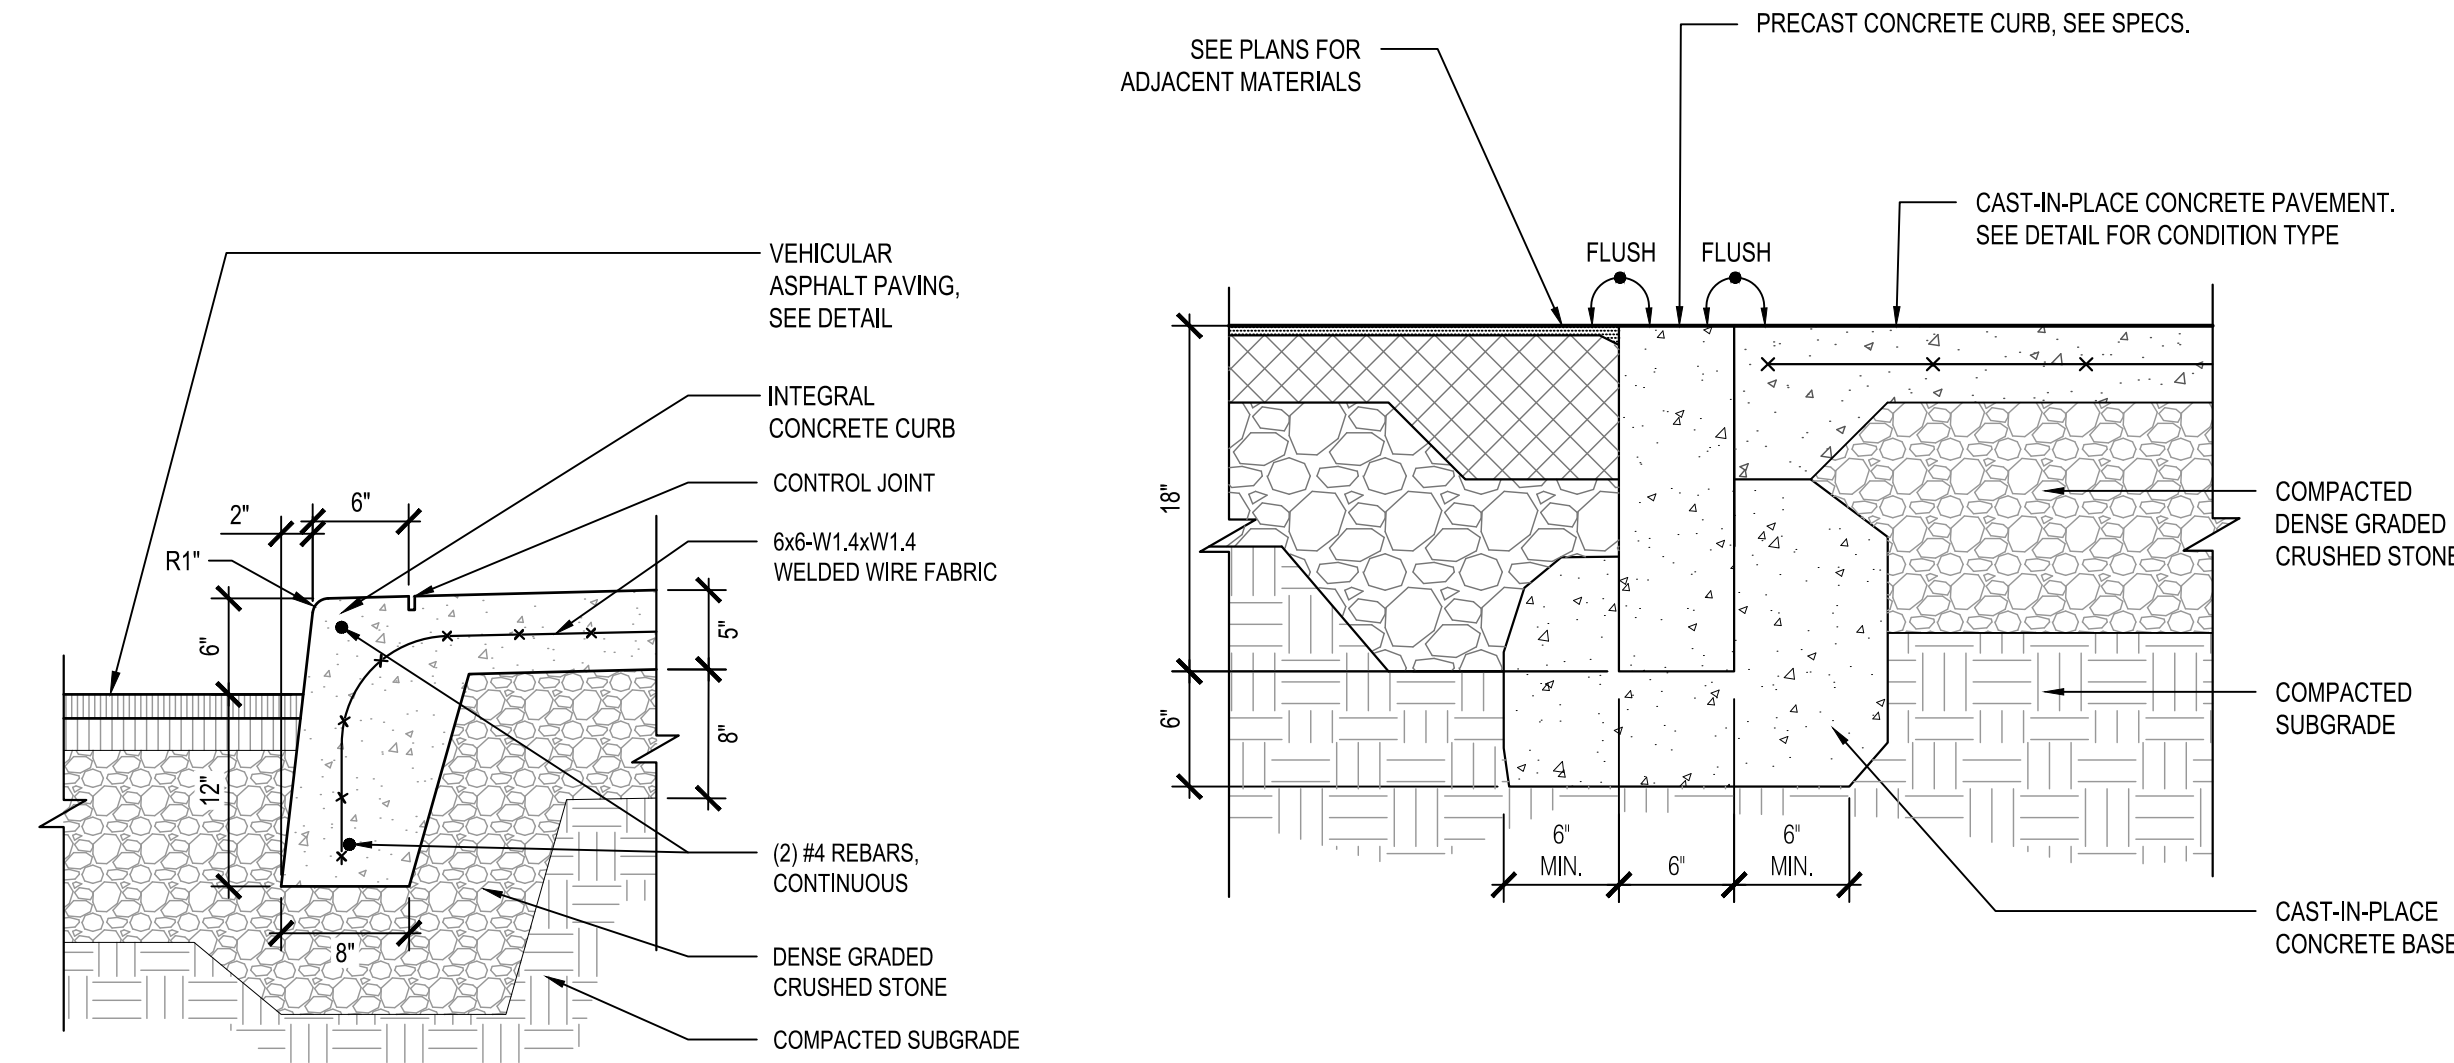

5 INTEGRAL VERTICAL CONCRETE CURB

NOT TO SCALE

6 FLUSH PRECAST CONCRETE CURB


NOT TO SCALE

7 VERTICAL PRECAST CONCRETE CURB

NOT TO SCALE

8 ACCESSIBLE PARKING SPACE LAYOUT


NOT TO SCALE

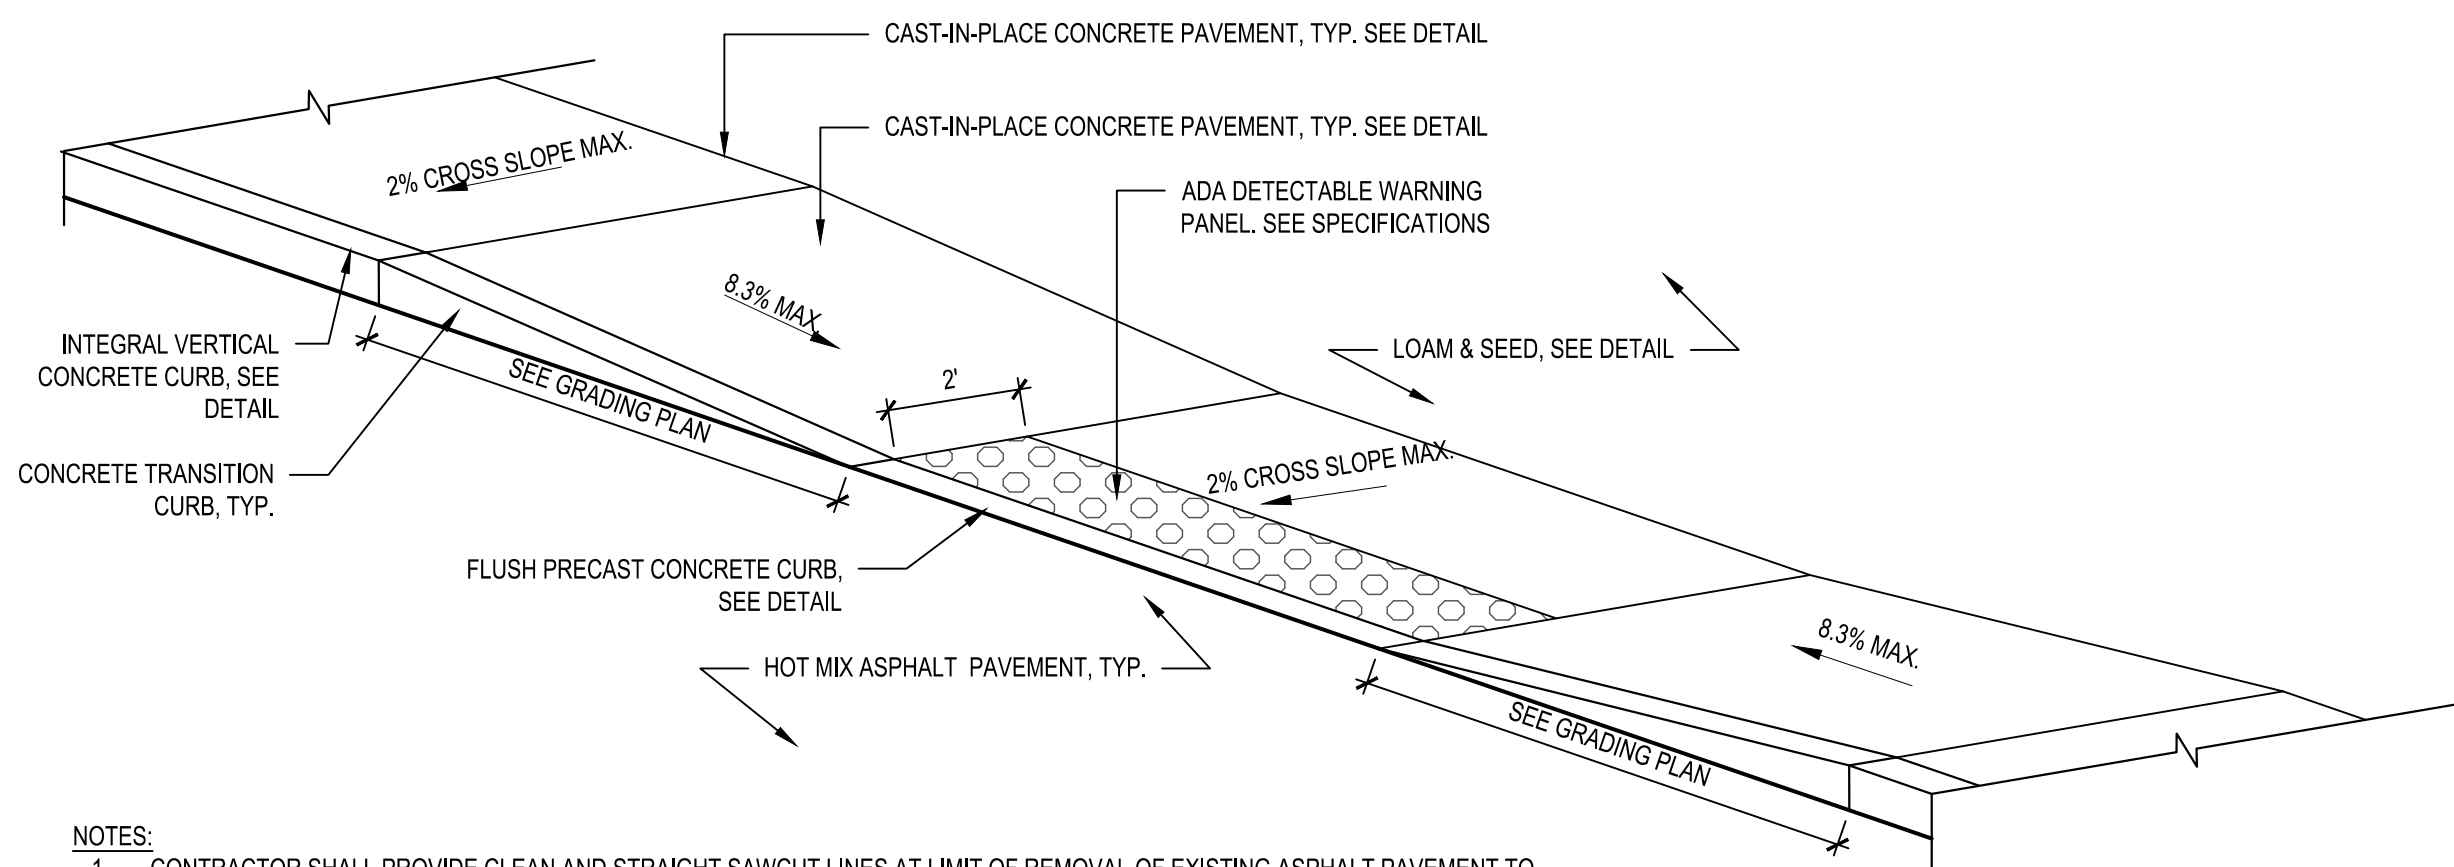

- NOTES:
- CONTRACTOR SHALL PROVIDE CLEAN AND STRAIGHT SAWCUT LINES AT LIMIT OF REMOVAL OF EXISTING ASPHALT PAVEMENT TO REMAIN. CONTRACTOR SHALL VERIFY LIMITS OF EXISTING ASPHALT PAVEMENT REMOVAL PRIOR TO COMMENCING DEMOLITION.
 - CONTRACTOR SHALL REMOVE AND REPLACE ASPHALT PAVEMENT, DENSE CRUSHED STONE, AND GRAVEL BORROW SUBGRADE NECESSARY TO CONSTRUCT A CLEAN, SMOOTH TRANSITION WHERE IT ABUTS EXISTING CONDITIONS.

9 ADA CURB CUT - TYPE A


NOT TO SCALE

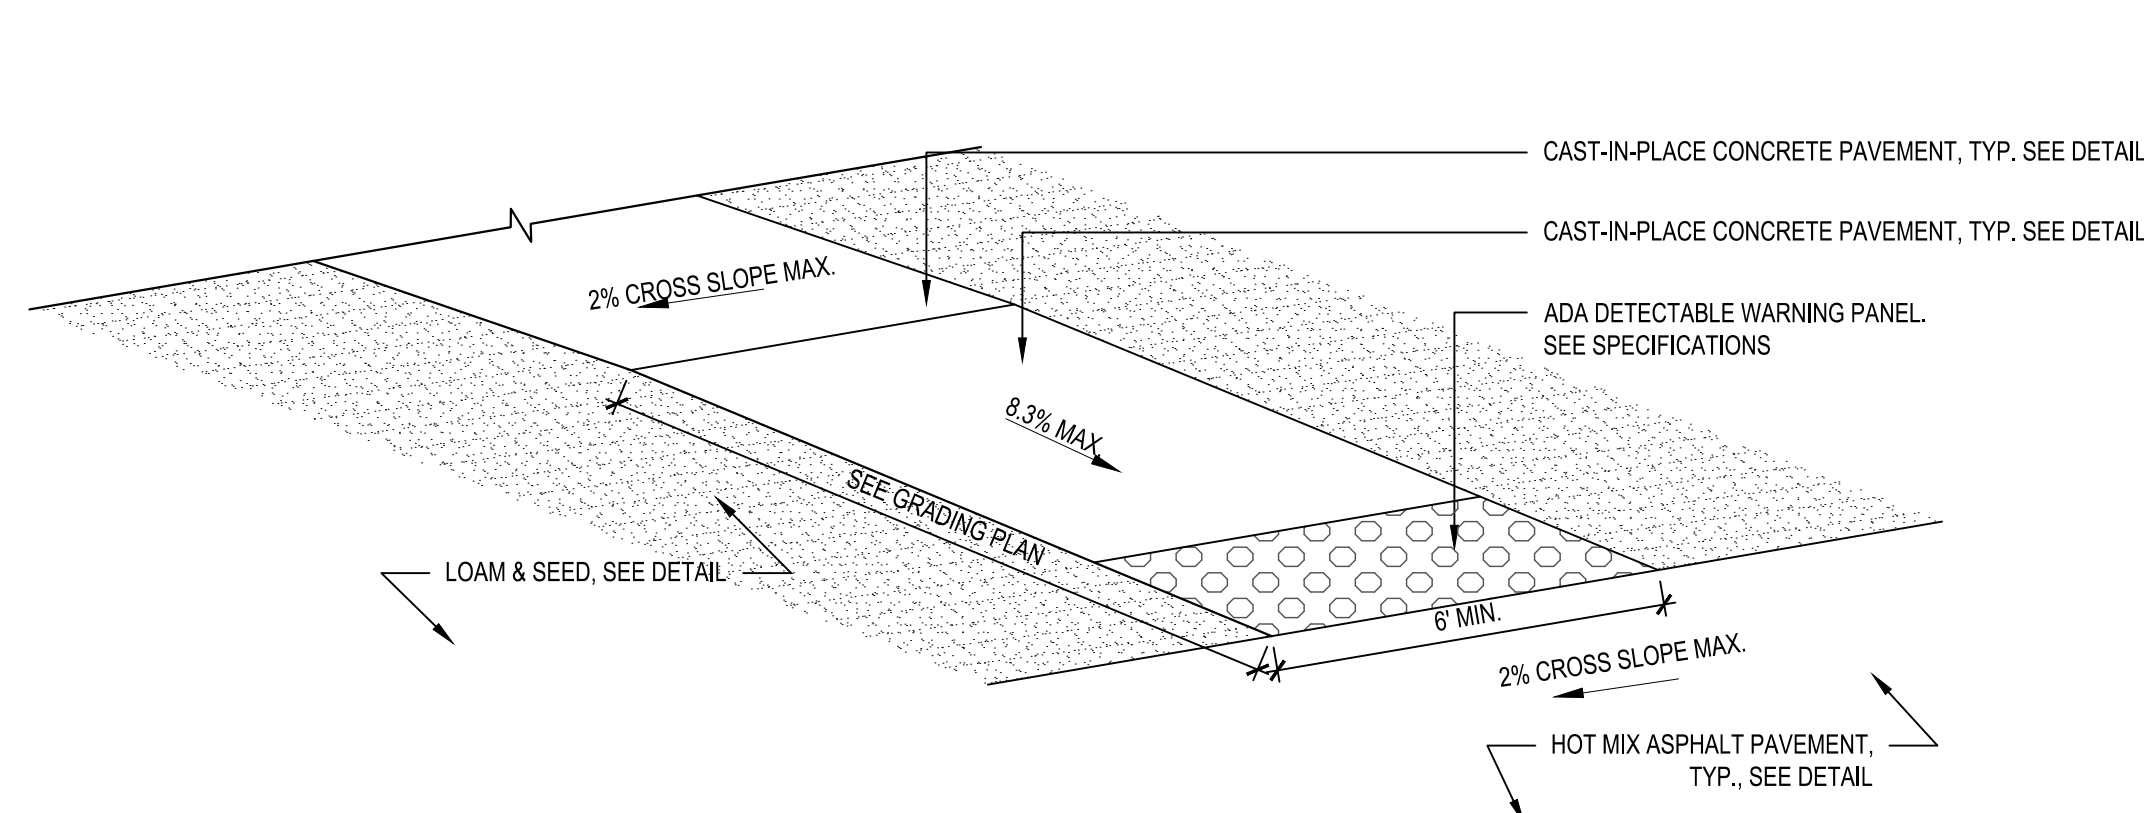

- NOTES:
- CONTRACTOR SHALL PROVIDE CLEAN AND STRAIGHT SAWCUT LINES AT LIMIT OF REMOVAL OF EXISTING ASPHALT PAVEMENT TO REMAIN. CONTRACTOR SHALL VERIFY LIMITS OF EXISTING ASPHALT PAVEMENT REMOVAL PRIOR TO COMMENCING DEMOLITION.
 - CONTRACTOR SHALL REMOVE AND REPLACE ASPHALT PAVEMENT, DENSE CRUSHED STONE, AND GRAVEL BORROW SUBGRADE NECESSARY TO CONSTRUCT A CLEAN, SMOOTH TRANSITION WHERE IT ABUTS EXISTING CONDITIONS.

10 ADA CURB CUT-TYPE B

NOT TO SCALE

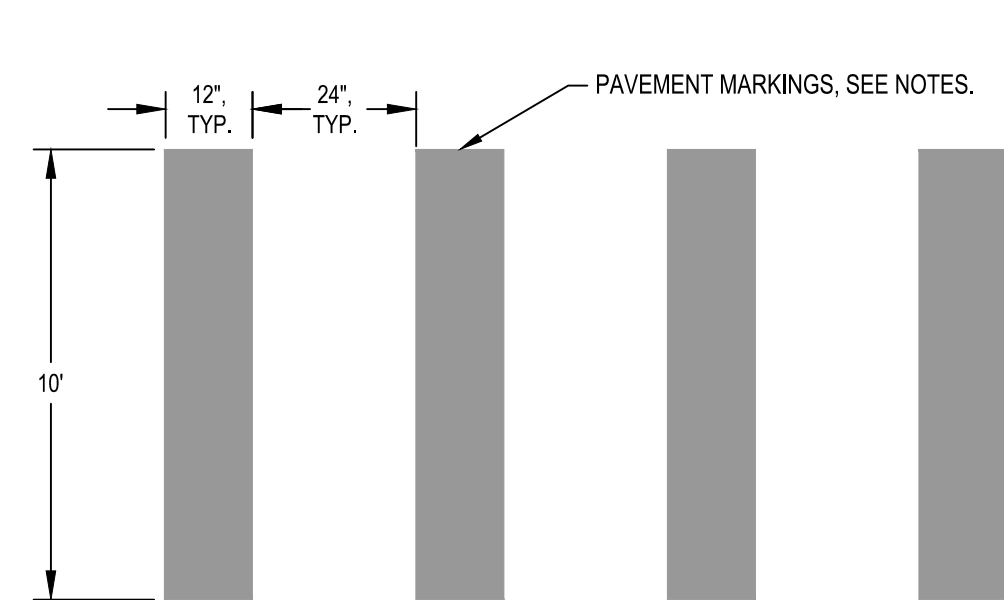

- NOTE:
- PROVIDE PAVEMENT MARKINGS WHERE SHOWN ON PLANS IN ACCORDANCE WITH THIS DETAIL.
 - CROSSWALK MARKINGS FOR NEW ROADWAYS SHALL BE INSTALLED USING EPOXY PAVING MARKING MATERIAL CONFORMING TO MASSDOT ENGINEERING DIRECTIVE E-05-003, DATED JUNE 16, 2005 AND TO MASSDOT STANDARD SECTION 860.

11 CROSSWALK PAVEMENT MARKINGS

NOT TO SCALE

Project: TOWN OF NANTUCKET



NOBADEER ATHLETIC FIELDS
IMPROVEMENTS

7 NOBADEER FARM ROAD

Weston & Sampson

Weston & Sampson Engineers, Inc.
1 Washington Mall, 10th Floor
Boston, MA 02108

978.532.1900 800.SAMPSON

www.westonandsampson.com

Consultants:

Revisions:

No.	Date	Description

COA:

Seal:



Issued For:

BID DOCUMENTS

Scale: AS NOTED

Date: AUGUST 7, 2026

Drawn By:

Reviewed By:

Approved By:

W&S Project No.: ENG24-1207




W&S File No.:

Drawing Title:


SITE DETAILS

Sheet Number:


L801

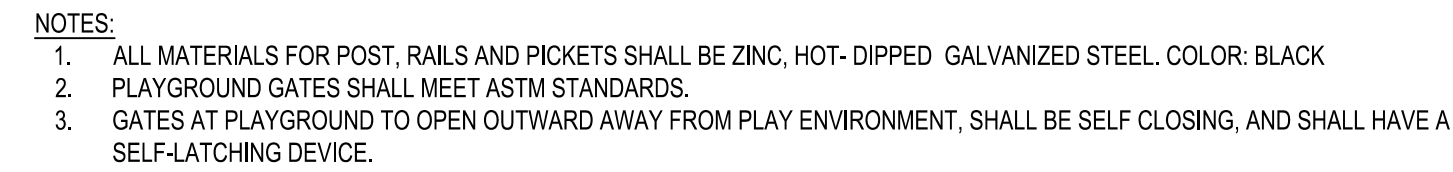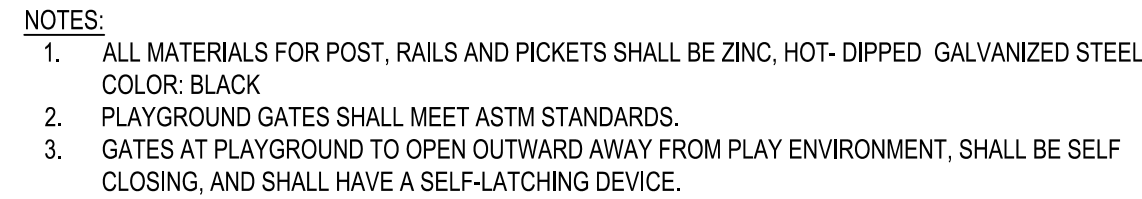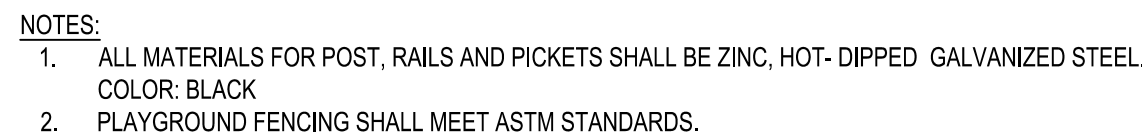


NOT TO SCALE

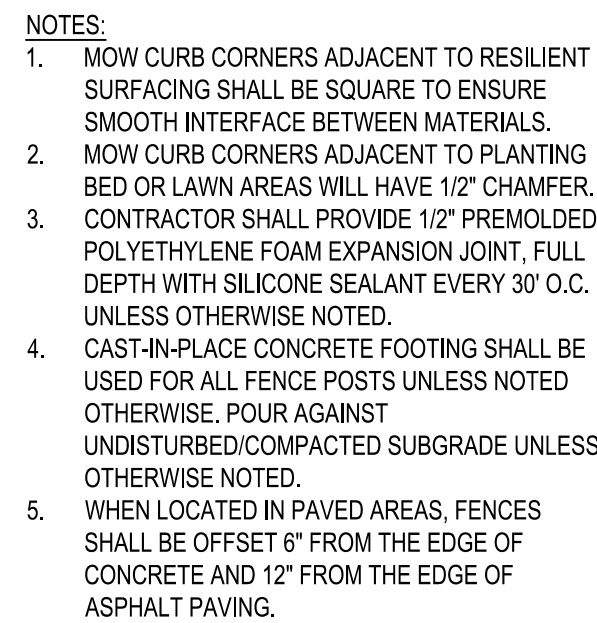



NOT TO SCALE

 


NOT TO SCALE

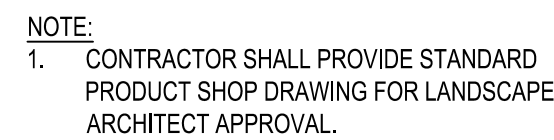


NOT TO SCALE

 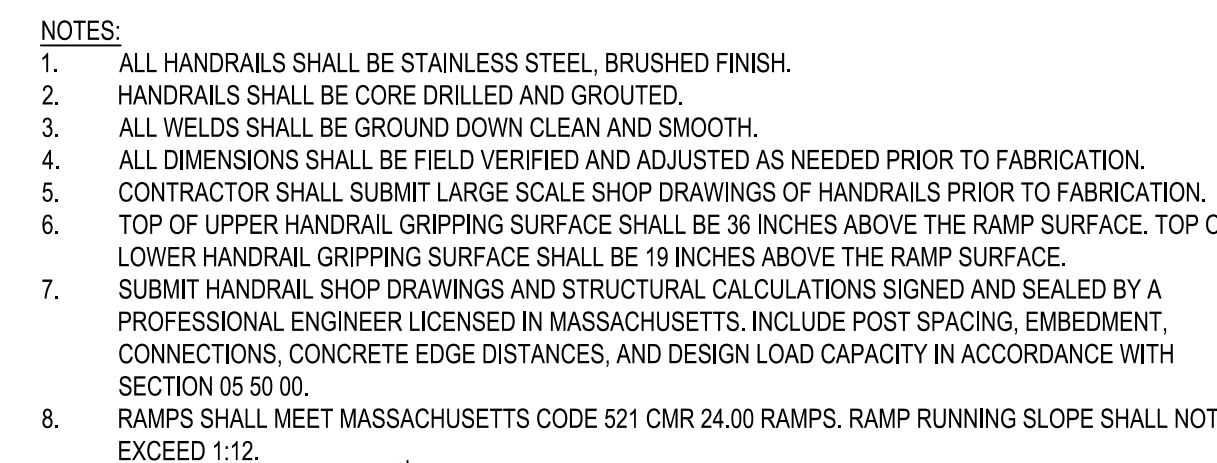


 

- FINAL COLORS, GRAPHICS, AND LOGOS SHALL
BE APPROVED BY OWNER DURING SHOP
DRAWING REVIEW.

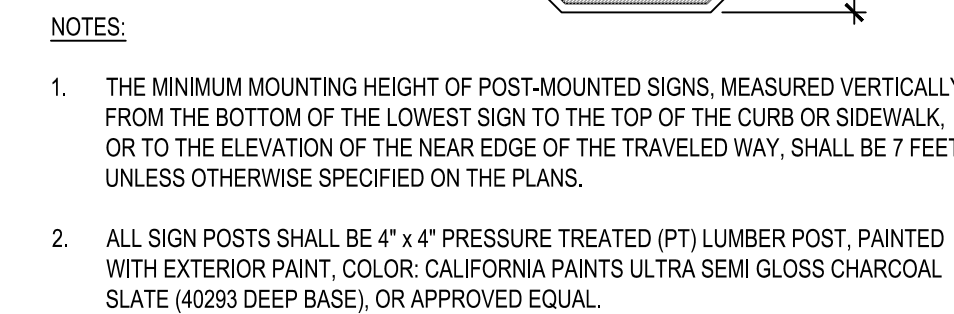

- UTILITY SHEET NOTES**
1. FOUNDATION SHALL CONSIST OF CAST-IN-PLACE CONCRETE SONOTUBE PIPES, 6" DIAMETER MINIMUM AND 48" DEPTH MINIMUM, OR AS REQUIRED TO BE SHOWN ON LOW-COST FOUNDATION PLAN. PROVIDE 3 ROWS OF THREE (3) PIPES, WITH ONE ROW BENEATH EACH 66 PSF PRESSURE-TREATED TIMBER. UNLESS NOTED OTHERWISE IN APPROVED SHOP DRAWINGS, 66 PSF PRESSURE-TREATED TIMBERS SHALL BE SUPPORTED ON CONCRETE SONOTUBE PIPES. PROVIDE 1" MINIMUM SPACING BETWEEN SONOTUBES (SIMPSON STRONG-TIE PSB, A/B, OR APPROVED EQUIVALENT), PROVIDE MINIMUM 1" STANDOFF BETWEEN CONCRETE AND WOOD. SURFACE SET ANCHORS ARE NOT PERMITTED.
2. SONOTUBE SPACING AND BRIDGE SHALL BE DESIGNED TO RESIST REQUIRED QUARTY, LATERAL, AND UPLIFT LOADS FOR EXPOSURE C WIND CONDITIONS IN ACCORDANCE WITH 703 CMR AND NANTUCKET REGULATIONS.
3. PROVIDE 6" MINIMUM COMPACTED CRUSHED STONE PAD (3/4" CRUSHED STONE) BENEATH SLED, EXTENDING FULL FOOTPRINT OF STRUCTURE PLUS 12" MINIMUM BEYOND PERIMETER. COMPACT STONE TO 95% MOISTURE PROCTOR.
4. INSTALL NON-WOVEN GEOTEXTILE FABRIC BENEATH CRUSHED STONE PAD AND TURN UP EDGES A MINIMUM OF 6" AT PERIMETER.
5. FINISHED GRADE AND STONE PAD SHALL SLOPE AWAY FROM SLED A MINIMUM OF 2% FOR 6' TO 8' FOR PROTECTION OF SLED.
6. SLED FRAME FRAMING SHALL BEAR FULLY ON 66 PSF PRESSURE-TREATED TIMBERS. SLED SHALL NOT BEAR DIRECTLY ON GRADE OR ON CRUSHED STONE. SKID-BASED, FLOATING, OR GRADE-SUPPORTED INSTALLATIONS ARE NOT PERMITTED.
7. PROVIDE MINIMUM 6" CLEARANCE BETWEEN FINISHED GRADE AND BOTTOM OF SLED FRAME UNLESS OTHERWISE APPROVED.
8. ALL PRESSURE-TREATED WOOD SHALL BE RATED FOR GROUND CONTACT AND SHALL BE AVAILABLE AND OBTAINABLE AT THE PROJECT LOCATION.
9. FINAL PILES, SPACING, CONNECTOR SELECTION, AND ANCHORAGE DETAILS SHALL MATCH APPROVED SHOP DRAWINGS AND SECTION 11.99 OF THE PLAN, WHICH IS DIAGRAMMATIC AND INTENDED TO CLARIFY DESIGN INTENT.

 


P:\H\Hudson\MA\Nantucket Farm\001\001-001-001-001.dwg User: Tomsen 7/21/2024 1:42 AM




ELECTRICAL ABBREVIATIONS LIST

1P	1 POLE (2P, 3P, 4P, ETC.)	AS	AMP SWITCH	CMPR	COMPRESSOR	DS	SAFETY DISCONNECT SWITCH	FIXT	FIXTURE	HTG	HEATING	LTG	LIGHTING	MSP	MOTOR STARTER PANELBOARD	PA	PUBLIC ADDRESS	RM	ROOM	SYM	SYMMETRICAL	V	VOLT	∠	ANGLE
A	AMPERE	AT	AMP TRIP	CONN	CONNECTION	DT	DOUBLE THROW	FLR	FLOOR	HTR	HEATER	LTNG	LIGHTNING	MSBD	MAIN SWITCHBOARD	PA	PULL BOX OR PUSHBUTTON	RSC	RIGID STEEL CONDUIT	SVS	SYSTEM	VA	VOLT-AMPERES	@	AT
AC	ABOVE COUNTER OR AIR CONDITIONER	ATS	AUTOMATIC TRANSFER SWITCH	CONST	CONSTRUCTION	DWG	DRAWING	FLUOR	FLUORESCENT	HV	HIGH VOLTAGE	LV	LOW VOLTAGE	MT	MOUNT	PE	PNEUMATIC ELECTRIC	RTU	ROOF TOP UNIT	TEL	TELEPHONE	VD	VIDEO DISPLAY TERMINAL	Δ	DELTA
ACLG	ABOVE CEILING	AUX	AUXILIARY	CONTR	CONTRACTOR	EC	ELECTRICAL CONTRACTOR	FU	FUSE	HVAC	HEATING, VENTILATING AND AIR CONDITIONING	MAX	MAXIMUM	MT.C	EMPTY CONDUIT	PED	PEDESTAL	SC	SURFACE CONDUIT	TEL/DATA	TELEPHONE/DATA	VERT	VERTICAL	'	FEET
ADO	AUTOMATIC DOOR OPENER	AV	AUDIO VISUAL	CONV	CONVECTOR	ELEC	ELECTRIC, ELECTRICAL	FUDS	FUSED SAFETY DISCONNECT SWITCH	HWP	HYDRONIC WATER PUMP	MAG.S	MAGNETIC STARTER	MTS	MANUAL TRANSFER SWITCH	PF	POWER FACTOR	SEC	SECONDARY	TERM	TERMINAL	VFD	VARIABLE FREQUENCY DRIVE	"	INCHES
AF	AMP FRAME	AWG	AMERICAN WIRE GAUGE	CP	CIRCULATING PUMP	EM	EMERGENCY	GAL	GALLON	IC	INTERRUPTING CAPACITY	MC	MECHANICAL CONTRACTOR	MTR	MOTOR, MOTORIZED	PH	PHASE	SHT	SHEET	TL	TWIST LOCK	VOL	VOLUME	#	NUMBER
AFB	ABOVE FINISHED FLOOR	BATT	BATTERY	CRT	CATHODE-RAY TUBE	EMS	ENERGY MANAGEMENT SYSTEM	GALV	GALVANIZED	IG	ISOLATED GROUND	MCB	MAIN CIRCUIT BREAKER	NEC	NATIONALLY CLOSED	PV	POST INDICATING VALVE	SIM	SIMILAR	TR	TAMPER RESISTANT	W	WATT	Ø	PHASE
AFG	ABOVE FINISHED GRADE	BD	BOARD	CT	CURRENT TRANSFORMER	EMT	ELECTRICAL METALLIC TUBING	GC	GENERAL CONTRACTOR	IMC	INTERMEDIATE METAL CONDUIT	MCC	MOTOR CONTROL CENTER	NEMA	NATIONAL ELECTRICAL	PANL	PANEL	SIN	SOLID NEUTRAL	T-STAT	THERMOSTAT	WI	WITH	C	CENTER LINE
AFI	ARC FAULT CIRCUIT INTERRUPTER	BLDG	BUILDING	CTR	CENTER	EP	ELECTRIC PNEUMATIC EQUIPMENT	GEN	GENERATOR	INCAND	INCANDESCENT	MDC	MAIN DISTRIBUTION CENTER	MDP	MAIN DISTRIBUTION PANEL	PR	PAIR	SPKR	SPEAKER	TV	TELEVISION	WG	WIRE GUARD	P	PLATE
AHU	AIR HANDLING UNIT	BMS	BUILDING MANAGEMENT SYSTEM	CU	COPPER	EQUIP	ELECTRIC WATER COOLER	GFI	GROUND FAULT CIRCUIT INTERRUPTER	IR	INFRARED	MDF	MAIN DISTRIBUTION PANEL	NFDS	NON-FUSED SAFETY DISCONNECT	PRI	PRIMARY	SP	SPARE	TVC	TELEVISION TERMINAL CABINET	WH	WATER HEATER		
AL	ALUMINUM	C	CONDUIT	DCP	DOMESTIC WATER CIRCULATING PUMP	EW	ELECTRIC WATER COOLER	GFP	GROUND FAULT PROTECTOR	I/W	INTERLOCK WITH	MFR	MANUFACTURER	SW	SWITCH	PROJ	PROJECTION	SR	SURFACE RACEWAY	TYP	TYPICAL	WP	WEATHERPROOF		
ALT	ALTERNATE	CAB	CABINET	EXIST	EXISTING	EXHA	EXHAUST	GND	GROUND	J-BOX	JUNCTION BOX	MFS	MAIN FUSED DISCONNECT SWITCH	NIC	NOT IN CONTRACT	PRV	POTENTIAL TRANSFORMER	SS	STAINLESS STEEL	UC	UNDER COUNTER	XFMR	TRANSFORMER		
AMP	AMPERE	CAT	CATALOG	DEPT	DEPARTMENT	EXP	EXPLOSION PROOF	GRS	GALVANIZED RIGID STEEL (CONDUIT)	KV	KILOVOLT	MH	MANHOLE	N.O.	NORMALLY OPEN	PT	POTENTIAL TRANSFORMER	SSW	SELECTOR SWITCH	UE	UNDERGROUND ELECTRICAL	XFR	TRANSFER		
AMPL	AMPLIFIER	CB	CIRCUIT BREAKER	DET	DETAIL	FA	FIRE ALARM	GYP BD	GYP SUM BOARD	KVAR	KILOVOLT-AMPERE REACTIVE	MIC	MICROPHONE	NPF	NORMAL POWER FACTOR	PVC	POLYVINYL CHLORIDE (CONDUIT)	S/S	STOP/START PUSHBUTTONS	UG	UNDERGROUND	STA	STATION		
ANNUN	ANNUNCIATOR	CCTV	CLOSED CIRCUIT TELEVISION	DIA	DIAMETER	FABP	FIRE ALARM BOOSTER POWER SUPPLY PANEL	HOA	HANDS-OFF-AUTOMATIC SWITCH	KW	KILOWATT	MIN	MINIMUM	NTS	NOT TO SCALE	PWR	POWER	QUN	QUANTITY	UH	UNIT HEATER	UT	UNDERGROUND TELEPHONE		
APPROX	APPROXIMATELY	CKT	CIRCUIT	DISC	DISCONNECT	EXP	EXPLOSION PROOF	HOA	HANDS-OFF-AUTOMATIC SWITCH	KW	KILOWATT	MISC	MISCELLANEOUS	OH	OVERHEAD	RCPT	RECEPTACLE	STD	STANDARD	UT	UNDERGROUND TELEPHONE	UTL	UTILITY		
AQ-STAT	AQUASTAT	CLS	CEILING	DIST	DISTRIBUTION	HP	HORSEPOWER	HPF	HIGH POWER FACTOR	KWH	KILOWATT HOUR	MMS	MANUAL MOTOR STARTER	OHD	OVERHEAD DOOR	REQD	REQUIRED	SURF	SURFACE MOUNTED	UTL	UTILITY	UV	UNIT VENTILATOR OR ULTRAVIOLET		
ARCH	ARCHITECT, ARCHITECTURAL	COMB	COMBINATION	DPR	DAMPER	LOC	LOCATE OR LOCATION	HT	HEIGHT	LOC	LOCATE OR LOCATION	MOA	MULTIOUTLET ASSEMBLY	OL	OVERLOADS	REQD	REQUIRED	RM	ROOM	REQD	REQUIRED	SWBD	SWITCHBOARD		

 LIGHTING LEGEND

-  1' X 4' PENDANT OR SURFACE MOUNTED EMERGENCY LED FIXTURE WITH EMERGENCY BATTERY BACKUP BALLAST. PROVIDE THIRD WIRE FOR EMERGENCY MODE BYPASS IF SWITCHED (TYPICAL). "AE" DENOTES FIXTURE TYPE; NUMERAL DENOTES CIRCUIT NUMBER. "a" SUBSCRIPT DENOTES SWITCH CONTROL WHERE SHOWN
-  WALL MOUNTED EMERGENCY LED FIXTURE WITH EMERGENCY BATTERY BACKUP BALLAST. PROVIDE THIRD WIRE FOR EMERGENCY MODE BYPASS IF SWITCHED (TYPICAL). "WE" DENOTES FIXTURE TYPE; NUMERAL DENOTES CIRCUIT NUMBER. "c" SUBSCRIPT DENOTES SWITCH CONTROL WHERE SHOWN
-  WALL MOUNTED EXIT SIGN. ARROWS DENOTE DIRECTION OF EGRESS. NUMERAL DENOTES CIRCUIT NUMBER. SHADED CHEVRONS DENOTE EXIT FACES.
-  POLE MOUNTED SPORTS LIGHT FIXTURE

   POWER LEGEND

-  ELECTRICAL CABINET
-  208V PANELBOARD-SURFACE MOUNTED
P = PANEL
2 = 208V
G = GENERAL
L = LIGHTING
M = MECHANICAL
1 = PANEL NUMBER
-  LIGHTING HANDHOLE
-  POWER HANDHOLE
-  FUSIBLE SAFETY SWITCH - RATING AND TYPE AS NOTED ON THE DRAWING. (30 AMP, 20 AMP FUSE, 3 POLE)
-  VARIABLE FREQUENCY DRIVE
-  MOTOR, NUMERAL DENOTES HORSE POWER

LIGHTING CONTROL LEGEND

- LIGHTING CONTROL SWITCHES
(MOUNT 4'-0" AFF UNLESS NOTED OTHERWISE.)
-  SINGLE POLE SWITCH, "a" SUBSCRIPT DENOTES CIRCUITS CONTROLLED.

RECEPTACLE LEGEND

- (MOUNT 18" AFF TO CENTER LINE UNLESS NOTED OTHERWISE)
-  DUPLEX CONVENIENCE GROUND FAULT CIRCUIT INTERRUPTER (GFCI) OUTLET MOUNTED 18" ABOVE FINISHED FLOOR UNLESS NOTED OTHERWISE NEXT TO OUTLET ON DRAWING.
WP = WEATHERPROOF

GENERAL NOTES

- DRAWINGS ARE DIAGRAMMATIC ONLY. THE EXACT LOCATION, MOUNTING HEIGHTS, SIZE OF EQUIPMENT AND ROUTING OF RACEWAYS SHALL BE COORDINATED AND DETERMINED IN THE FIELD.
- ALL STRAIGHT FEEDER, BRANCH CIRCUIT AND AUXILIARY SYSTEM CONDUIT RUNS SHALL BE PROVIDED WITH SUFFICIENT PULL BOXES TO LIMIT THE MAXIMUM LENGTH OF ANY SINGLE CABLE PULL TO 150 FEET. EXACT SIZES OF PULL BOXES AND LOCATIONS TO BE DETERMINED IN THE FIELD BY THE ELECTRICAL CONTRACTOR.
- FURNISH ALL REQUIRED ACCESS PANELS AS REQUIRED TO SUIT FIELD CONDITIONS FOR THE PROPER OPERATION AND MAINTENANCE OF THE ELECTRICAL SYSTEM. THE EXACT SIZES AND PHYSICAL LOCATIONS SHALL BE TO SUIT ACCESSIBILITY AND CONSTRUCTION CONDITIONS. ALL ACCESS PANELS PROVIDED BY THE ELECTRICAL CONTRACTOR SHALL MATCH EXACTLY THE ACCESS PANELS FURNISHED AND INSTALLED BY THE GENERAL CONTRACTOR. THE ACCESS PANELS WILL BE INSTALLED BY THE TRADE CONTRACTOR UNDER THE APPROPRIATE SECTION OF THE SPECIFICATIONS FOR THE SURFACE IN WHICH THE PANELS ARE LOCATED.
- THE ELECTRICAL CONTRACTOR SHALL COORDINATE WITH ALL OTHER CONTRACTORS AS APPLICABLE AS TO THE EXACT LOCATION OF THEIR RESPECTIVE EQUIPMENT; THE POWER WIRING, CONTROL WIRING AND ALL ELECTRICAL CONNECTIONS AND CONDUIT TURN-UPS SHALL BE COORDINATED WITH THE RESPECTIVE CONTRACTORS BEFORE THE START OF CONSTRUCTION IN THE FIELD.
- COMBINED HOMERUNS OF TWO (2) OR THREE (3) CIRCUITS MAY BE UTILIZED. HOWEVER, THE NEUTRAL CONDUCTOR IS TO BE INCREASED TO #10AWG. COMBINED HOMERUNS ARE TO BE LIMITED TO 20A LIGHTINGS AND POWER CIRCUITS.
- WORK SHALL CONFORM TO THE FOLLOWING CODES: 2026 NATIONAL ELECTRICAL CODE WITH MASSACHUSETTS AMENDMENTS, MASSACHUSETTS BUILDING CODE, NFPA AND REQUIREMENTS OF LOCAL AUTHORITIES HAVING JURISDICTION.
- THE WORD "CONTRACTOR" AS USED IN THE "ELECTRICAL WORK" SHALL MEAN THE ELECTRICAL CONTRACTOR.
- CONTRACTOR SHALL PAY FOR ALL PERMITS, INSURANCE AND TESTS, AND SHALL PROVIDE LABOR AND MATERIAL TO COMPLETE THE ELECTRICAL WORK SHOWN.
- CONTRACTOR SHALL PAY ELECTRIC UTILITY COMPANY BACKCHARGES
- CONTRACTOR SHALL PROVIDE ALL REQUIRED COORDINATION WITH ELECTRIC UTILITIES.
- EXCEPT AS OTHERWISE NOTED, THE ELECTRICAL WORK SHALL INCLUDE PANELBOARDS, CIRCUIT BREAKERS, FEEDERS, WIRING, RACEWAYS AND LIGHTING FIXTURES.
- THE CONTRACTOR SHALL PROVIDE ALL TEMPORARY LIGHTING AND POWER AND THE GENERAL CONTRACTOR SHALL PAY ALL ENERGY CHARGES FOR TEMPORARY POWER AND LIGHTING.
- DURING CONSTRUCTION, THE ELECTRICAL CONTRACTOR SHALL KEEP HIS PORTION OF THE WORK NEAT, CLEAN AND ORDERLY.
- ALL SYSTEMS SHALL BE TESTED FOR SHORT CIRCUIT AND GROUNDS PRIOR TO ENERGIZING AND ANY DEFECTS SHALL BE CORRECTED.
- ALL CUTTING AND PATCHING REQUIRED FOR ELECTRICAL WORK SHALL BE INCLUDED AS PART OF THIS SECTION.
- COMPLETE SHOP DRAWINGS SHALL BE SUBMITTED FOR ELECTRICAL EQUIPMENT. WHERE SPECIFIED ELECTRICAL EQUIPMENT IS SUBSTITUTED, THE ELECTRICAL CONTRACTOR SHALL SUBMIT COMPLETE SPECIFICATIONS ON THE SUBSTITUTE AS WELL AS THE ITEM ORIGINALLY SPECIFIED.
- MATERIALS SHALL BE SPECIFICATION GRADE AND UL LISTED.
- WHERE MATERIAL IS CALLED OUT IN THE LEGEND BY MANUFACTURER, TYPE OR CATALOG NUMBER, SUCH DESIGNATIONS ARE TO ESTABLISH STANDARDS OR DESIRED QUALITY. ACCEPTANCE OR REJECTIONS OF PROPOSED SUBSTITUTIONS SHALL BE SUBJECT TO THE APPROVAL OF THE OWNER.
- WORK SHALL BE COORDINATED WITH THAT OF OTHER TRADES TO ELIMINATE INTERFERENCES.
- ELECTRICAL WORK SHALL BE GUARANTEED FOR A PERIOD OF ONE YEAR FROM DATE OF FINAL COMPLETION.
- WORK SHALL BE GROUNDED IN ACCORDANCE WITH CODE REQUIREMENTS. COMPLETE EQUIPMENT (INSULATED GREEN WIRE) GROUNDING SYSTEM SHALL BE INSTALLED.
- WIRING METHODS:
 - EXTERIOR UNDERGROUND FEEDERS SHALL BE PVC SCHEDULE 80 FOR DIRECT BURIED AND PVC SCHEDULE 40 FOR CONCRETE ENCASED.
 - EXTERIOR ABOVE GRADE FEEDERS SHALL BE RGS CONDUIT.
 - INTERIOR FEEDERS EXPOSED OR BURIED IN CONCRETE WALLS/SLABS SHALL BE RGS CONDUIT.
- NO CONDUIT OR WIRE SHALL BE RUN IN OR BELOW SLAB WITHOUT ENGINEER APPROVAL OR NOTED OTHERWISE ON THE PLANS.
- FEEDERS SHALL BE ROUTED TIGHT TO THE UNDERSIDE OF THE BUILDING STRUCTURE. CONDUIT SHALL BE INSTALLED PARALLEL AND PERPENDICULAR TO MAIN BUILDING SUPPORTS.
- FEEDER TAPS WILL NOT BE ALLOWED IN PANELBOARD GUTTERS.
- CONTRACTOR SHALL CHECK EXISTING CONDITIONS TO DETERMINE EXACT EXTENT OF WORK TO BE PERFORMED PRIOR TO BIDDING. DIMENSIONS RELEVANT TO EXISTING WORK SHALL BE VERIFIED IN THE FIELD.
- IN AREAS NOT AFFECTED BY THIS RENOVATION, THIS SUBCONTRACTOR SHALL MAINTAIN CONTINUITY OF ELECTRIC SERVICE.
- ELECTRICAL SHUTDOWN SHALL BE AT A TIME AND DATE APPROVED BY THE OWNER.
- PROVIDE AS-BUILT "CADD" DRAWINGS AT THE COMPLETION OF THE PROJECT.
- ADDRESS QUESTIONS TO THE ENGINEER IN WRITING BEFORE AWARD OF CONTRACT, OTHERWISE ENGINEER INTERPRETATION OF MEANING AND INTENT OF DRAWINGS SHALL BE FINAL.

Project: TOWN OF NANTUCKET



NOBADEER ATHLETIC FIELDS
IMPROVEMENTS

7 NOBADEER FARM ROAD



Weston & Sampson Engineers, Inc.
1 Washington Mall, 10th Floor
Boston, MA 02108

978.532.1900

800.SAMPSON

www.westonandsampson.com

Consultants:

Revisions:

No.	Date	Description

COA:

Seal:



Issued For:

BID DOCUMENTS

Scale:

AS NOTED

Date:

AUGUST 7, 2026

Drawn By:

TPV

Reviewed By:

MAS/DNM

Approved By:

AJB

W&S Project No.: ENG24-1207

W&S File No.:

Drawing Title:


ELECTRICAL
ABBREVIATIONS,
GENERAL NOTES
AND LEGENDS

Sheet Number:


E001

1 ELECTRIC
SCALE: 1" = 30'

- DRAWING NOTES:**
1. REFER TO E001 FOR ELECTRICAL ABBREVIATIONS, LEGEND AND GENERAL NOTES
 2. REFER TO E501 FOR ELECTRICAL DETAILS.
 3. REFER TO E601 FOR ELECTRICAL SCHEDULES AND ONE LINE DIAGRAM.
 4. RECESSED LED HANDRAIL LUMINAIRE.
 5. ALTERNATE #1: SCOREBOARD AND FOOTINGS.
 6. ALTERNATE #4: MUSCO LIGHTS AND FOOTINGS.

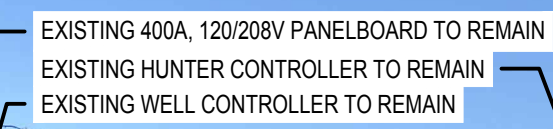

2 EXISTING SITE
SCALE: NOT TO SCALE

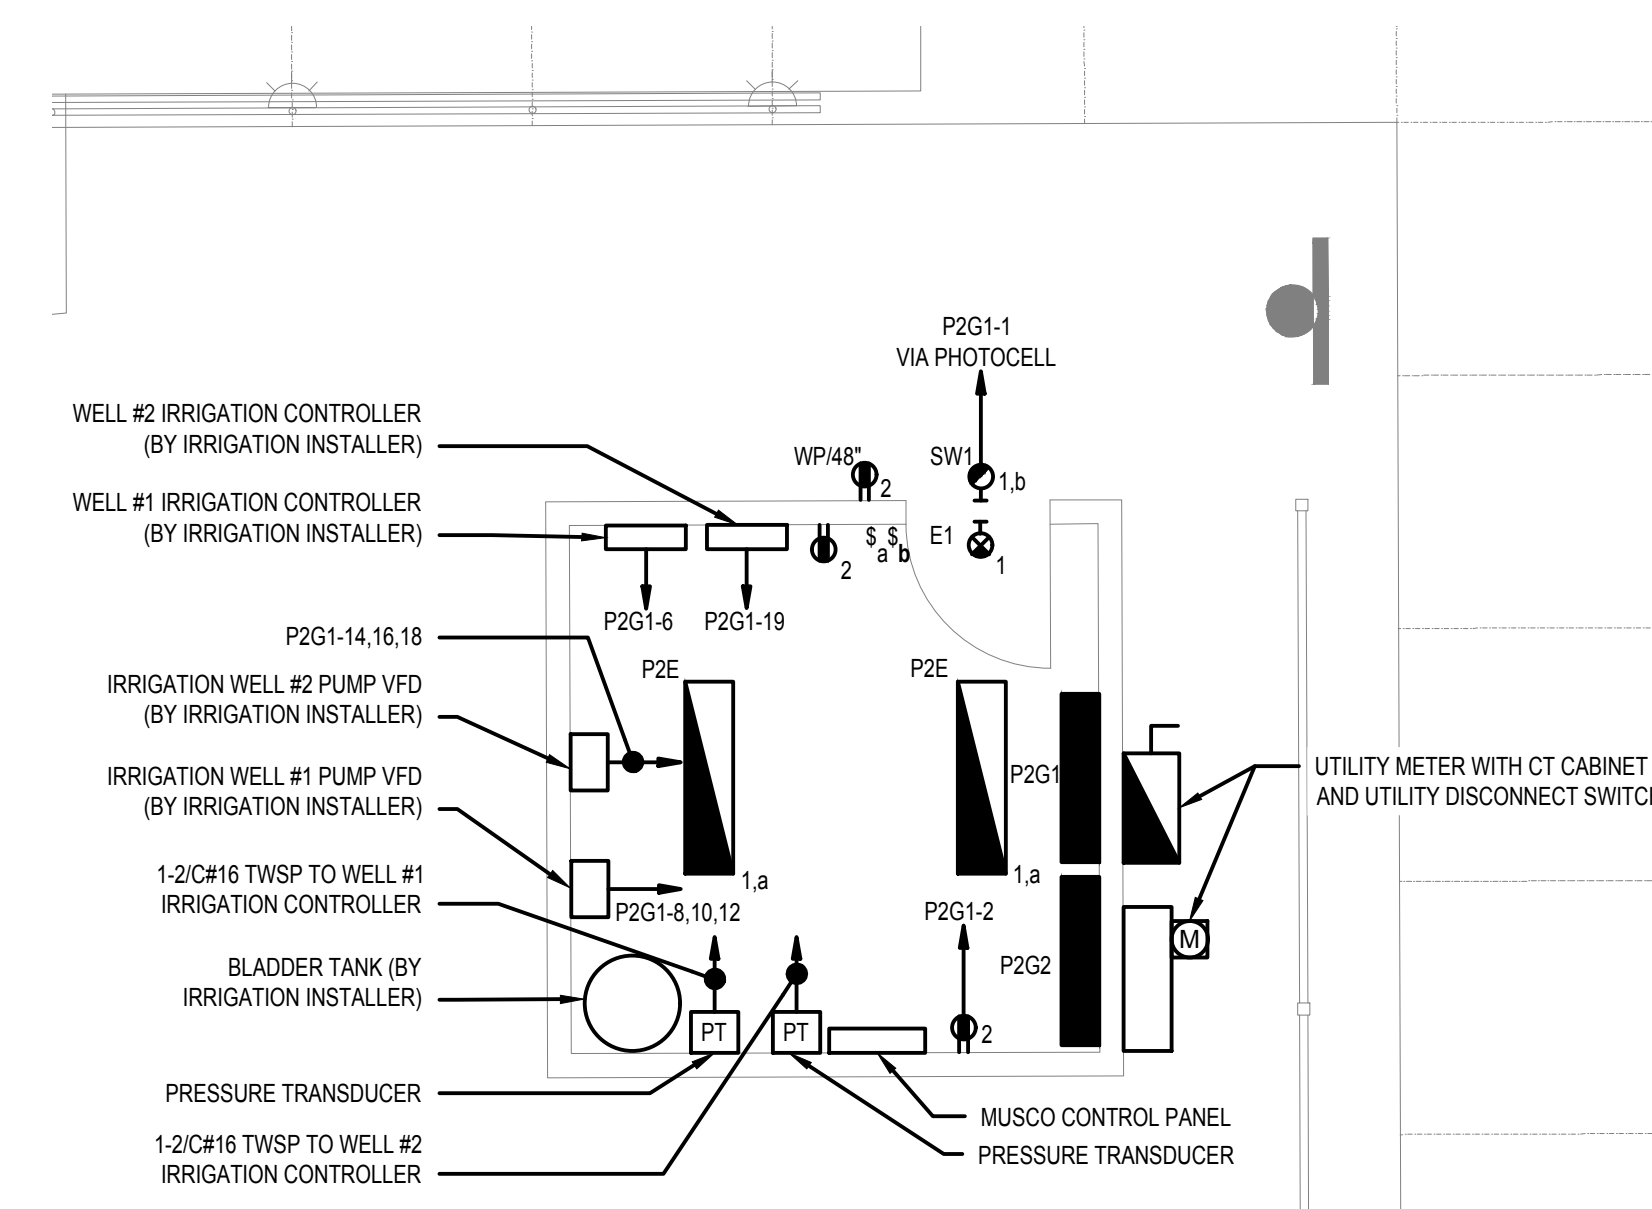

3 ELECTRICAL
SCALE: 1/4" = 1'-0"

[illegible]

COA:

Seal:

A circular professional seal for Aaron J. Belanger, a Registered Professional Engineer in the Commonwealth of Massachusetts. The seal features a serrated outer edge. The text "COMMONWEALTH OF MASSACHUSETTS" is written in a circle around the top. In the center, the name "AARON J. BELANGER" is printed above "ELECTRICAL" and "No. 60972". Below this, the words "REGISTERED" and "PROFESSIONAL ENGINEER" are printed in a semi-circle. A signature is written across the bottom half of the seal.

Issued For:

BID DOCUMENTS

Scale:	AS NOTED
--------	----------


Date:	AUGUST 7, 2026
Drawn By:	TPV
Reviewed By:	MAS/DNM
Approved By:	AJB
W&S Project No.: ENG24-1207	
W&S File No.:	

Drawing Title:


ELECTRICAL SITE PLAN

Sheet Number:


E002

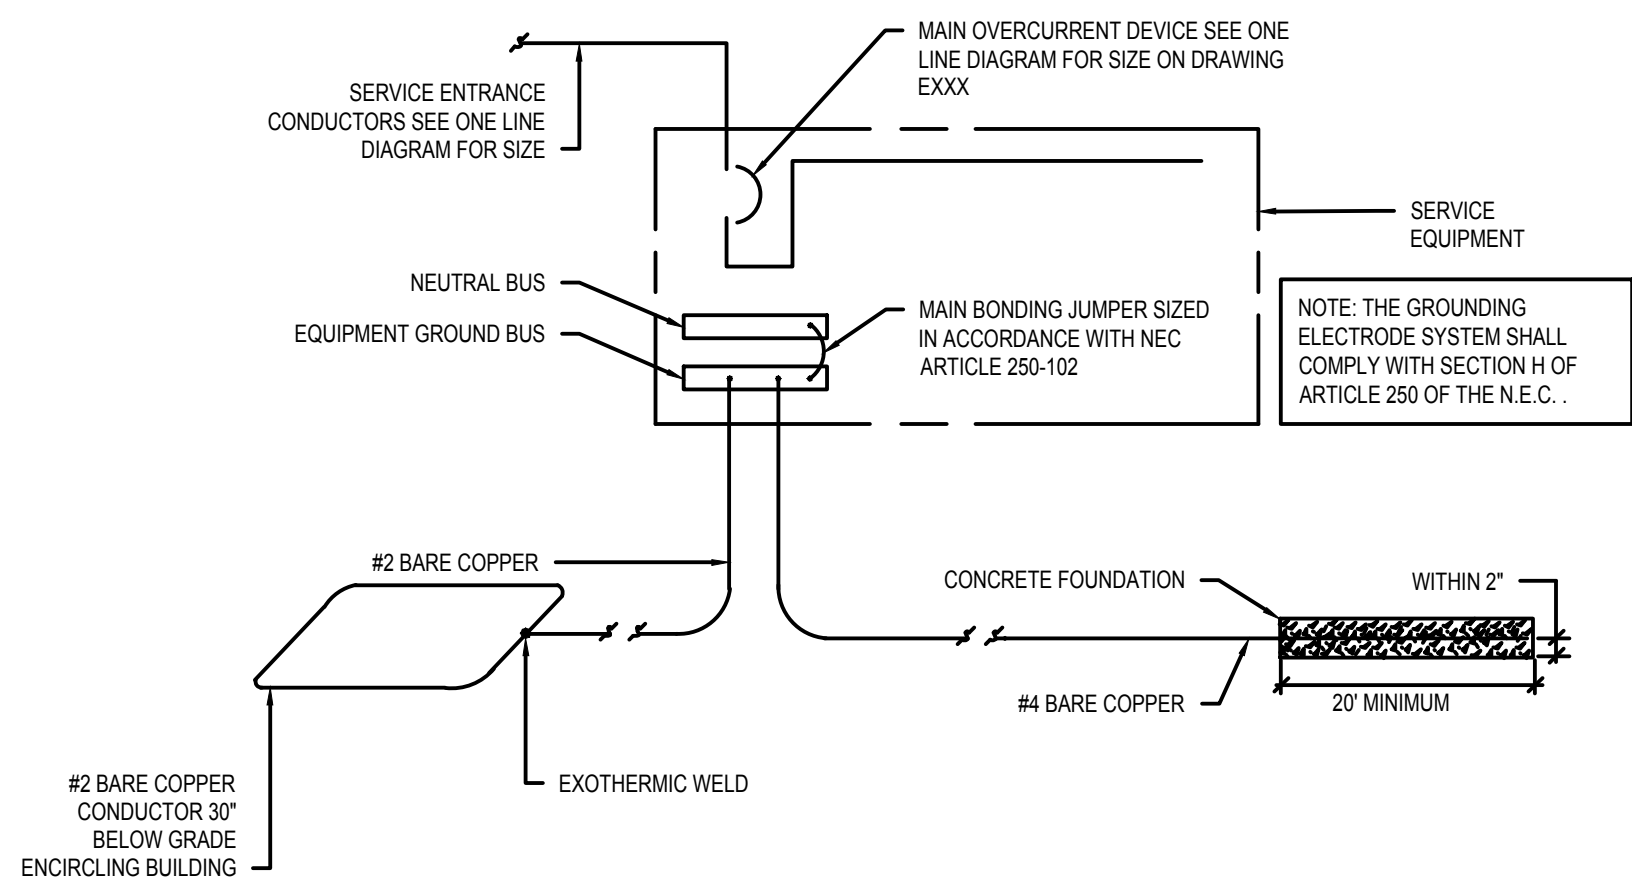


1 SERVICE GROUNDING DETAIL
NOT TO SCALE

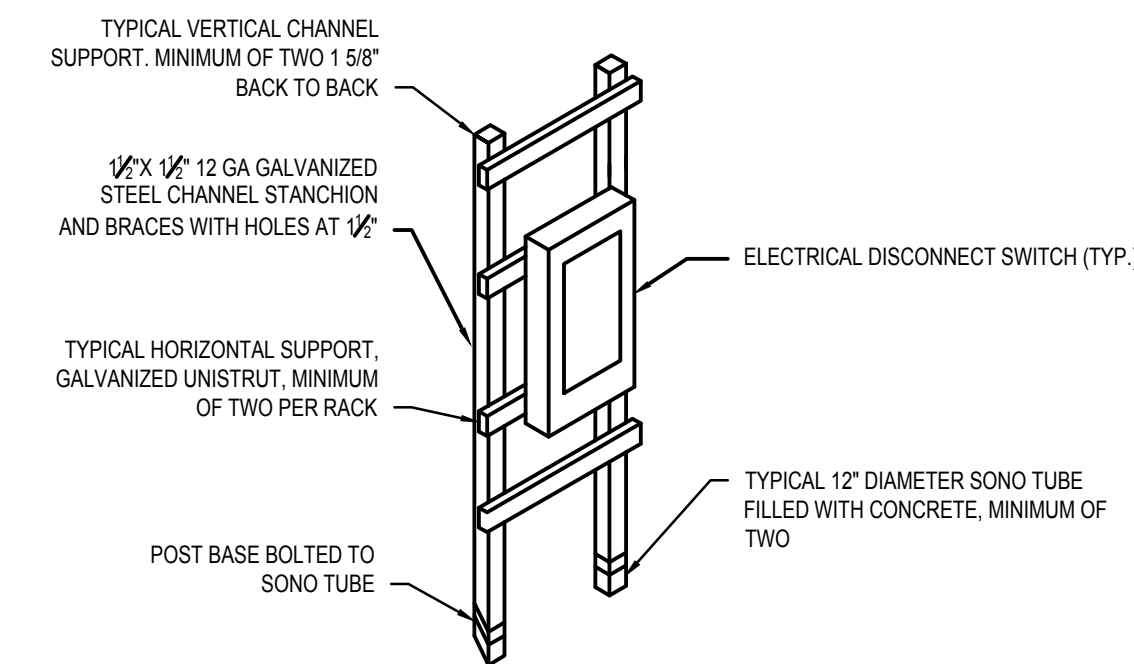

4 UNISTRUT MOUNTED EQUIPMENT DETAIL
NOT TO SCALE

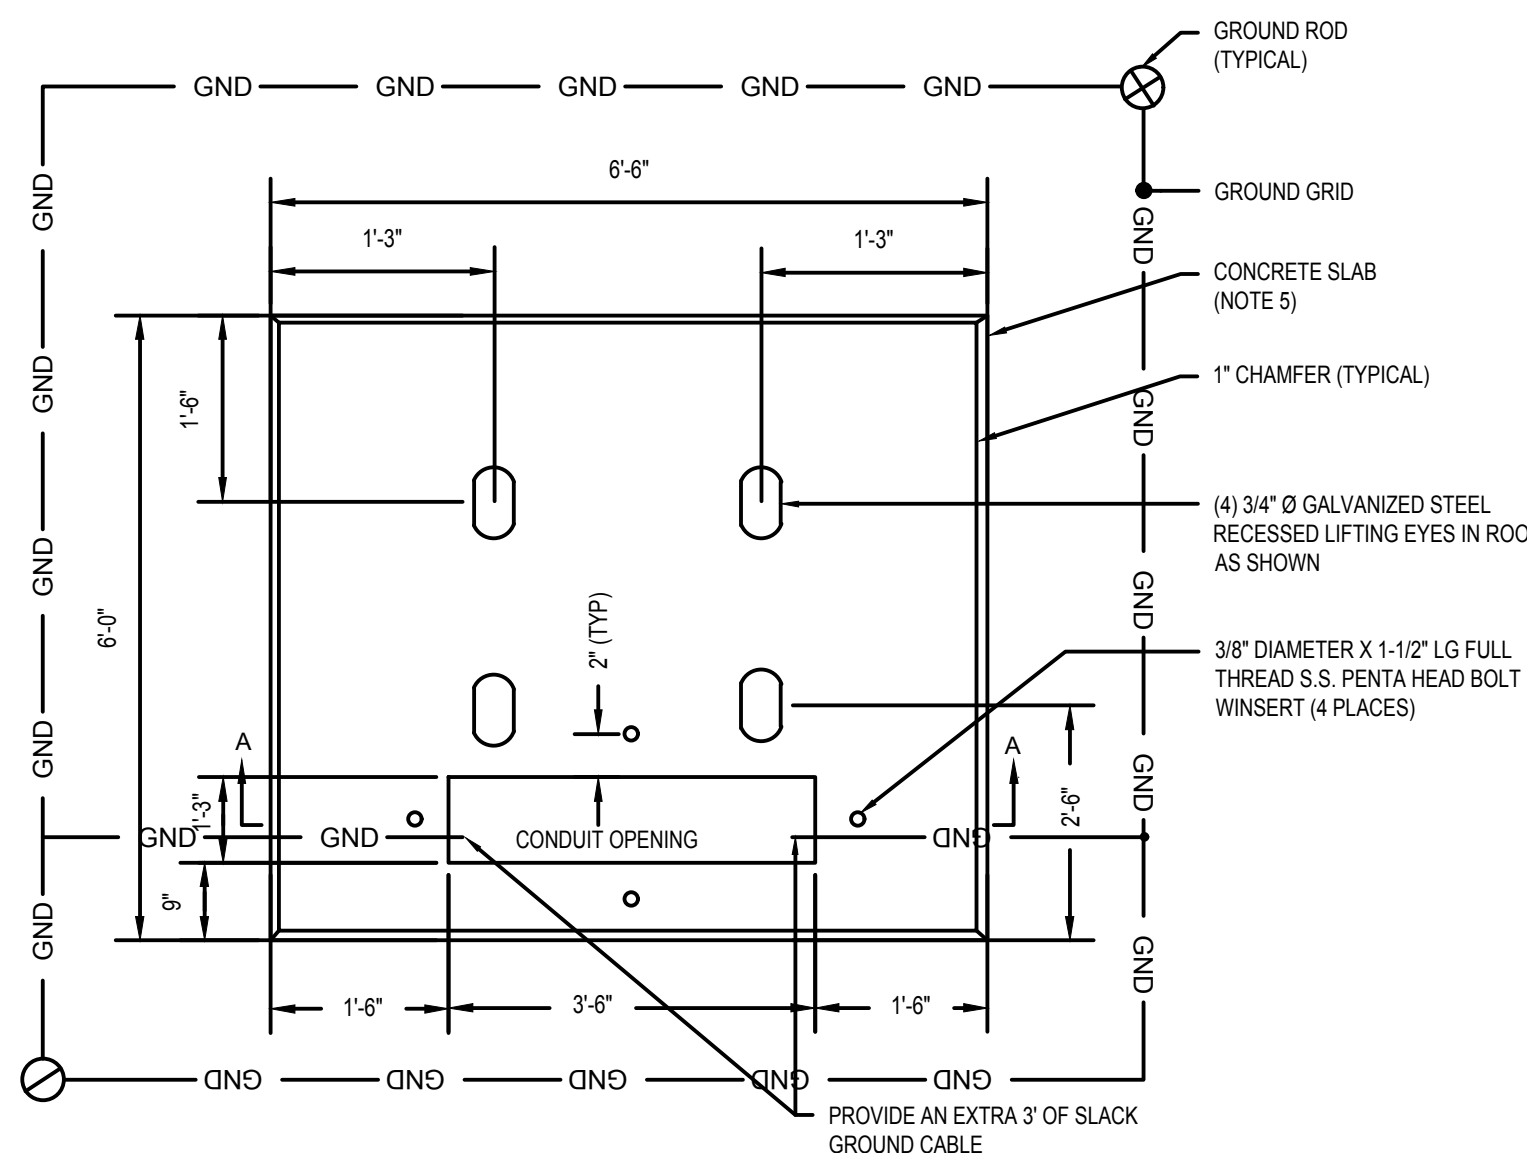


8 PAD MOUNTED UTILITY TRANSFORMER DETAIL
SCALE: NOT TO SCALE

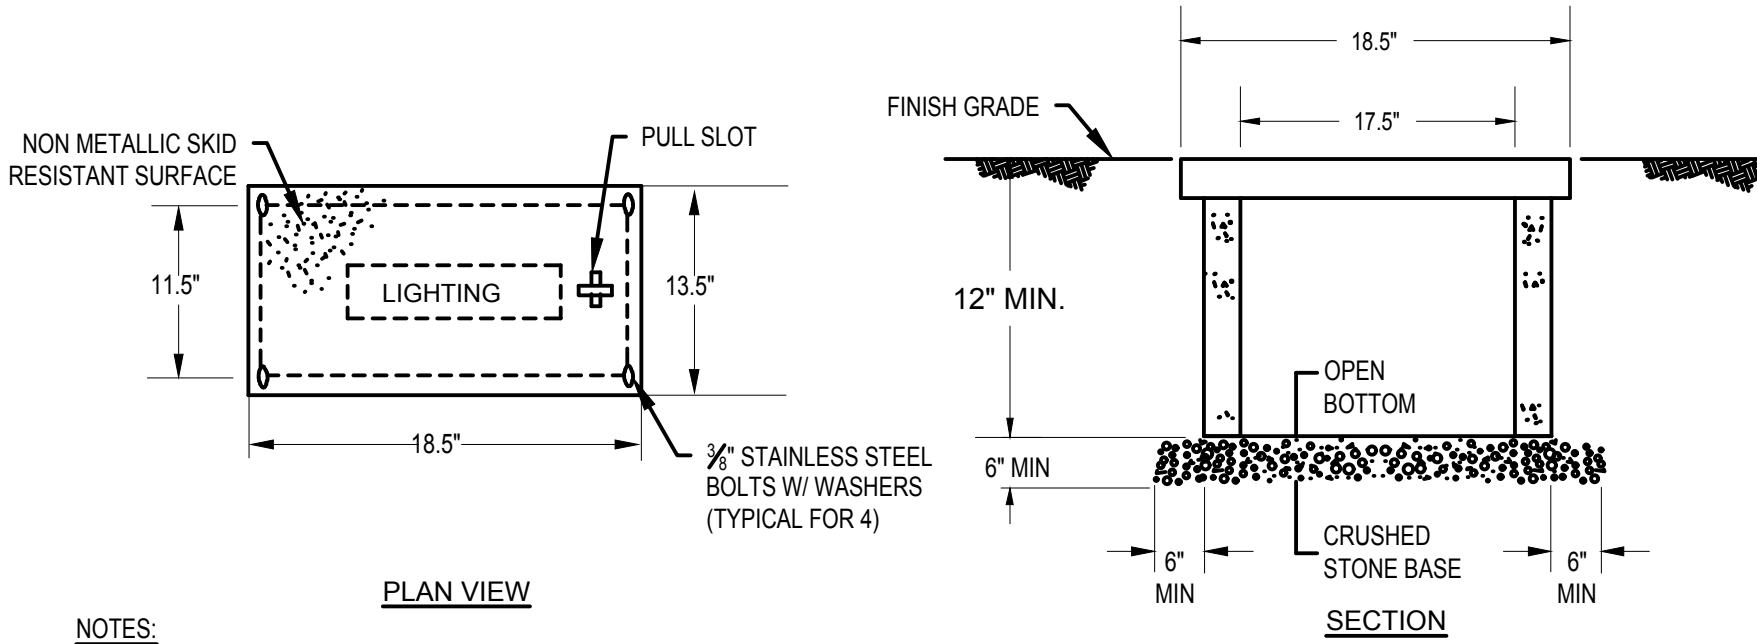


- NOTES:
- THIS HANDHOLE IS INTENDED FOR NON-DELIBERATE VEHICULAR TRAFFIC ONLY.
 - HANDHOLE SHALL BE PREFABRICATED POLYMER CONCRETE AGGREGATE EQUAL TO QUAZITE.
 - SIZE INDICATED IS THE MINIMUM ACCEPTABLE. CONTRACTOR SHALL COORDINATE EXACT SIZE REQUIRED BASED ON THE APPLICABLE NUMBER OF CONDUITS.


2 PREFABRICATED HAND HOLE DETAIL
SCALE: NOT TO SCALE

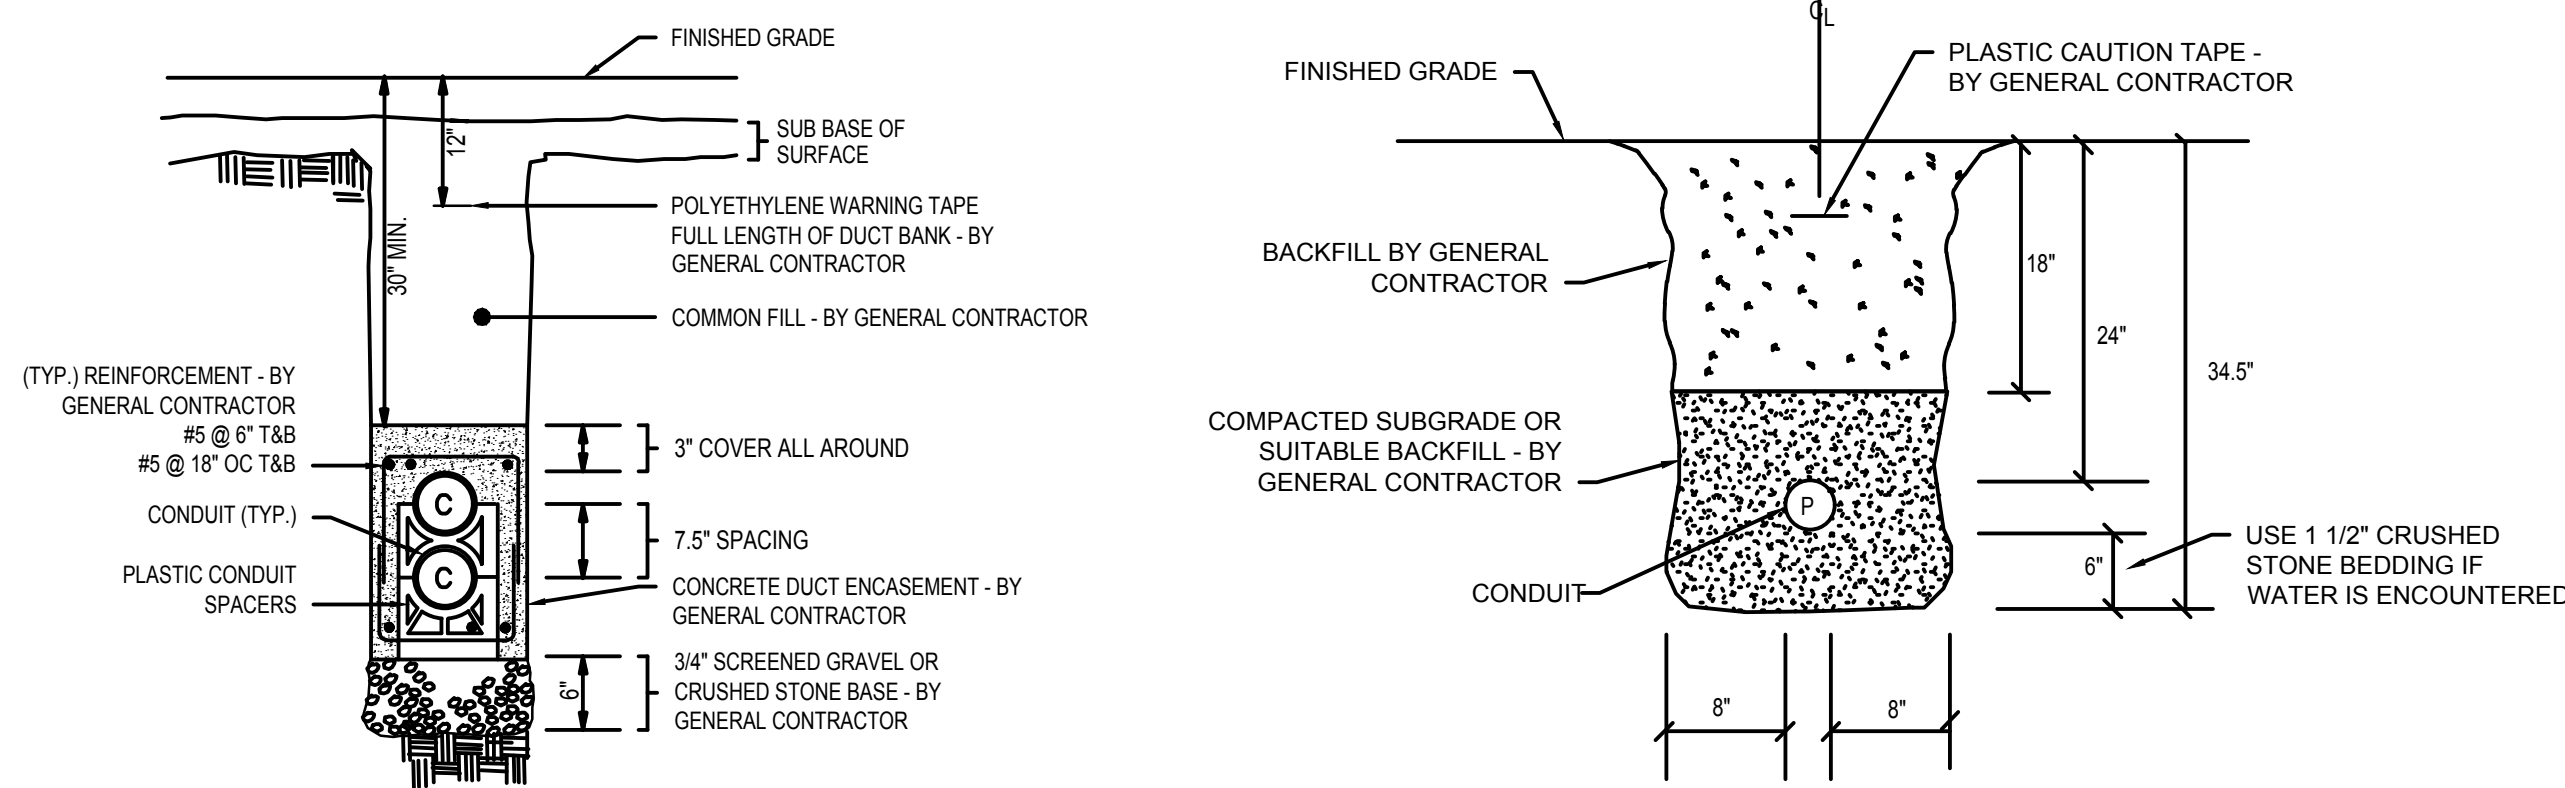

5 TYPICAL CONCRETE ENCASED CONDUIT DETAIL
SCALE: NOT TO SCALE

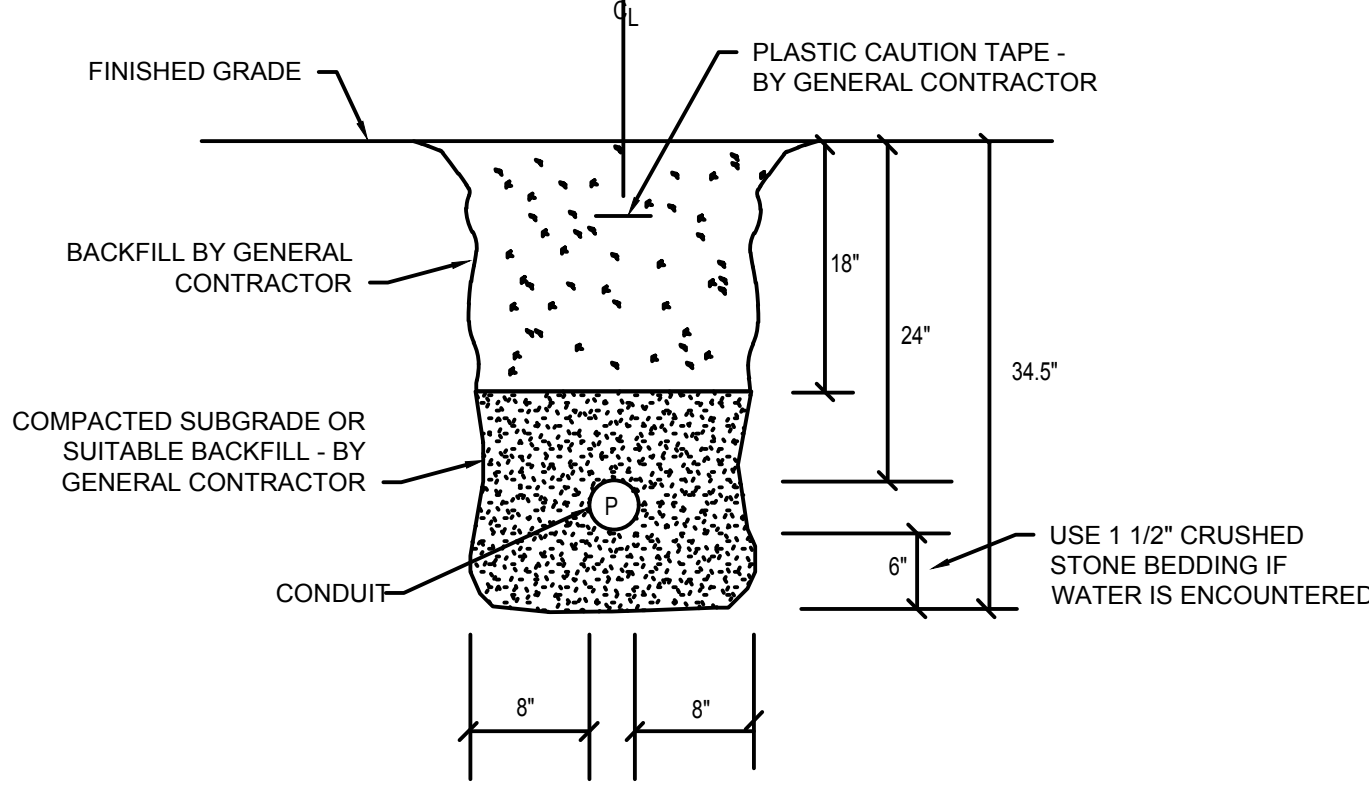


6 TYPICAL DIRECT BURIED SINGLE CONDUIT DETAIL
SCALE: NOT TO SCALE

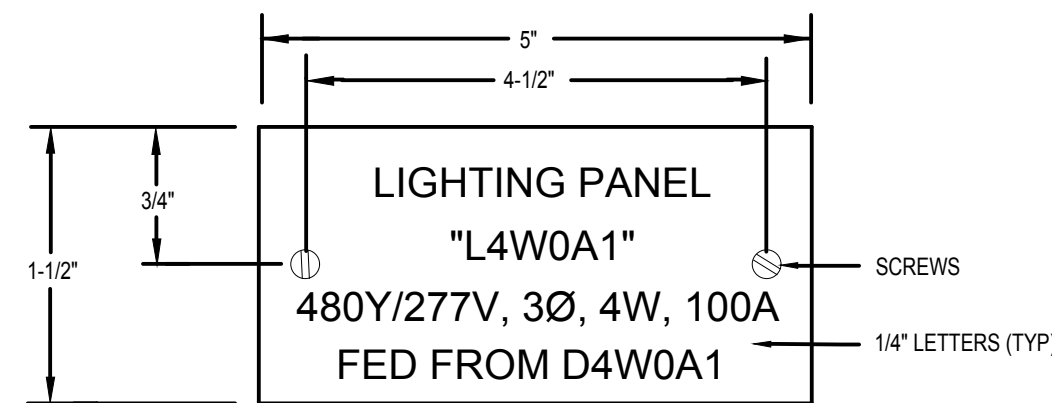

- NOTES:
- REFER TO SPECIFICATIONS FOR ADDITIONAL NAMEPLATE REQUIREMENTS.
 - NAMEPLATE TO BE 1/16" THICK WHITE PLASTIC WITH BLACK CENTER LAMINATE. FACE SHALL BE WHITE, ENGRAVED LETTERS SHALL BE BLACK.
 - SECURE NAMEPLATE TO SURFACES WITH (2) FLAT HEAD BRASS SCREWS. ADHESIVE CEMENT SHALL NOT BE ALLOWED.
 - NAMEPLATE INFORMATION SHALL INCLUDE DEVICE NAME, SUPPLY VOLTAGE, AMPERAGE AND LOCATION FED FROM.


3 TYPICAL NAMEPLATE DETAIL
NOT TO SCALE

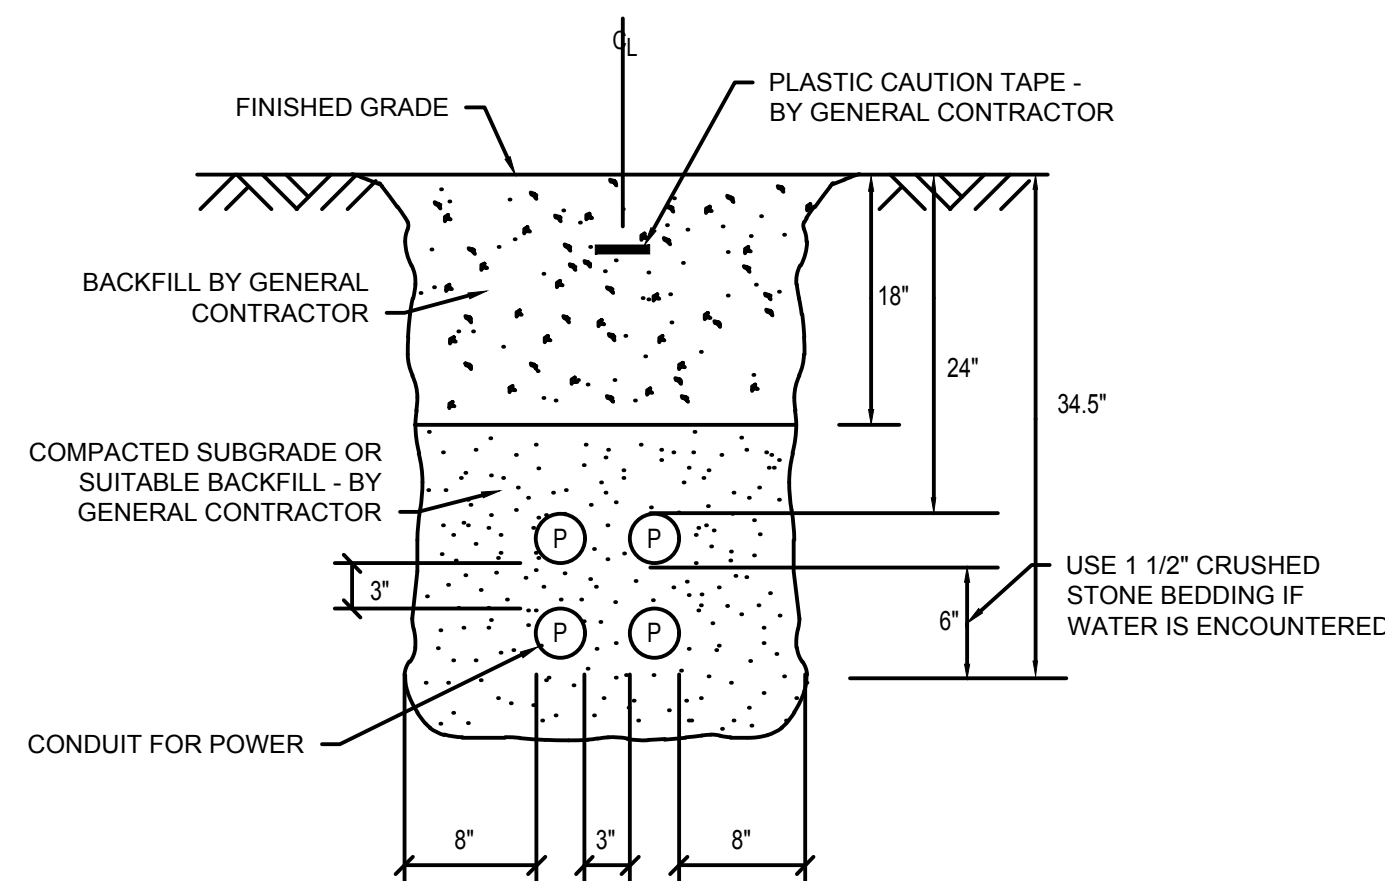

7 TYPICAL DIRECT BURIED MULTIPLE CONDUIT DETAIL
SCALE: NOT TO SCALE

PADMOUNT - FOUNDATION NOTES:

- SCOPE - THIS STANDARD COVERS SPECIFICATIONS FOR THE CONSTRUCTION OF PADMOUNT TRANSFORMER FOUNDATIONS AND GROUNDING FOR **NATIONAL GRID**.
- CONDUIT BY ELECTRICAL CONTRACTOR - INSTALL AS SHOWN BEFORE SLAB IS POURED. USE 36" RADIUS BENDS, WITH COUPLINGS, NIPPLES AND BUSHINGS AS REQUIRED. (MATERIAL MAY BE GALVANIZED STEEL, BLACK IRON, OR TYPE II FIBER OR PLASTIC.) TERMINATIONS OF CONDUITS SHALL BE LOCATED EXACTLY AS SHOWN, SOLID OR DOTTED, DEPENDING UPON NUMBER OF DUCTS. THE NIPPLE AND BUSHING SHOULD BE INSTALLED AFTER THE TRANSFORMER IS PLACED AND BEFORE THE CABLES ARE PULLED.
- GROUND GRID BY ELECTRICAL CONTRACTOR - INSTALL #10 S.D. 7 STRAND BARE COPPER WIRE LOOP 1'-0" BELOW GRADE. BOND TO ALL EXPOSED METALLIC CONDUIT AND LEAVE 3'-0" OF WIRE ABOVE PAD FOR GROUNDING TRANSFORMER AT TWO OPPOSITE POINTS IN THE CABLE CONDUIT OPENINGS. 3.A. PHOS-COPPER BRAZE CONNECTIONS, CADWELD, OR USE TWO APPROVED CONNECTORS PER JOINT. INSTALL TWO 8 FT. GALVANIZED STEEL (3/4") GROUND RODS WHERE SHOWN. LEAVE GRID EXPOSED UNTIL INSPECTED BY THE UTILITY COMPANY.
- GRAVEL & SAND BY GENERAL CONTRACTOR - SHALL BE PLACED AS SHOWN IN UTILITY CONSTRUCTION STANDARDS, THE GRAVEL BEING COMPACTED AND THE SAND THOROUGHLY WETTED JUST BEFORE PLACING THE CONCRETE.
- CONCRETE SLAB BY GENERAL CONTRACTOR - CONCRETE IN ACCORDANCE WITH UTILITY COMPANY REQUIREMENTS. REINFORCE WITH 1/2" RODS LOCATED ON A 12" X 12" GRID AND LOCATED IN THE MIDDLE OF THE SLAB.
- THE ELECTRICAL CONTRACTOR SHALL COORDINATE WITH THE UTILITY COMPANY FOR ALL INSTALLATION REQUIREMENTS PRIOR TO THE START OF ANY WORK.

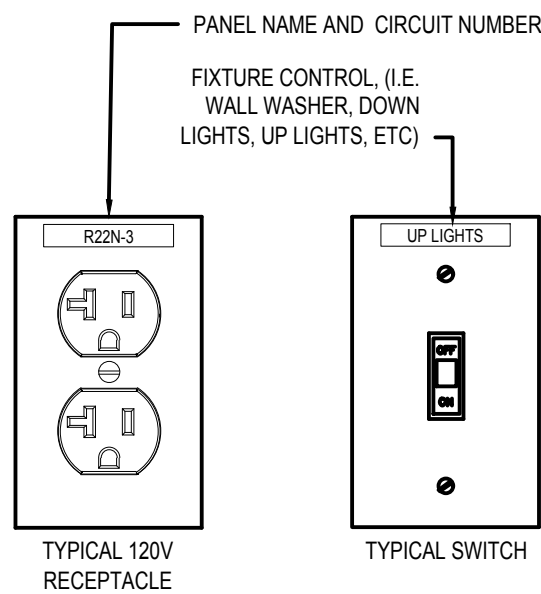

NOTE: REFER TO SPECIFICATIONS FOR LABEL MATERIAL REQUIREMENTS.

9 TYPICAL DEVICE LABELING DETAIL
SCALE: NOT TO SCALE

Consultants:

Revisions:

No.	Date	Description

COA:

Seal:



Issued For:

BID DOCUMENTS

Scale:

AS NOTED

Date: AUGUST 7, 2026

Drawn By: TPV

Reviewed By: MAS/DNM

Approved By: AUB

W&S Project No.: ENG24-1207


W&S File No.:

Drawing Title:

ELECTRICAL DETAILS

Sheet Number:

E501

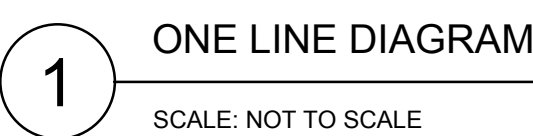

CONDUIT AND WIRE SCHEDULE									
CONDUIT TAG	FEEDER	FROM	TO	CONTACT	NO. OF FIXTURES	NO. OF OUTLETS	LOAD AMPS	CONTACT SIZE	REMARKS
C1	1"C, 3#6 & 1#10GND	MUSCO CABINET	SITE LIGHT S1	C1	1	-	10.97	30	DIRECT BURIED
C2	1"C, 3#6 & 1#10GND	MUSCO CABINET	SITE LIGHT S2	C2	1	-	10.97	30	DIRECT BURIED
C3	1"C, 3#6 & 1#10GND	MUSCO CABINET	SITE LIGHT S3	C3	1	-	10.97	30	DIRECT BURIED
C4	1"C, 3#10 & 1#10GND	MUSCO CABINET	SITE LIGHT S4	C4	1	-	10.97	30	DIRECT BURIED
C5	4"C, 4#600kcmil & 1#3GND	P2G1	NEW SITE HANDHOLE	-	-	-	EXISTING	-	DIRECT BURIED
C6	1"C, 2#12 & 1#12GND	P2G1	ACCESSIBLE RAMP	-	6	-	0.01	-	DIRECT BURIED
C7	1"C, 2#12 & 1#12GND	P2G1	SCOREBOARD	-	1	-	1.00	-	DIRECT BURIED
C8	1"C, 3#10 & 1#10GND	MUSCO CABINET	S5 HANDHOLE	C5	1	-	10.97	30	DIRECT BURIED
C9	1"C, 3#6 & 1#10GND	MUSCO CABINET	S6 HANDHOLE	C6	1	-	10.97	30	DIRECT BURIED
C10	1"C, 3#6 & 1#10GND	MUSCO CABINET	S7 HANDHOLE	C7	1	-	10.97	30	DIRECT BURIED
C11	1"C, 3#4 & 1#10GND	MUSCO CABINET	S8 HANDHOLE	C8	1	-	10.97	30	DIRECT BURIED
C12	1"C, 2#12 & 1#12GND	P2G1	SCOREBOARD	-	1	-	1.00	-	DIRECT BURIED
C13	1"C, 3#4 & 1#6GND	P2G1	IRRIGATION WELL #1 PUMP DISCONNECT	-	-	-	59.40	-	DIRECT BURIED
C14	1-1/4"C, 3#3 & 1#8GND	P2G1	IRRIGATION WELL #2 PUMP DISCONNECT	-	-	-	59.40	-	DIRECT BURIED

DISTRIBUTION BOARD SCHEDULE								
DESIGNATION: P2G2			S.C. RATING: 65KAIC			REMARKS:		
LOCATION: UTILITY SHED			SERVICE: 208Y/120V, 3PH, 4W					
RATING: 800 AMP MLO			MOUNTING: SURFACE					
MAIN: 800 AMP								
CKT. NO.	LOAD DESIGNATION	CIRCUIT BREAKER	LOAD			CIRCUIT BREAKER	LOAD DESIGNATION	CKT. NO.
			A	B	C			
1	SPORTS LIGHTING POLE S1	30	2.63			30	SPORTS LIGHTING POLE S2	2
3				2.63				4
5					2.63			6
7								8
9	SPORTS LIGHTING POLE S3	30	2.63			30	SPORTS LIGHTING POLE S4	10
11				2.63				12
13					2.63			14
15								16
17	FUTURE SPORTS LIGHTING POLE S5	30	2.63	2.63		30	FUTURE SPORTS LIGHTING POLE S6	18
19					2.63			20
21				2.63				22
23					2.63			24
25	FUTURE SPORTS LIGHTING POLE S7	30	2.63			30	FUTURE SPORTS LIGHTING POLE S8	26
27				2.63				28
29					2.63			30
31								32
33	FUTURE SPORTS LIGHTING POLE S9	30	2.63	2.63		30	FUTURE SPORTS LIGHTING POLE S10	34
35					2.63			36
37								38
39								40
41	MUSCO CONTROL PANEL	20	1.00			30	SPARE	42
43				-				44
45								46
47								48
SUB-TOTAL			16.78	15.78	15.78			
TOTAL			48.34 KVA					
ESTIMATED DEMAND LOAD			16.78 KVA					
TOTAL DEMAND CURRENT			48.68 AMPS					