


APPENDIX B
RECORD DRAWINGS


CATV RECORD DRAWINGS

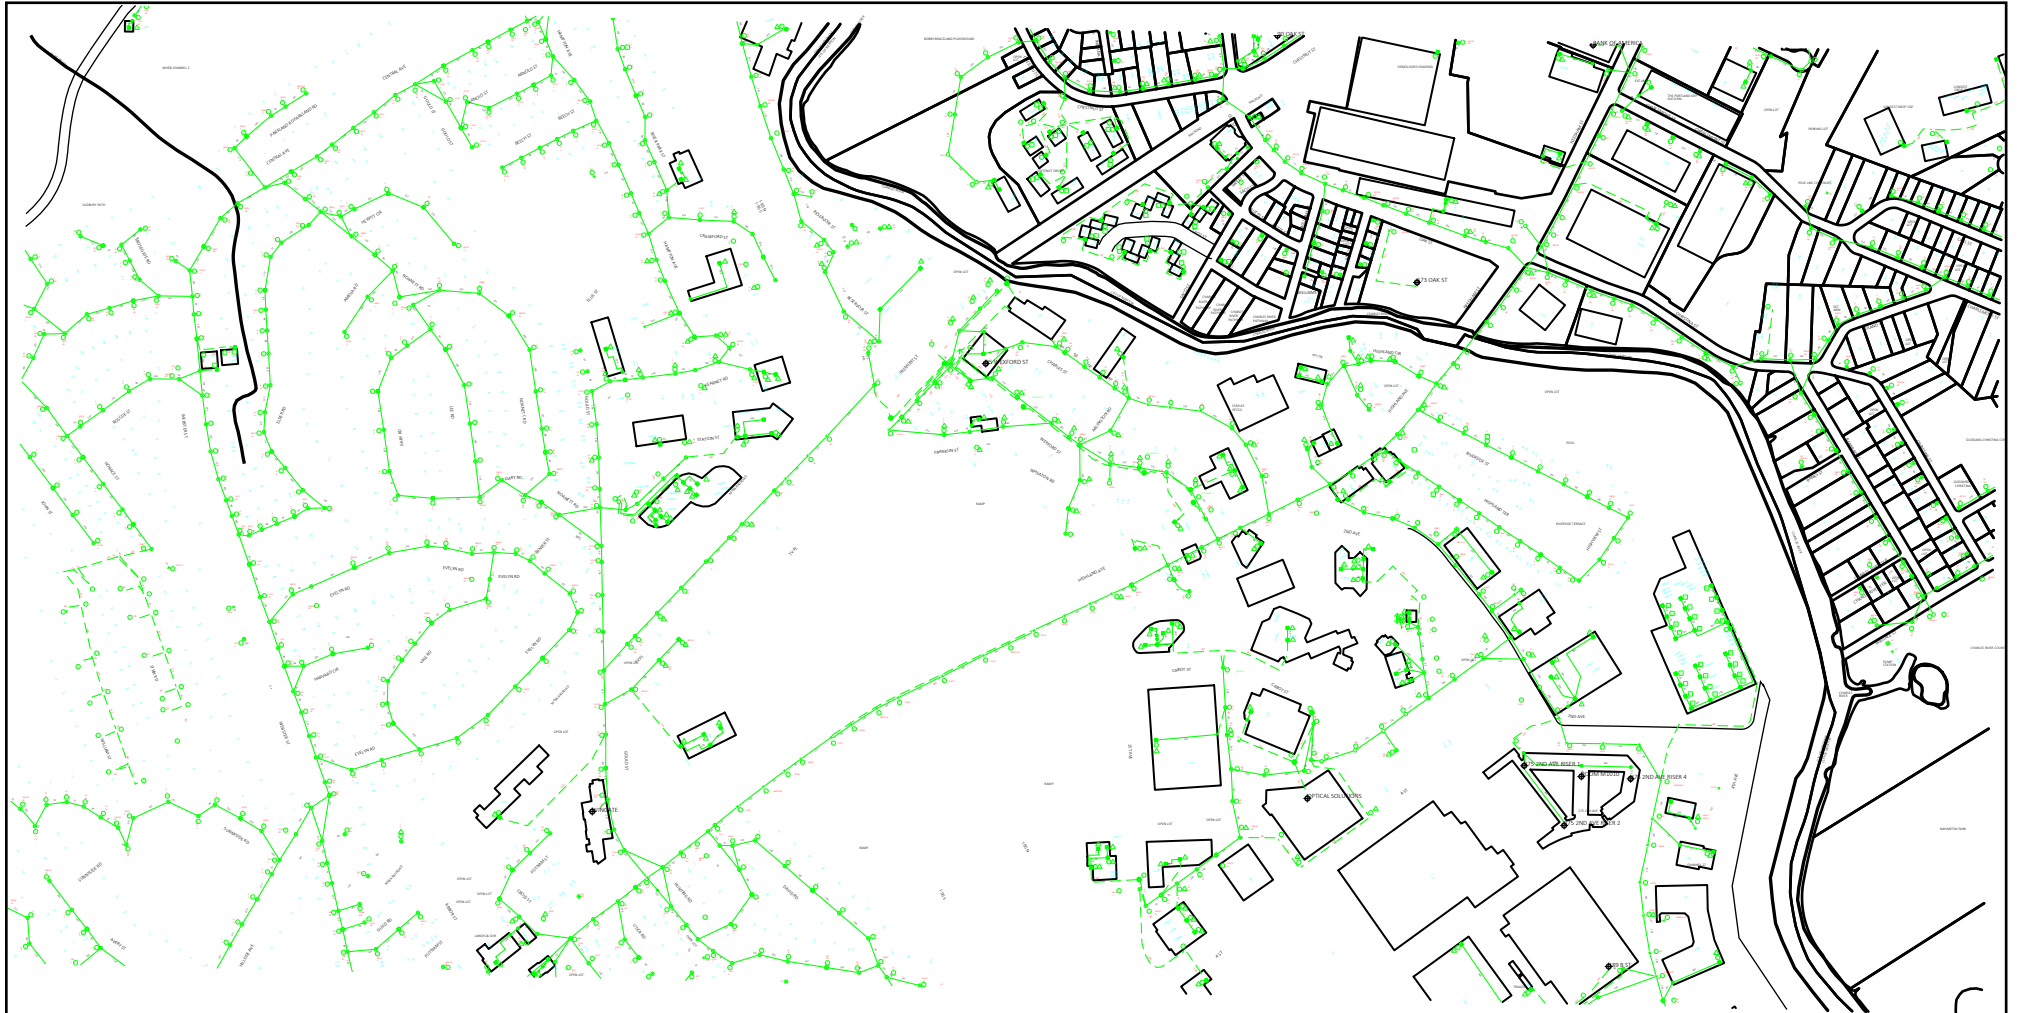



EVERSOURCE ELECTRIC RECORD DRAWINGS

EVERSOURCE GAS RECORD DRAWINGS



NEEDHAM STORM RECORD DRAWINGS

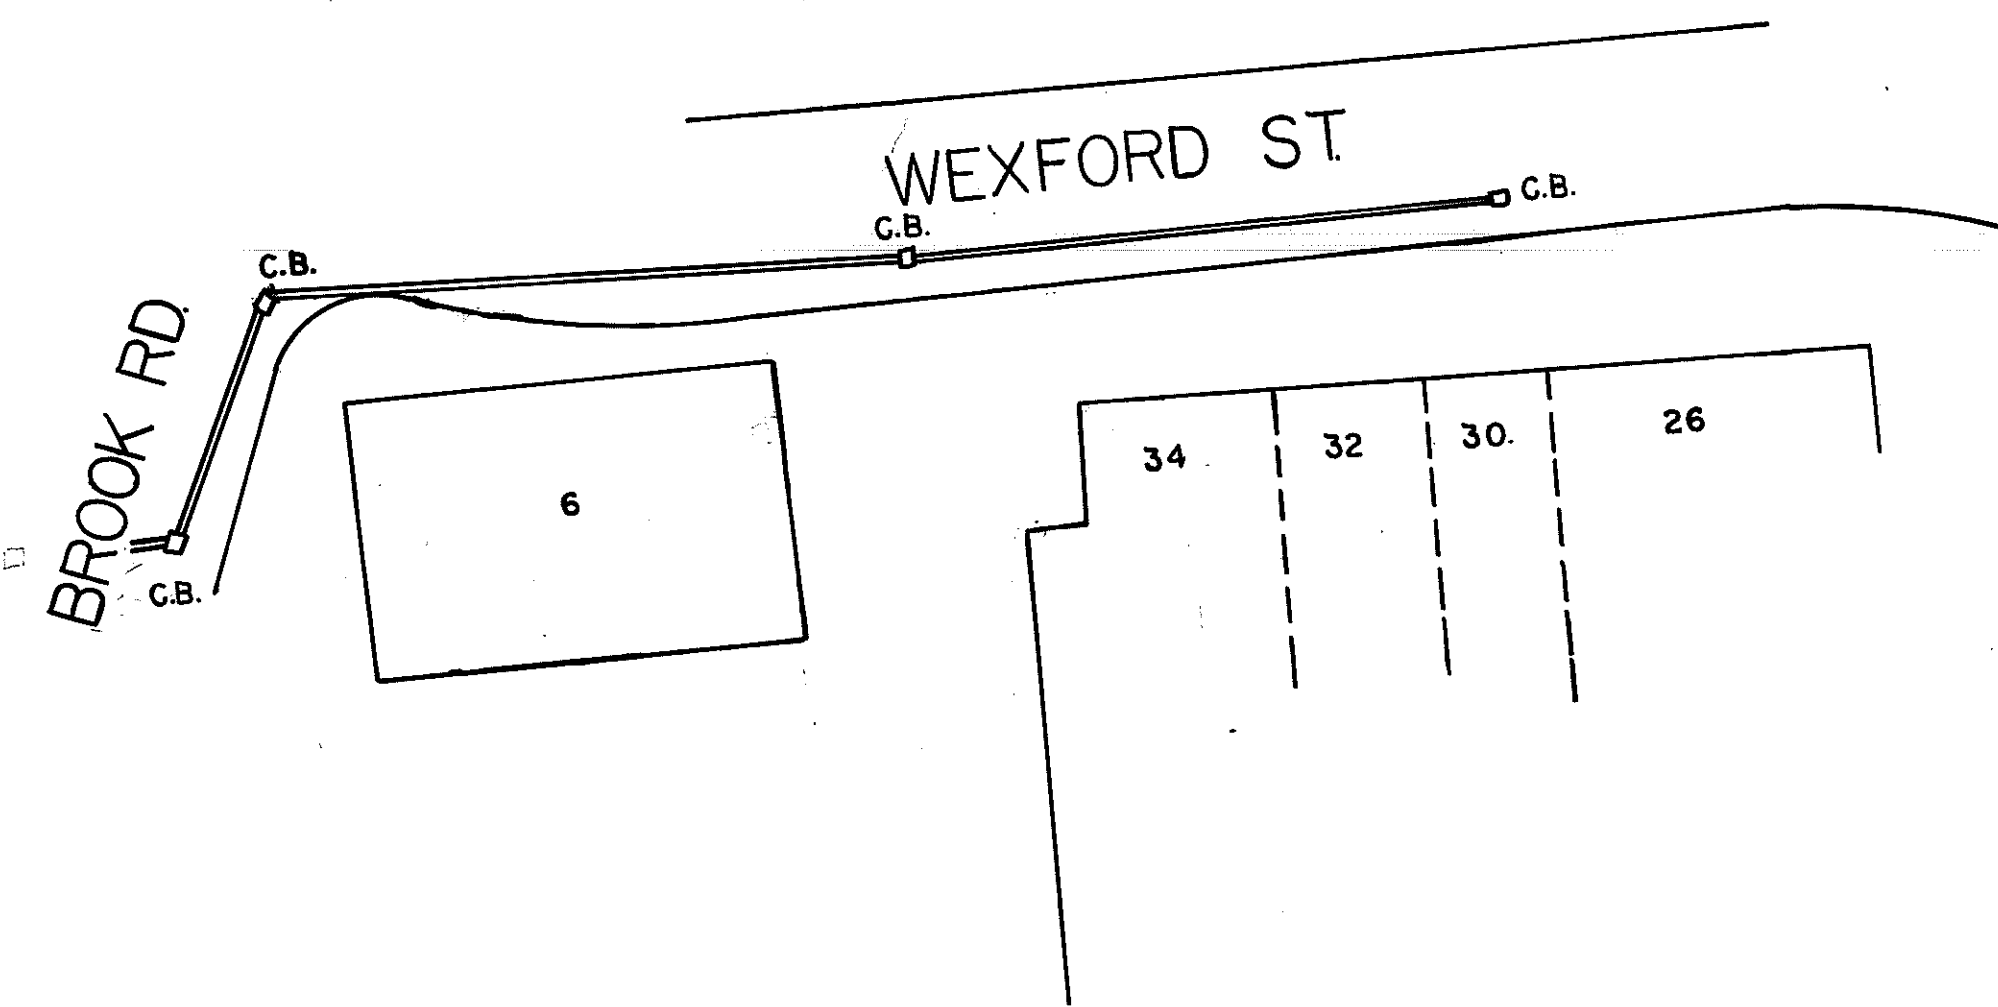





WEXFORD ST.
JULY 1978 J.D. MARR JR.
NB. 174-12 TOWN ENGINEER
SCALE: VERT. 1 IN = 4 FT.
HORIZ. 1 IN = 40 FT.

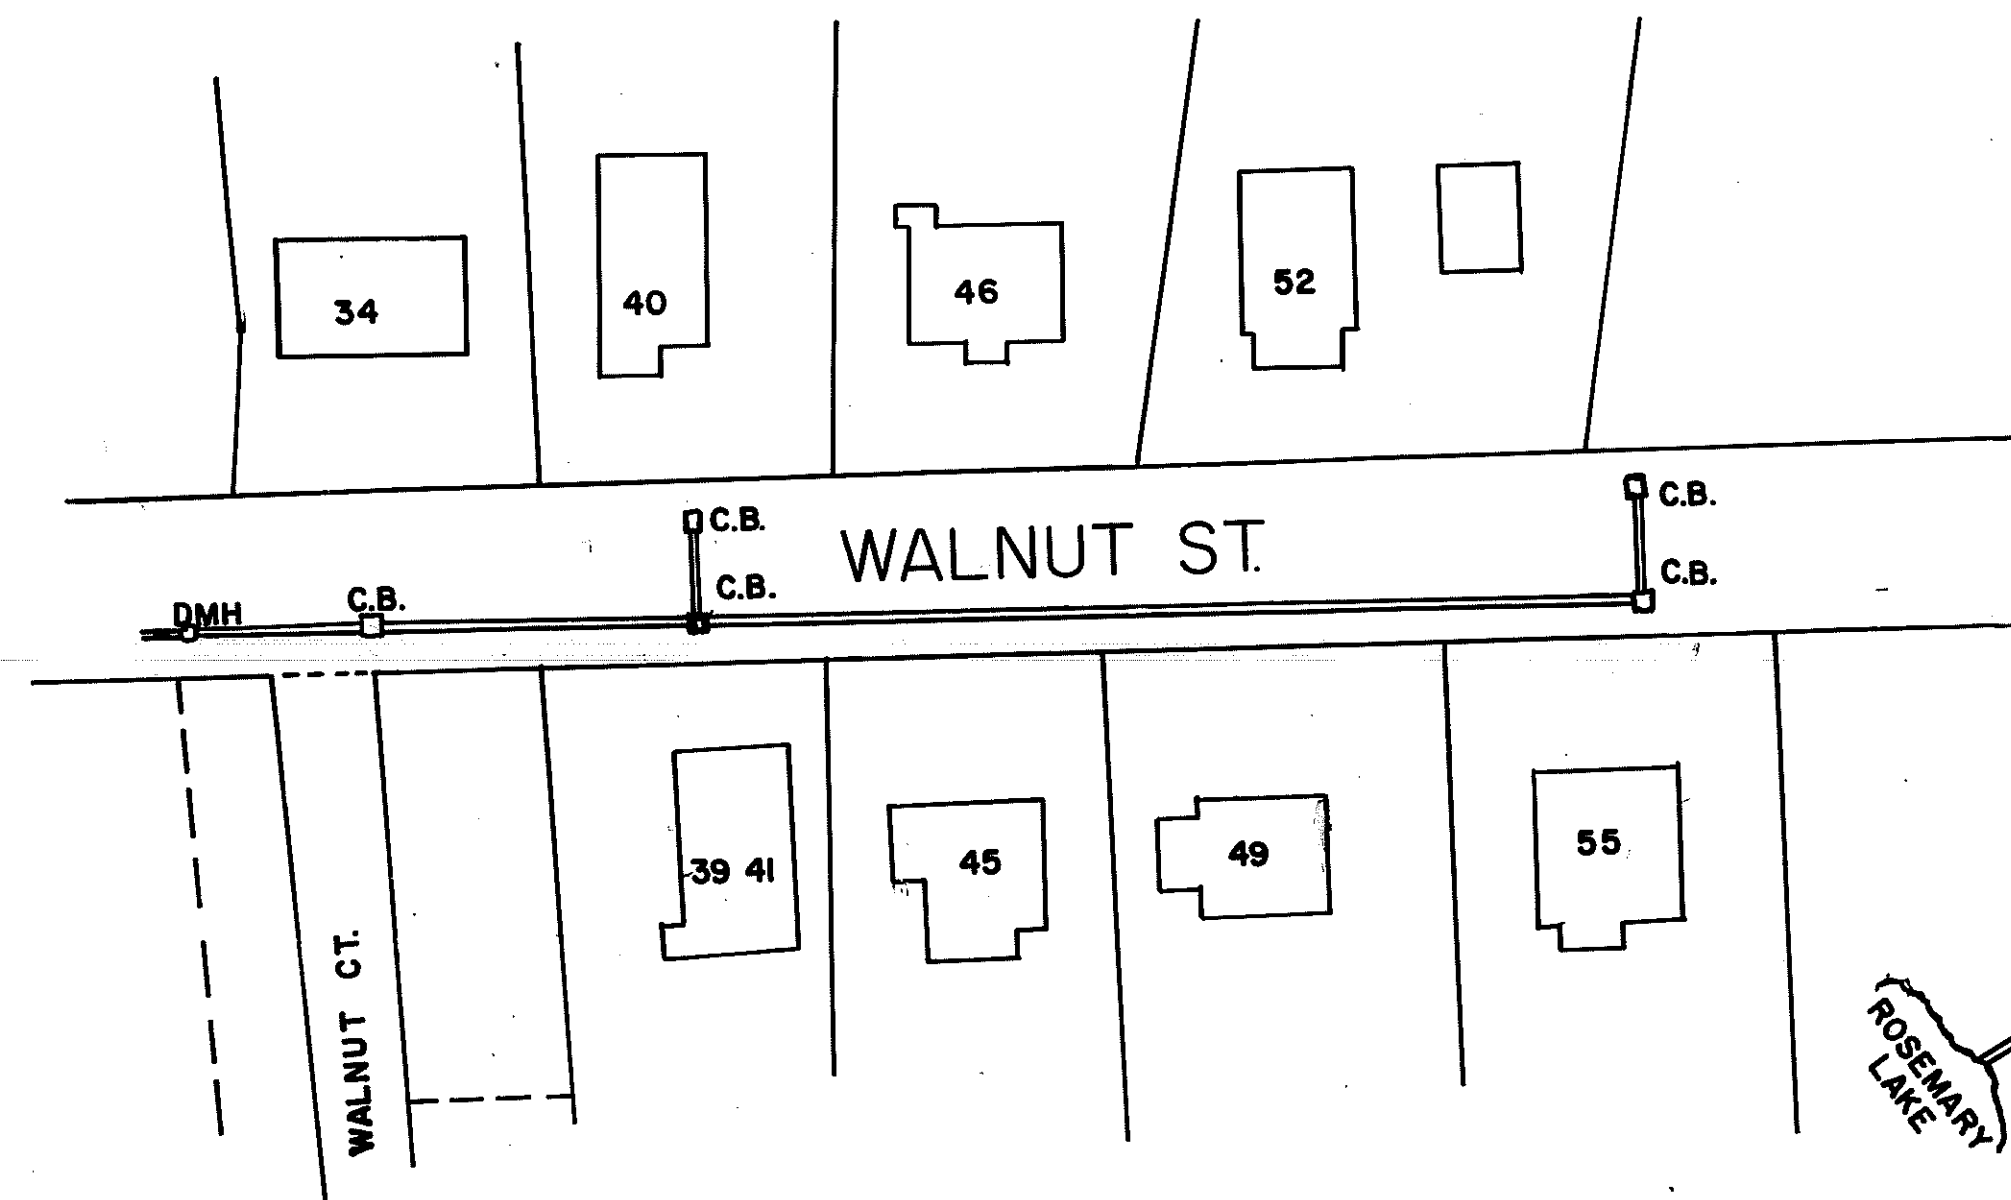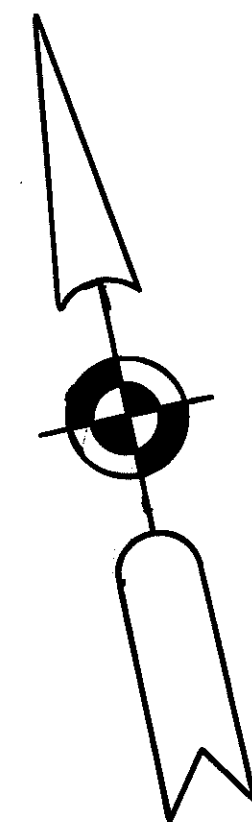


TOWN OF NEEDHAM MASS.
DRAINAGE PLAN
WALNUT ST.
APRIL 1980 J.D. MARR JR.
NB. 174-60 TOWN ENGINEER
SCALE: VERT. 1 IN = 4 FT.
HORIZ. 1 IN = 40 FT.

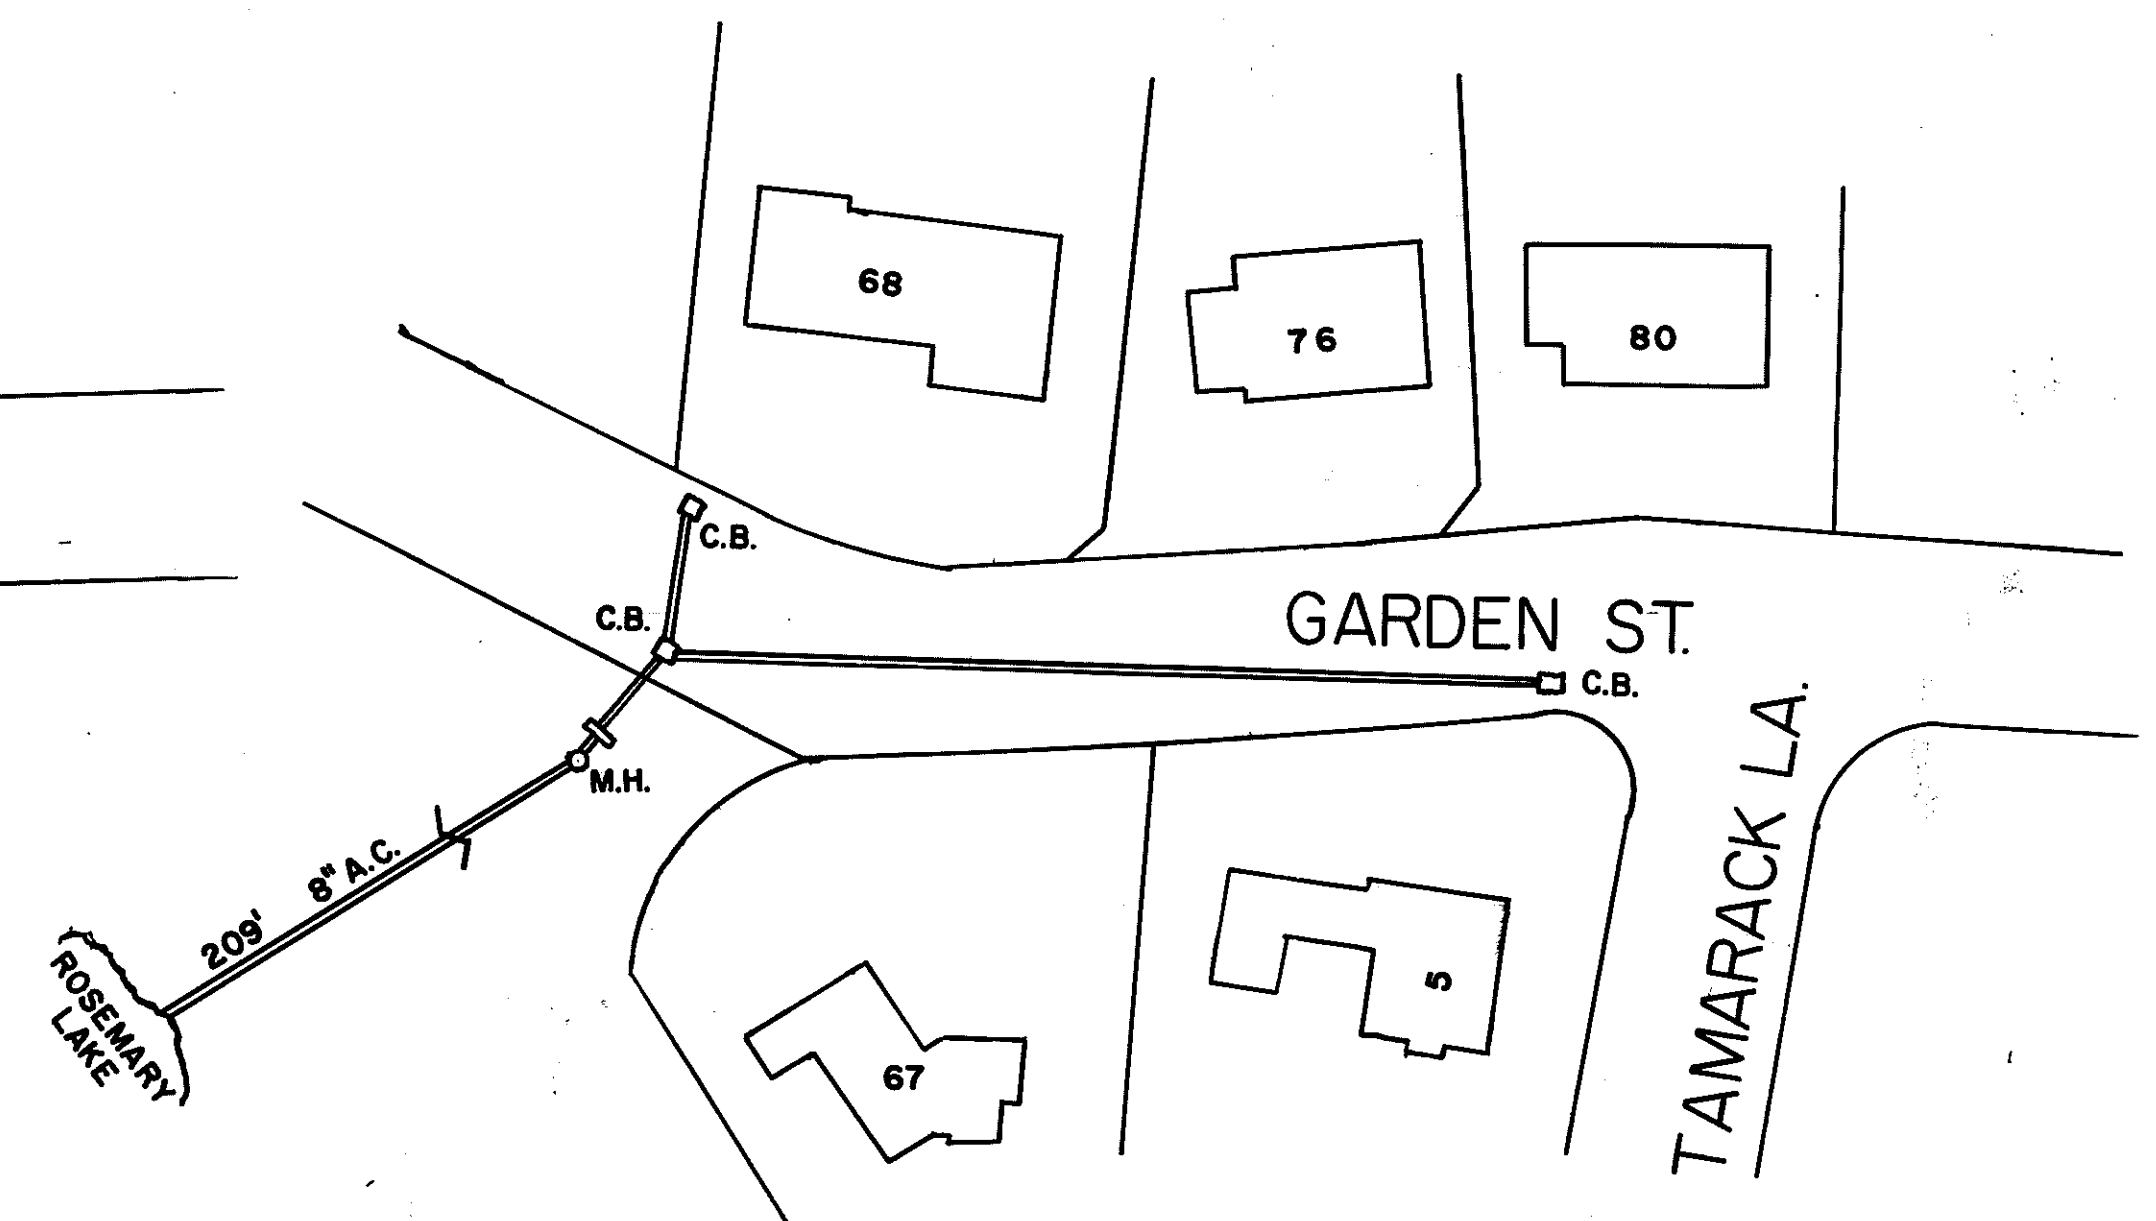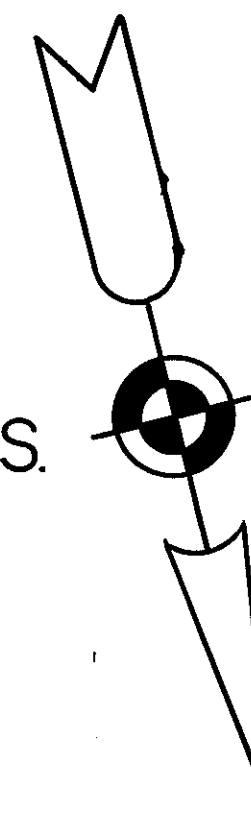


GARDEN ST
JUNE 1980 J.D. MARR JR.
NB. 174-70 TOWN ENGINEER
SCALE: VERT. 1 IN = 4 FT.
HORIZ. 1 IN = 40 FT.

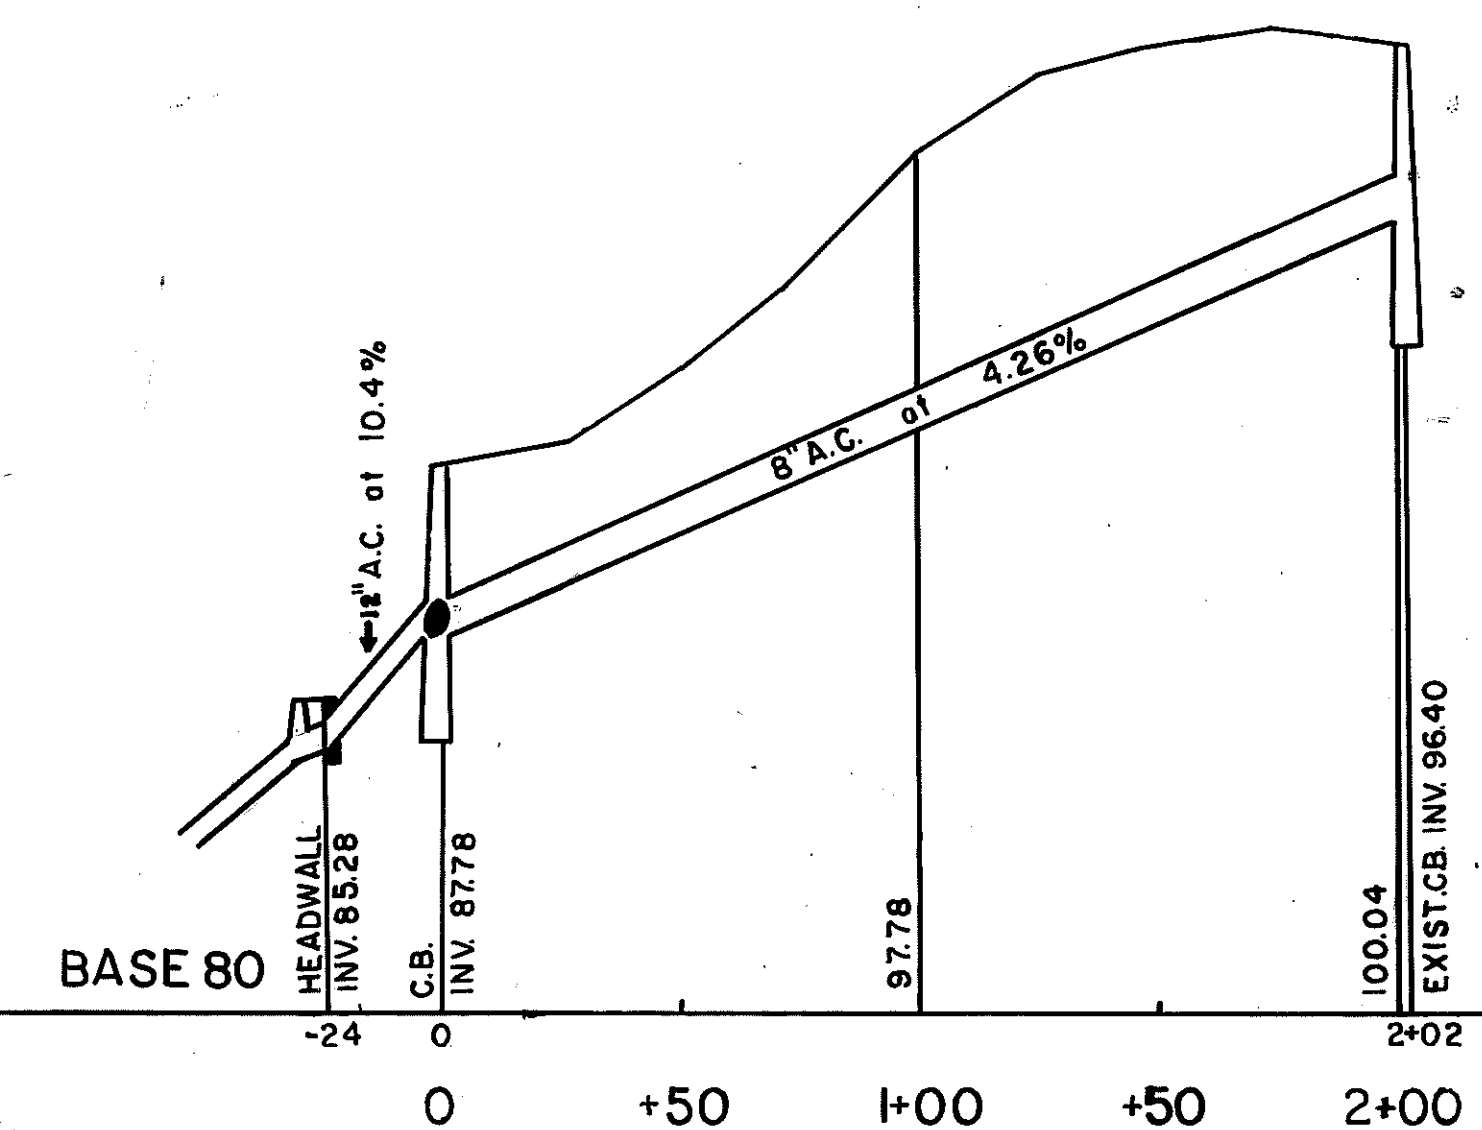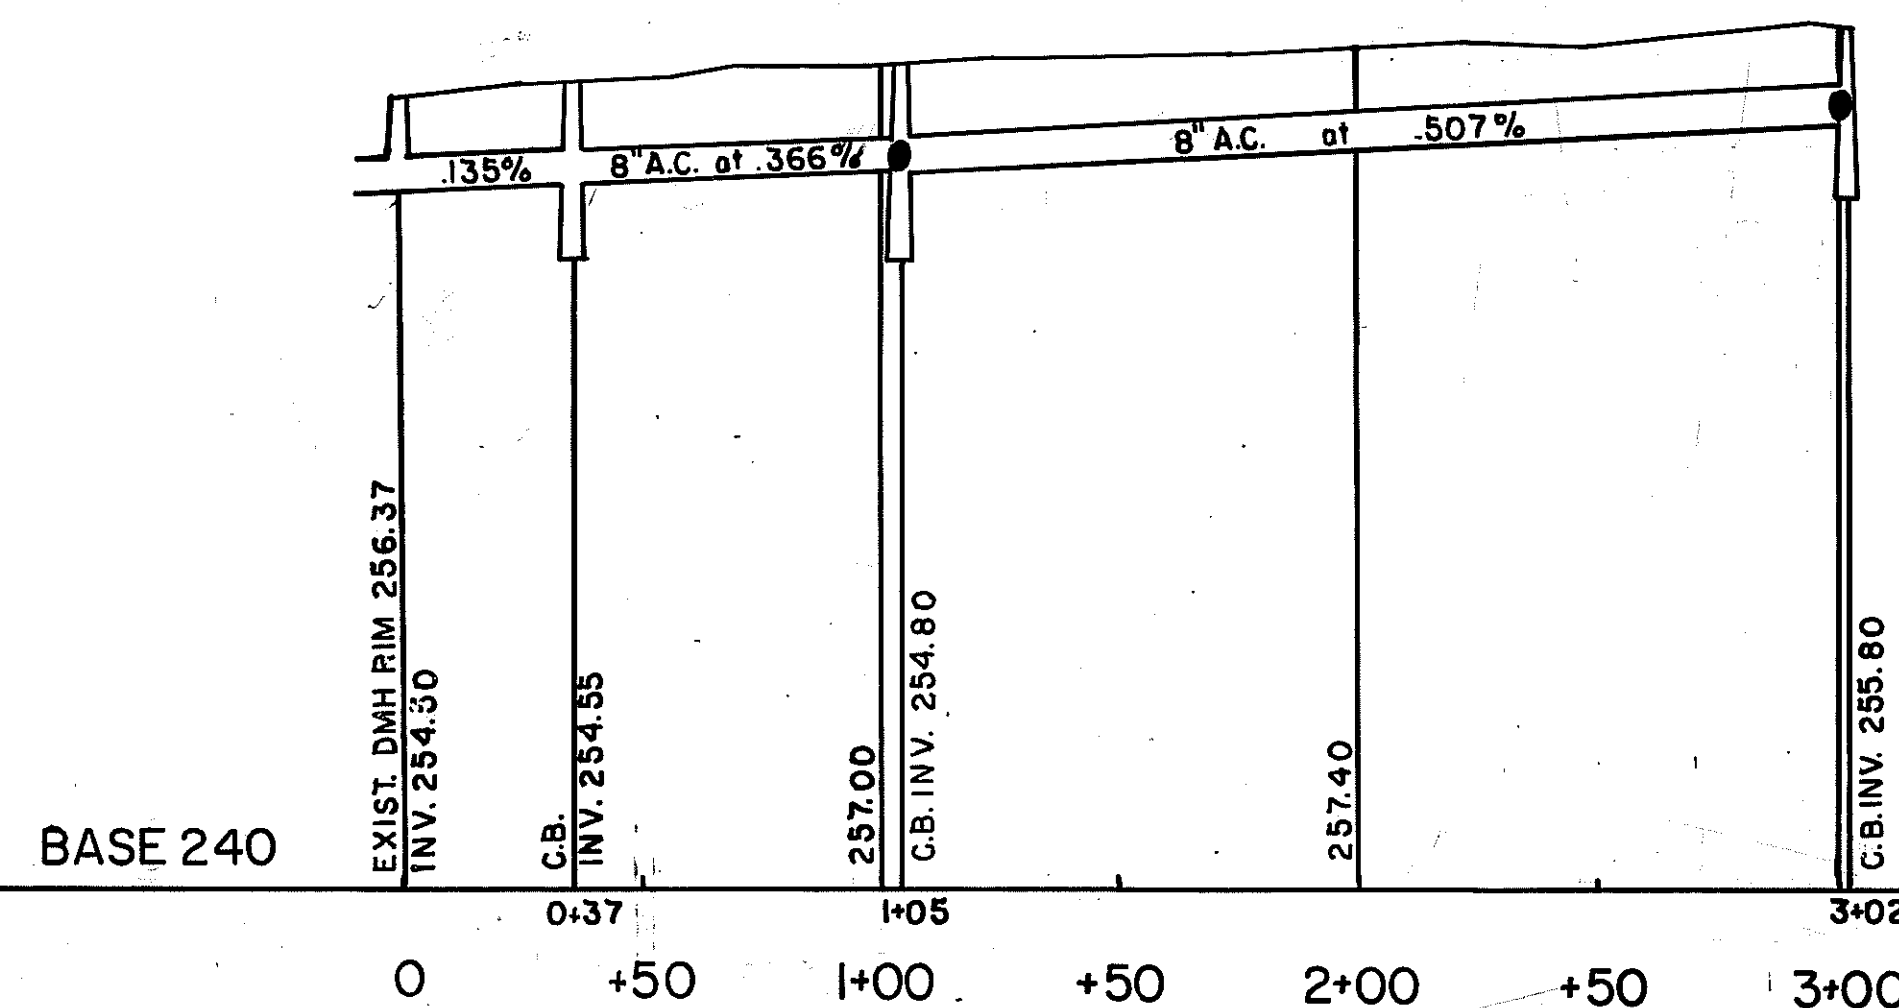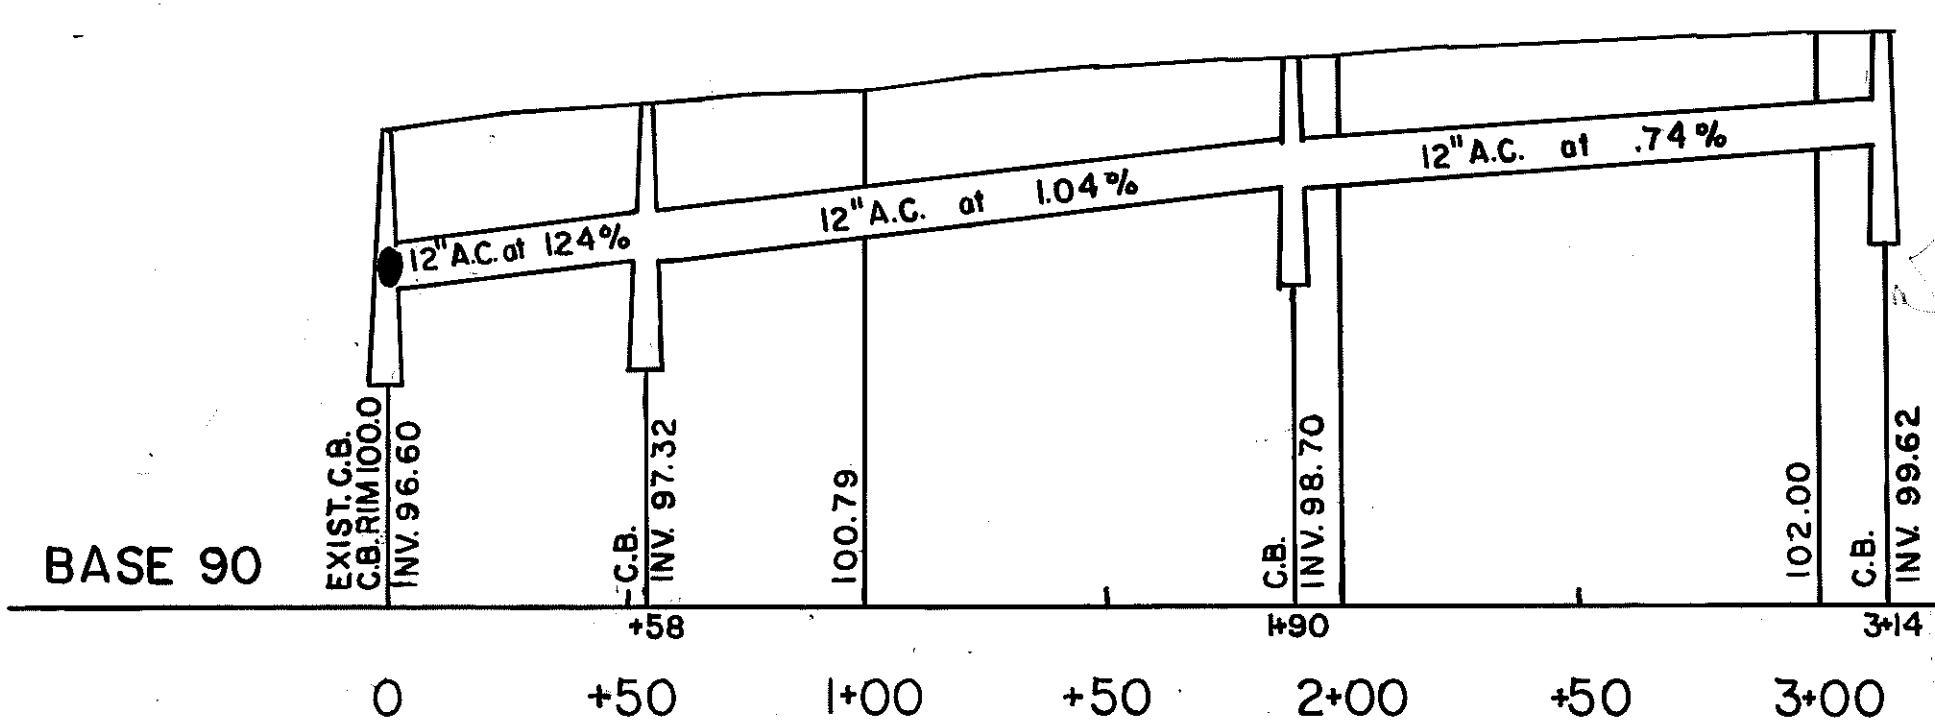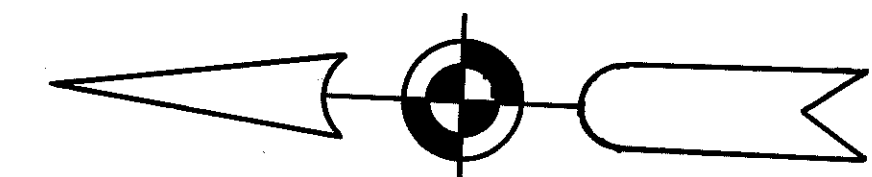

NEEDHAM SEWER RECORD DRAWINGS

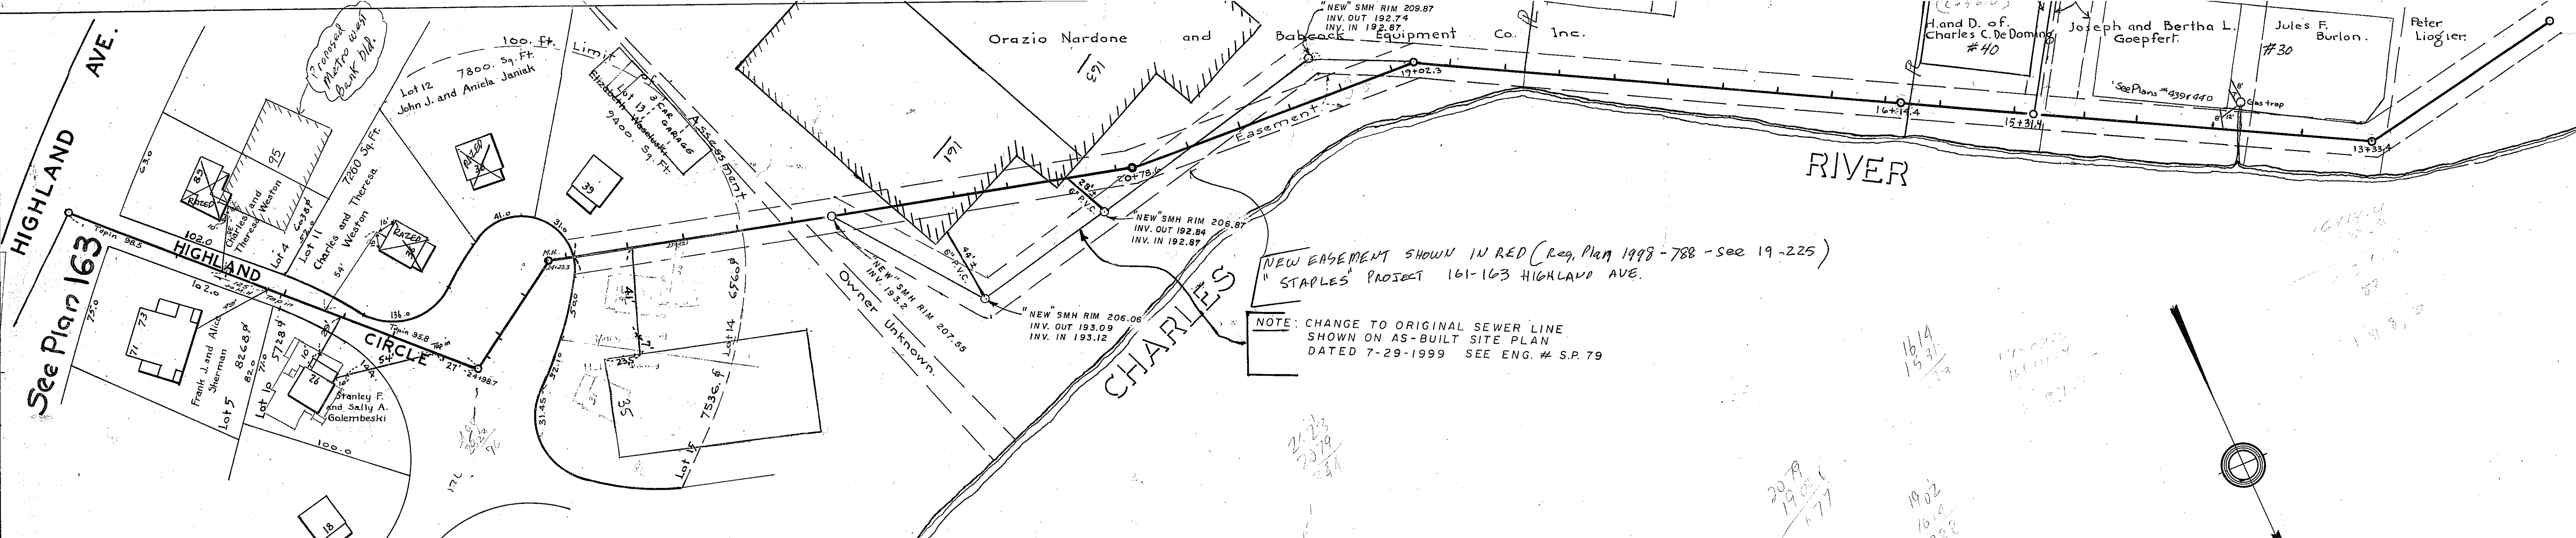


TOWN OF NEEDHAM, MASS.
Intercepting Sewer
STA. 13+33.4 TO HIGHLAND AVE.
Hor. Scale 1 in = 40 ft.
Vert. Scale 1 in = 4 ft.
Aug. 1949
Lester C. Hollis
Supt. Public Works.

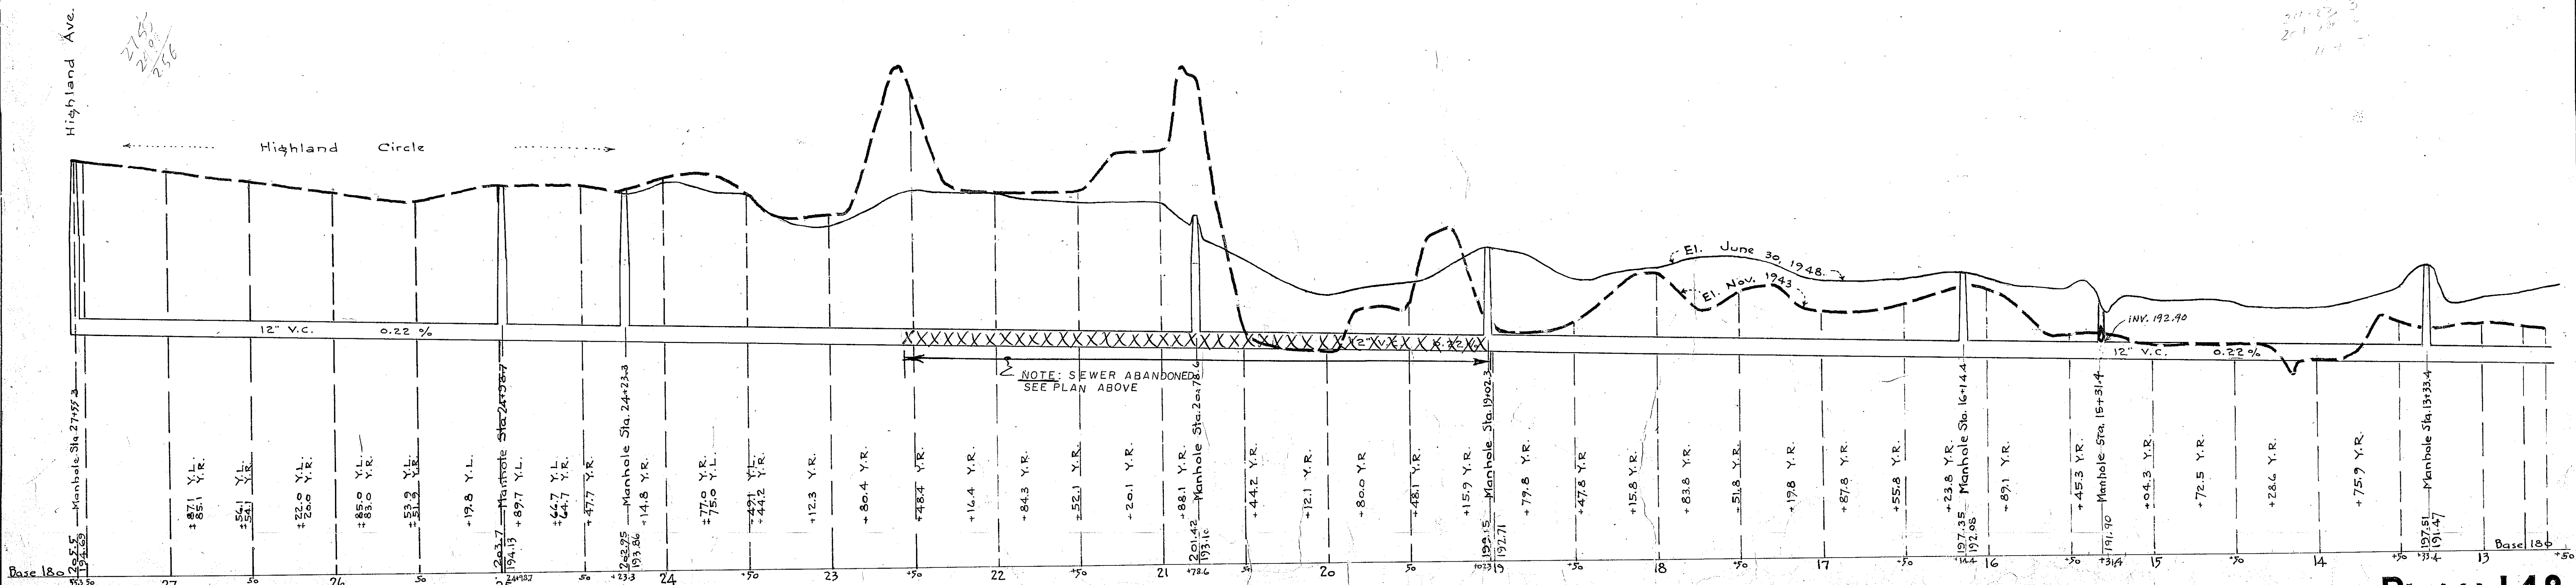

See Plan 148

See Plan 150


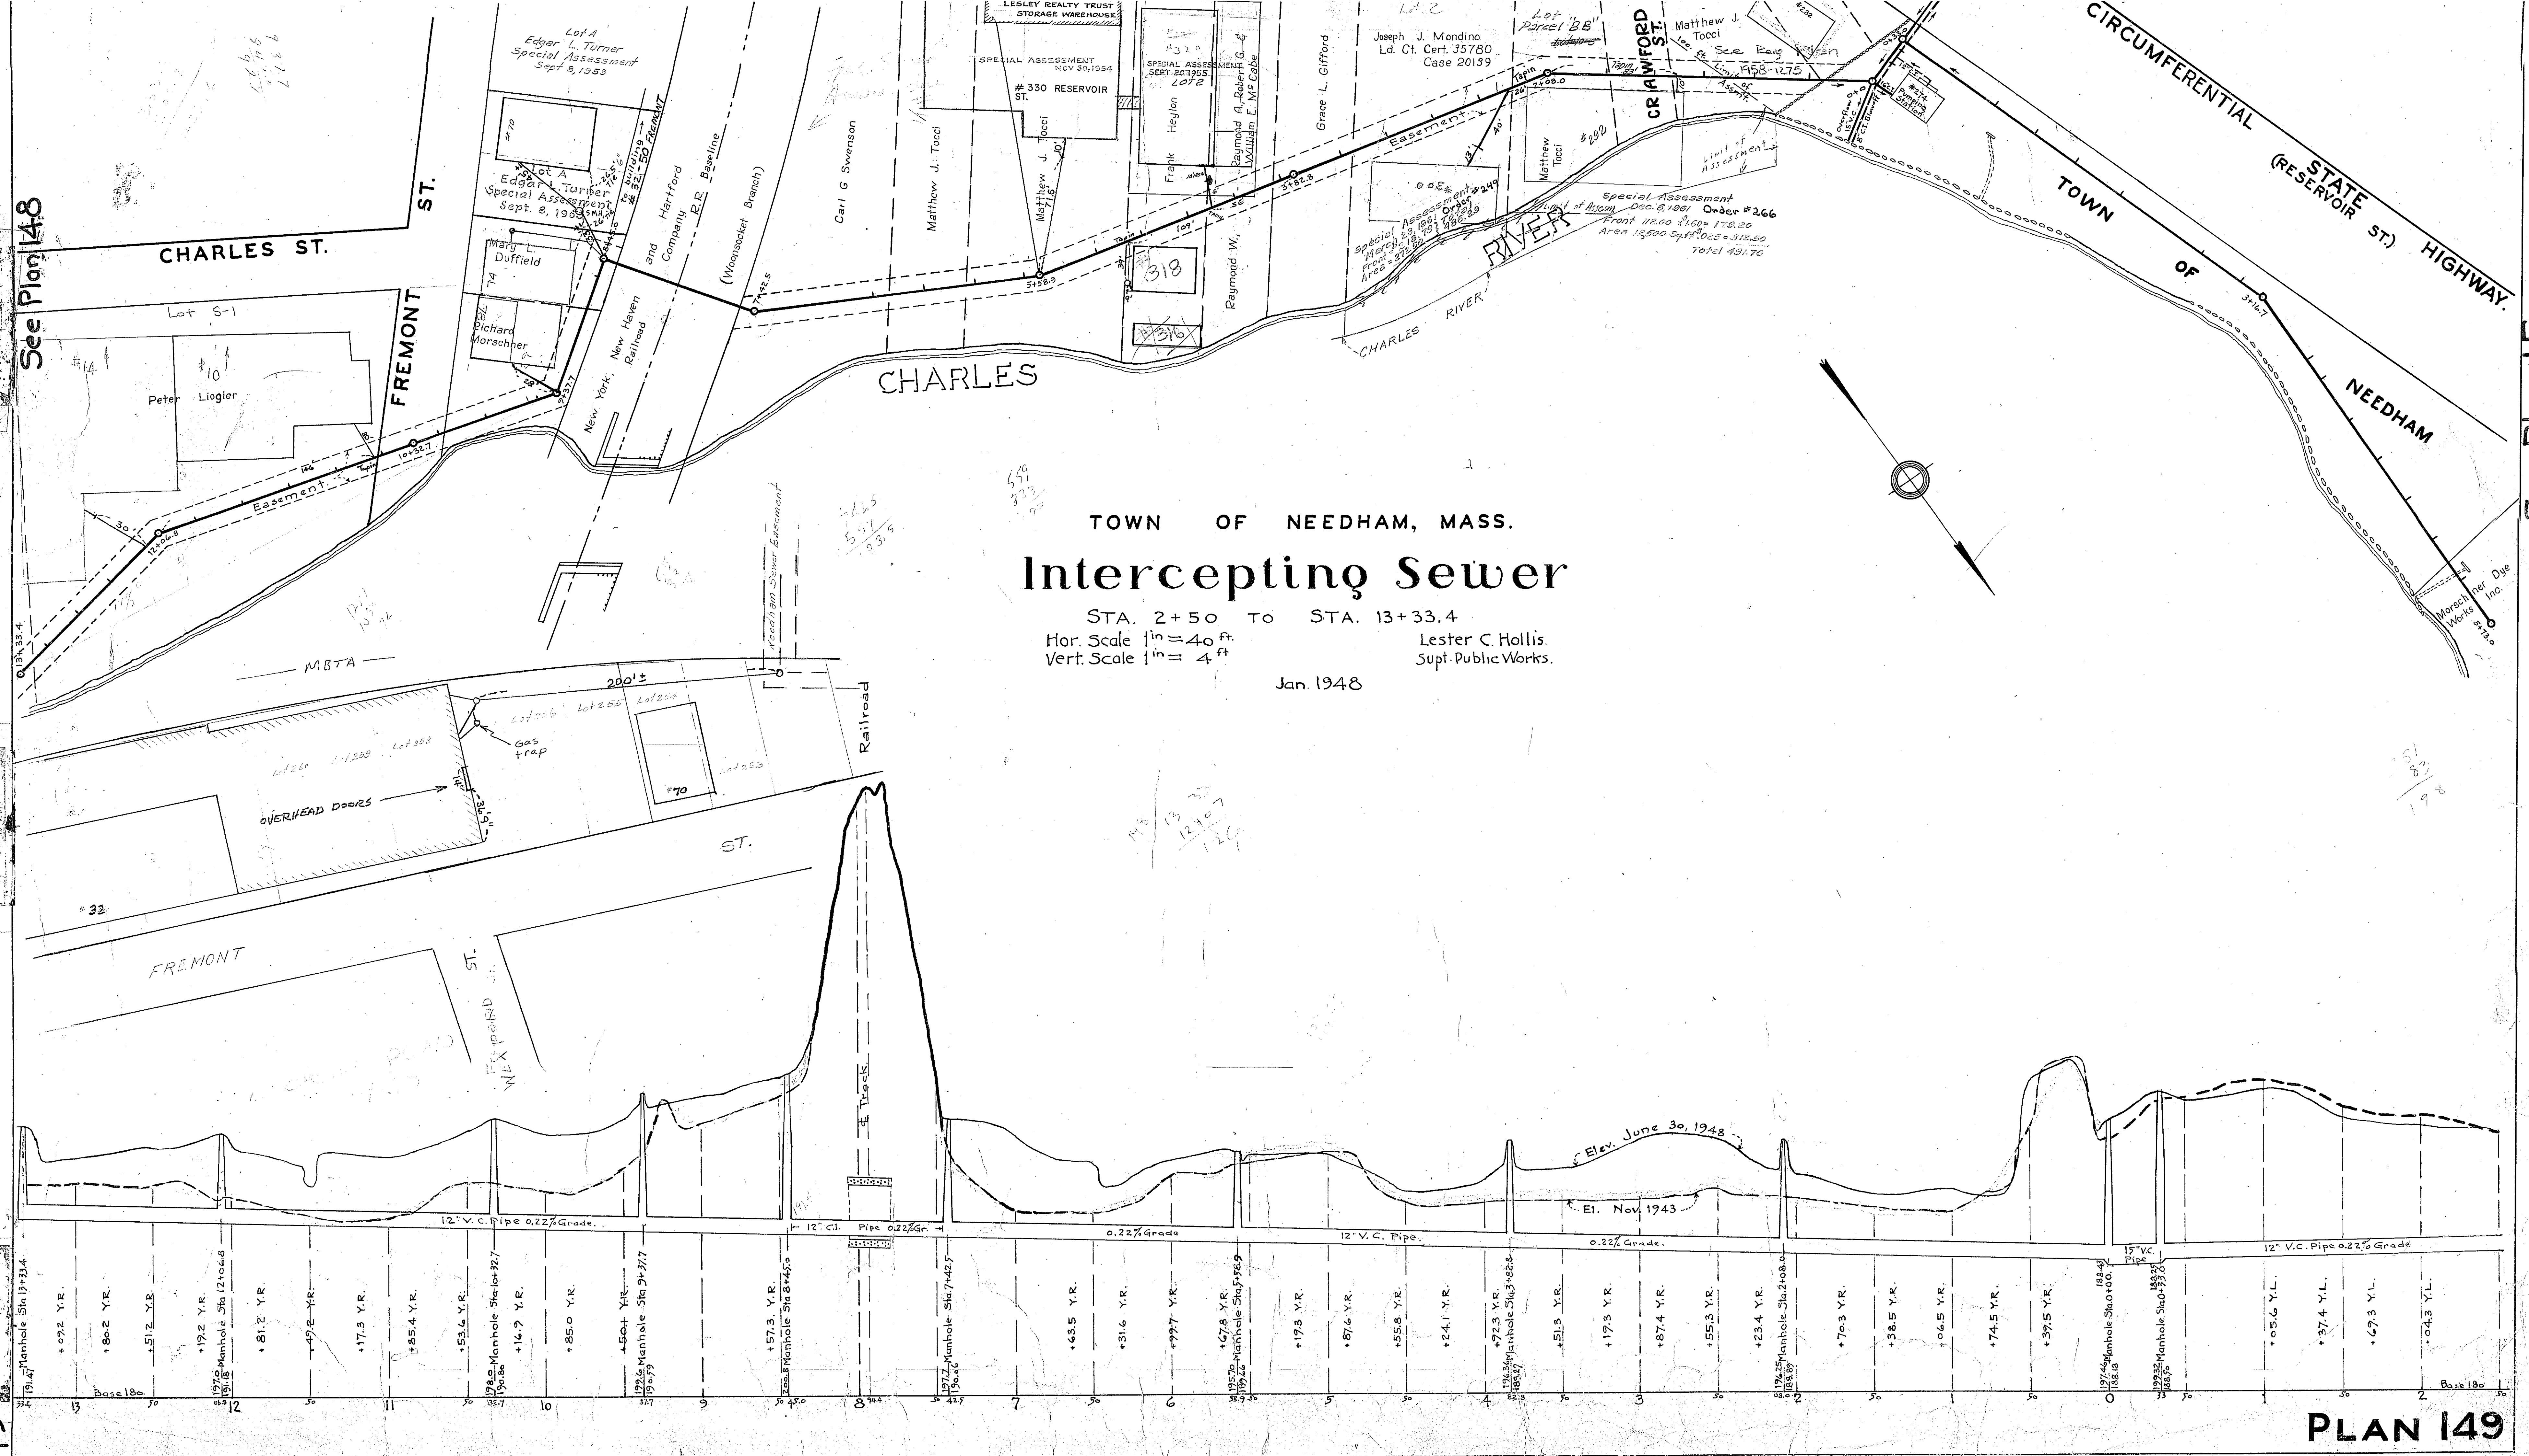


TOWN OF NEEDHAM, MASS.
Intercepting Sewer

STA. 2+50 TO STA. 13+33.4
Hor. Scale 1" = 40 ft.
Vert. Scale 1" = 4 ft.
Lester C. Hollis.
Supt. Public Works.
Jan. 1948

PLAN 149

149


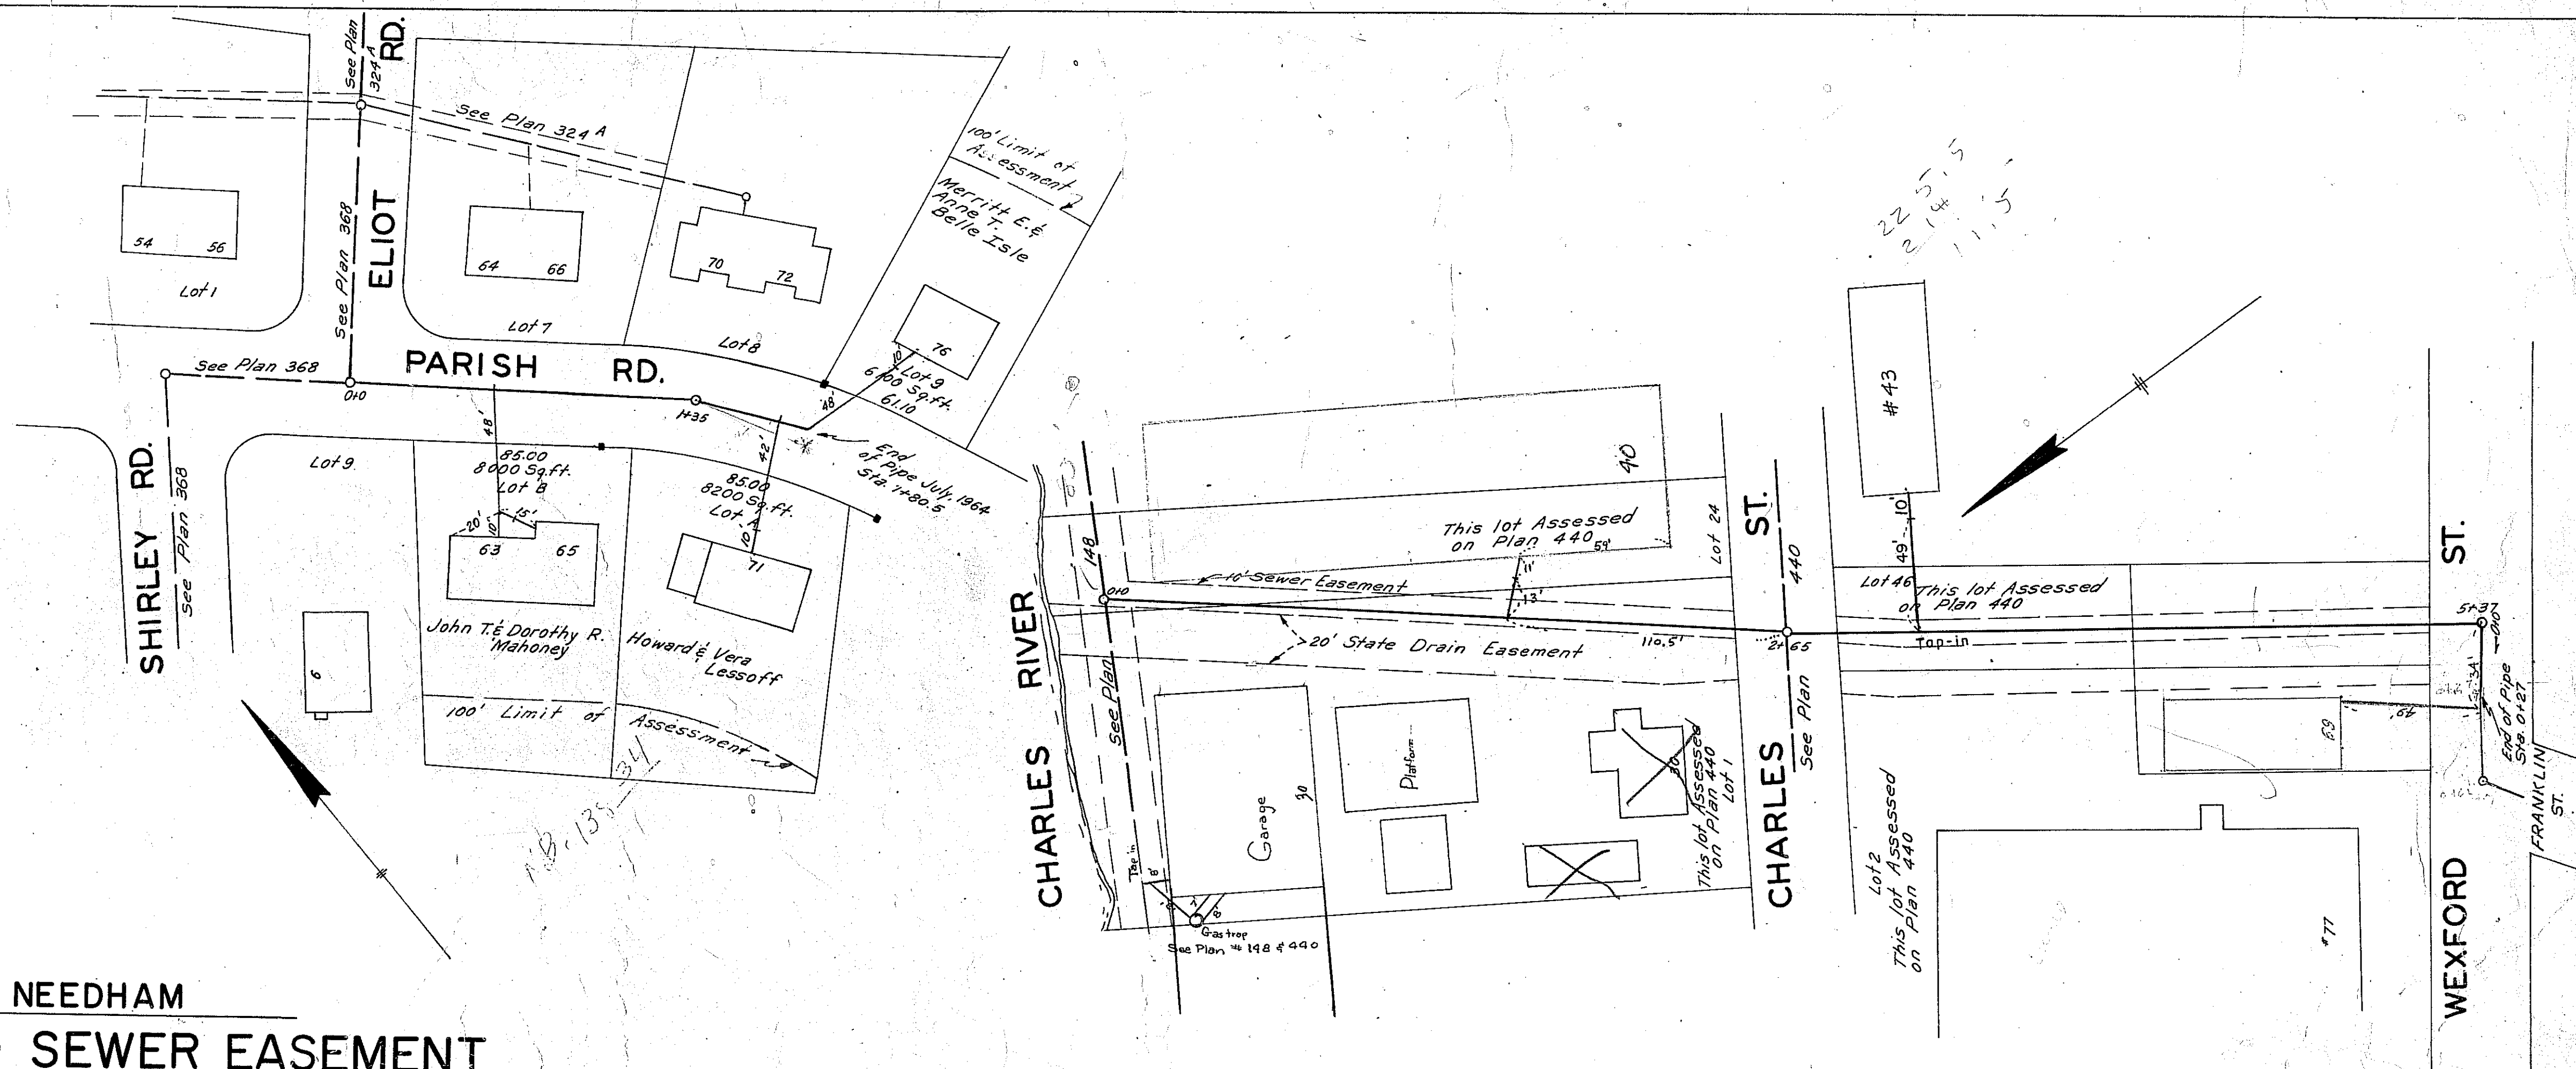
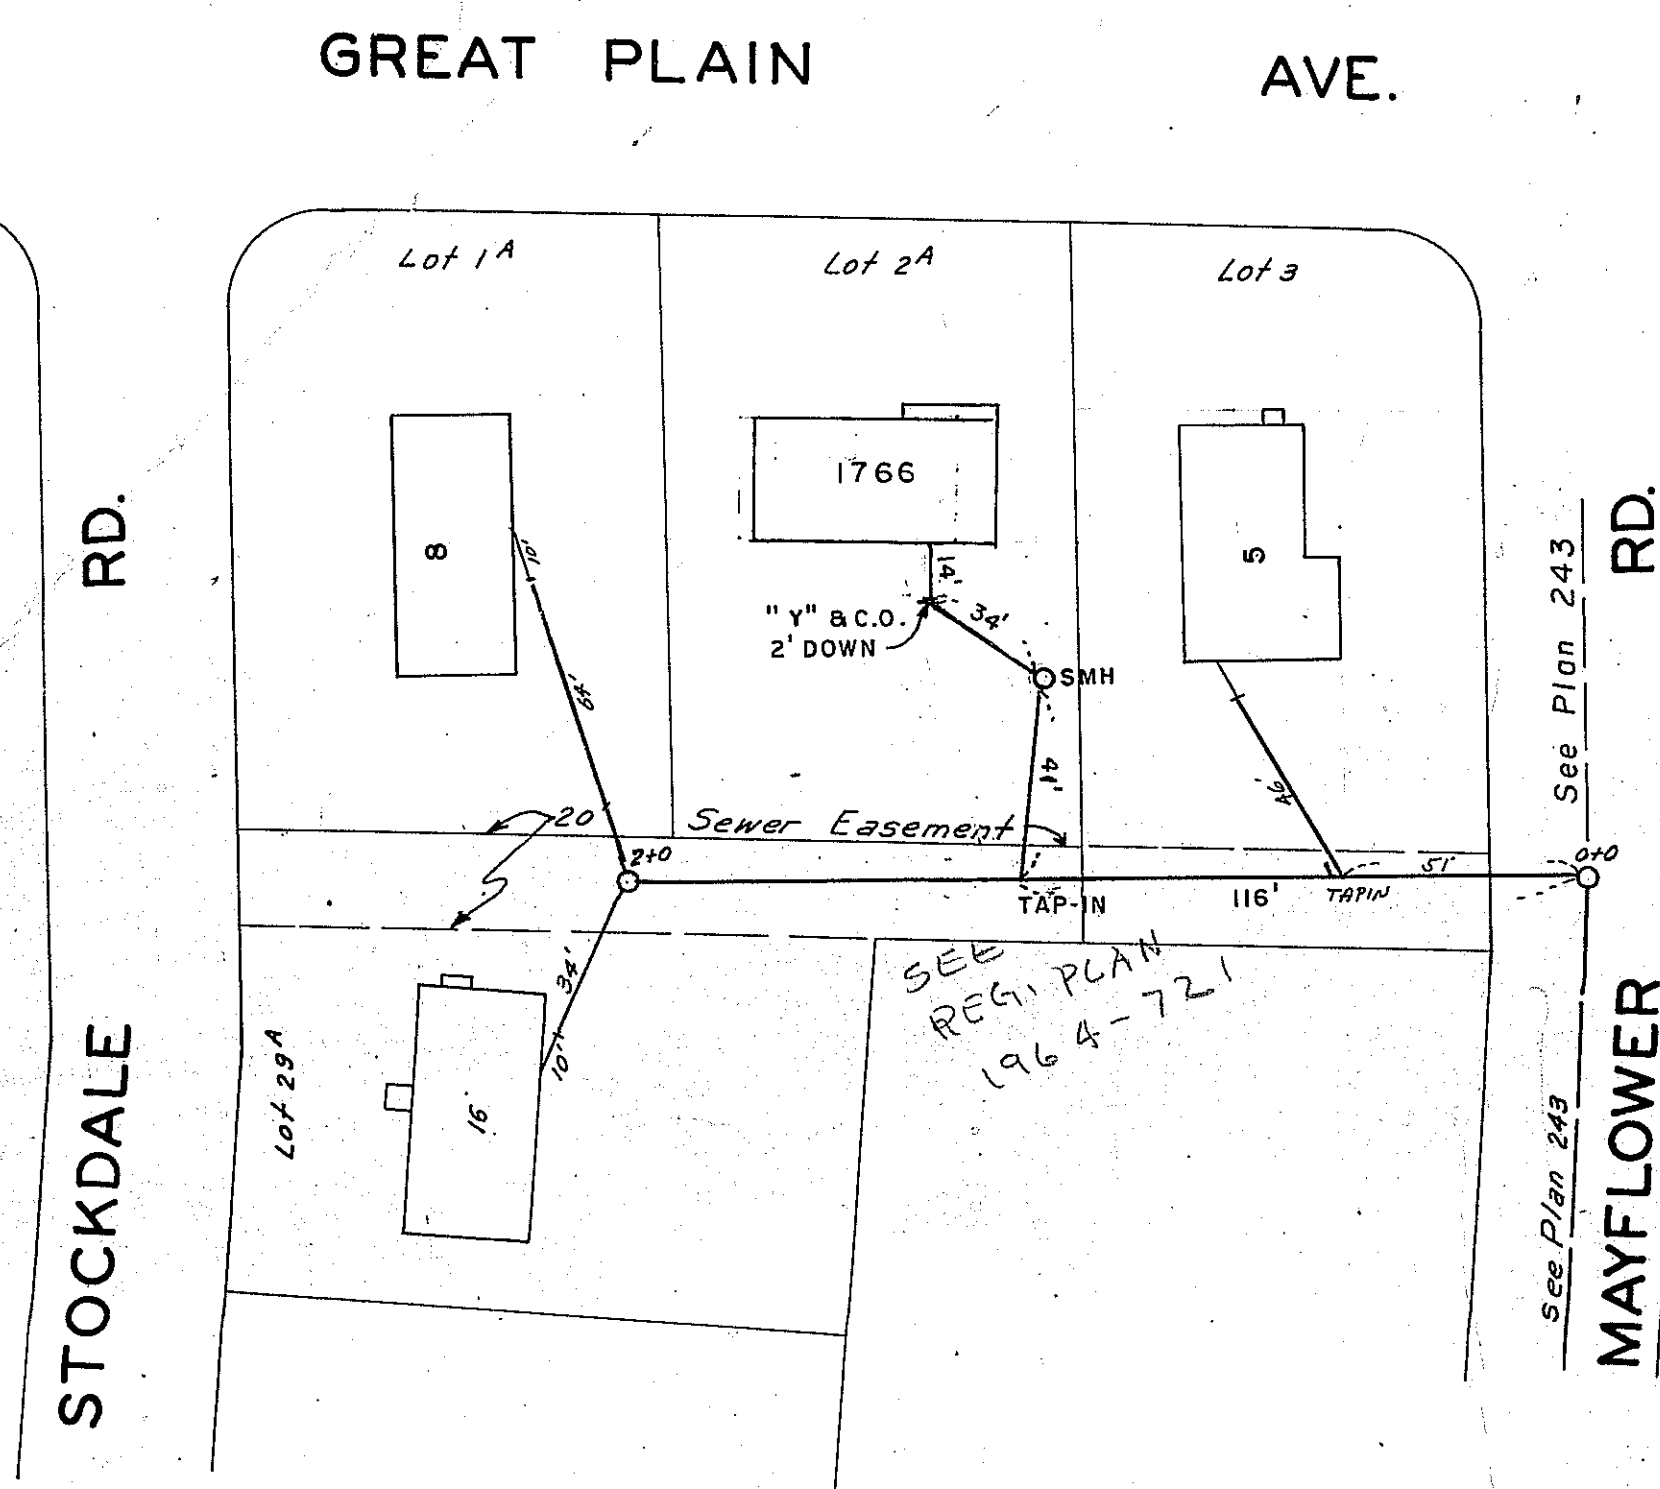



HOR. SCALE: 1 IN. = 40 FT.

VERT. SCALE: 1 IN. = 4 FT.



JULY, 1964

138 Pg.34

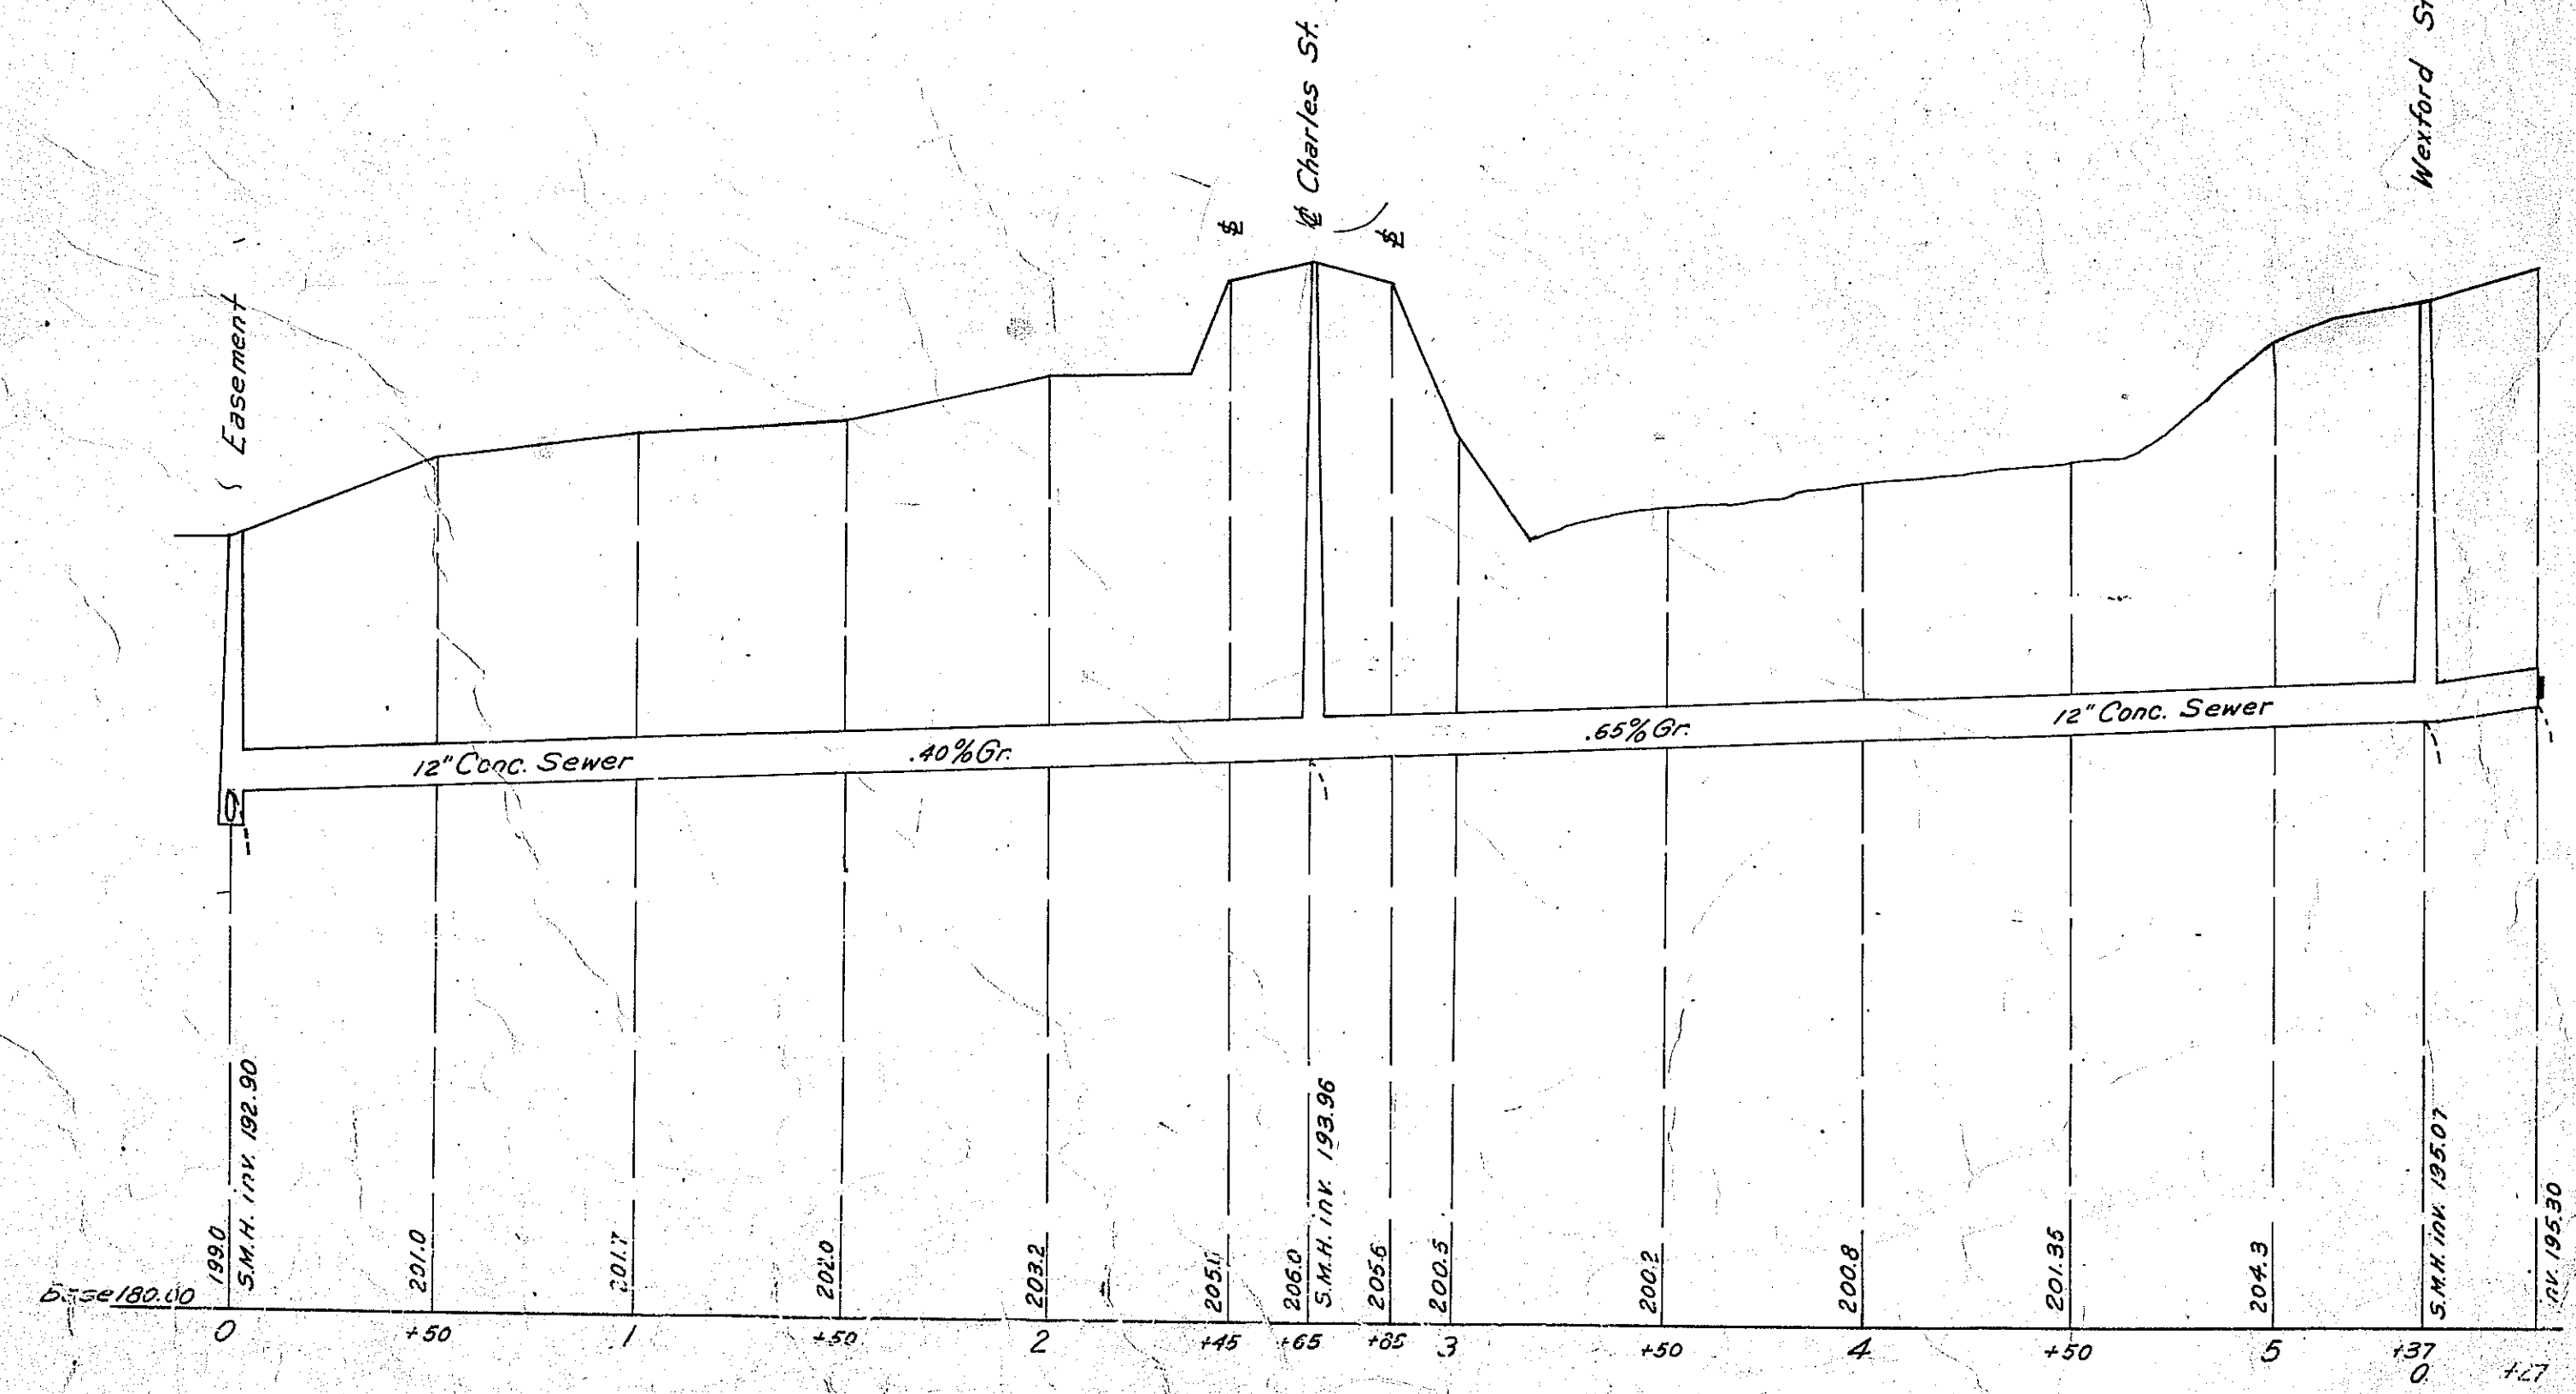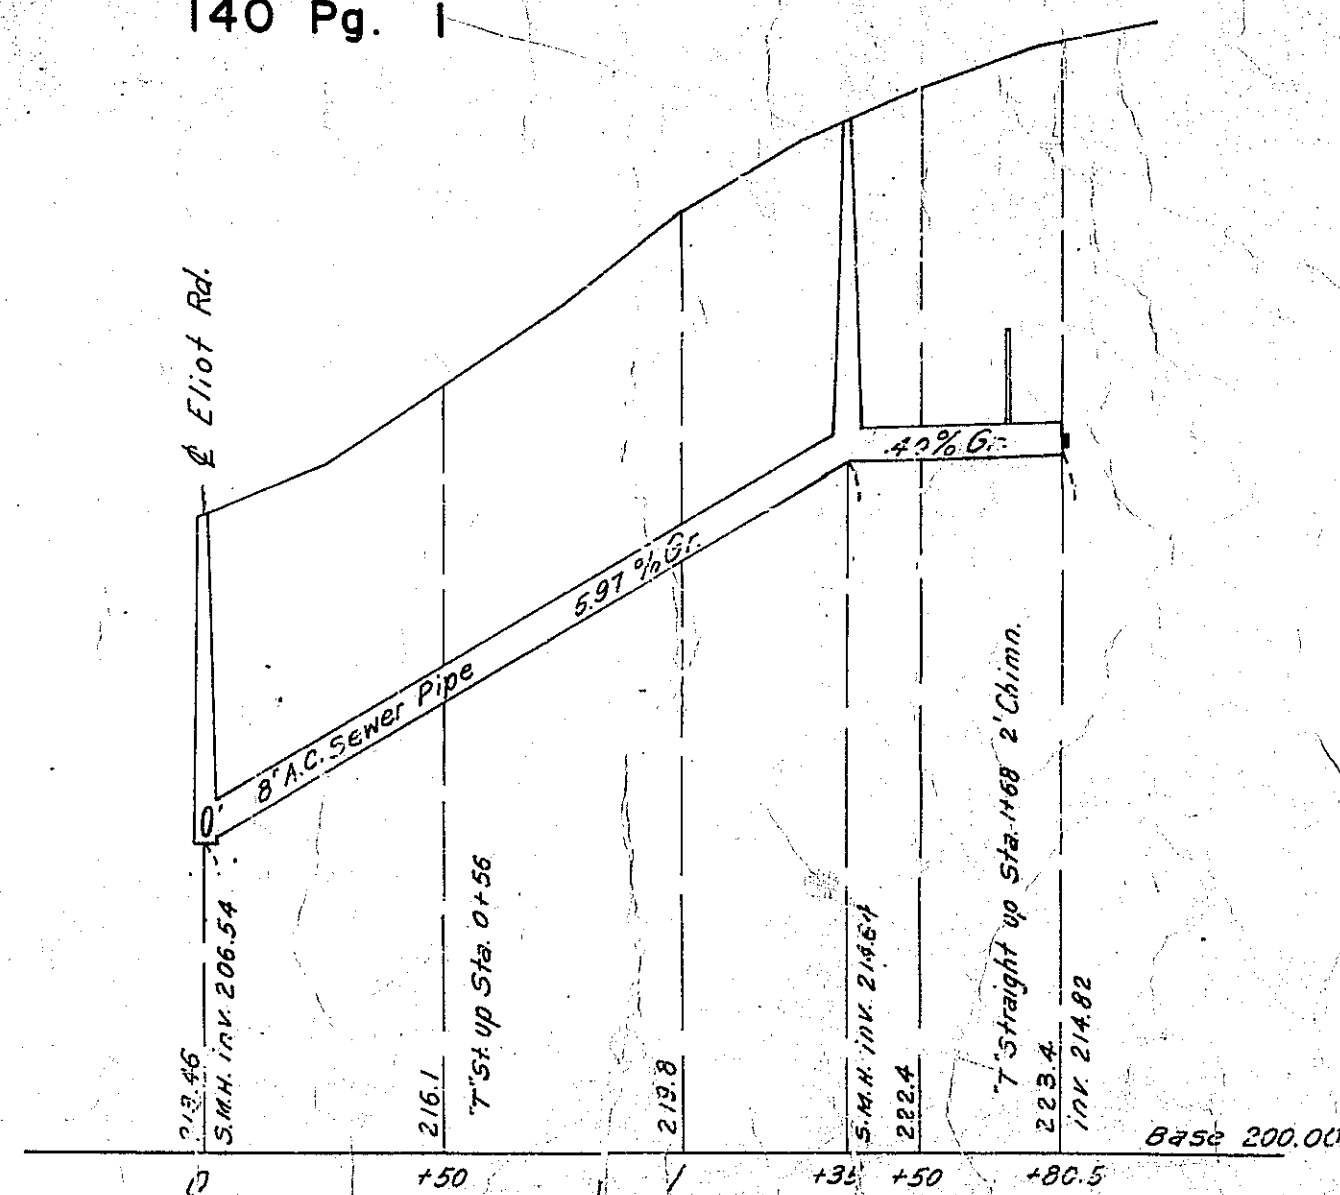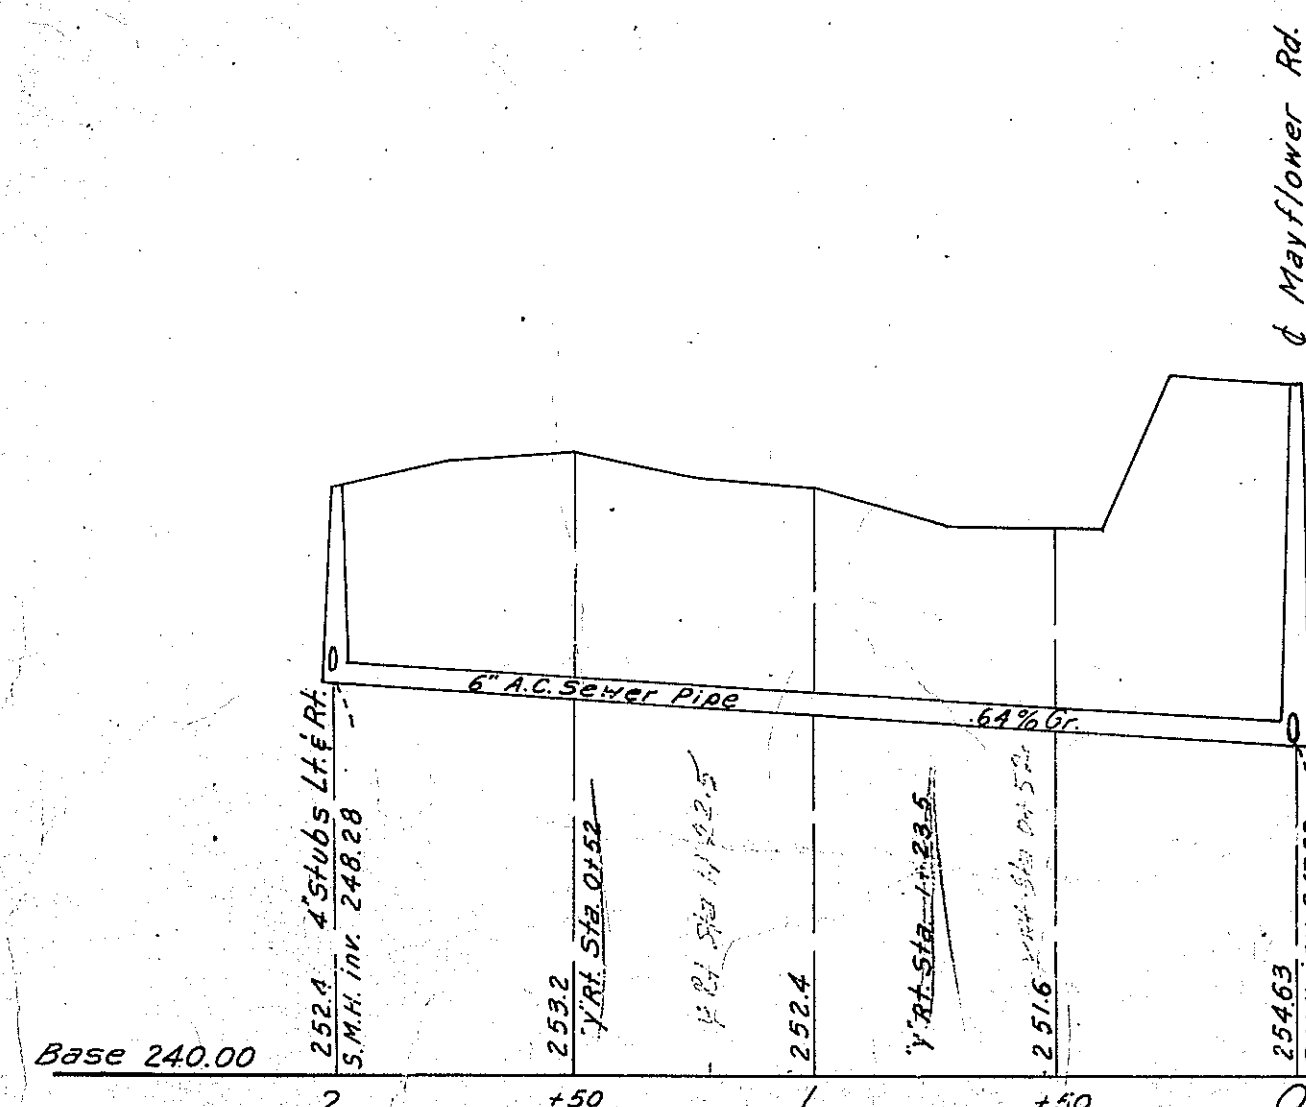



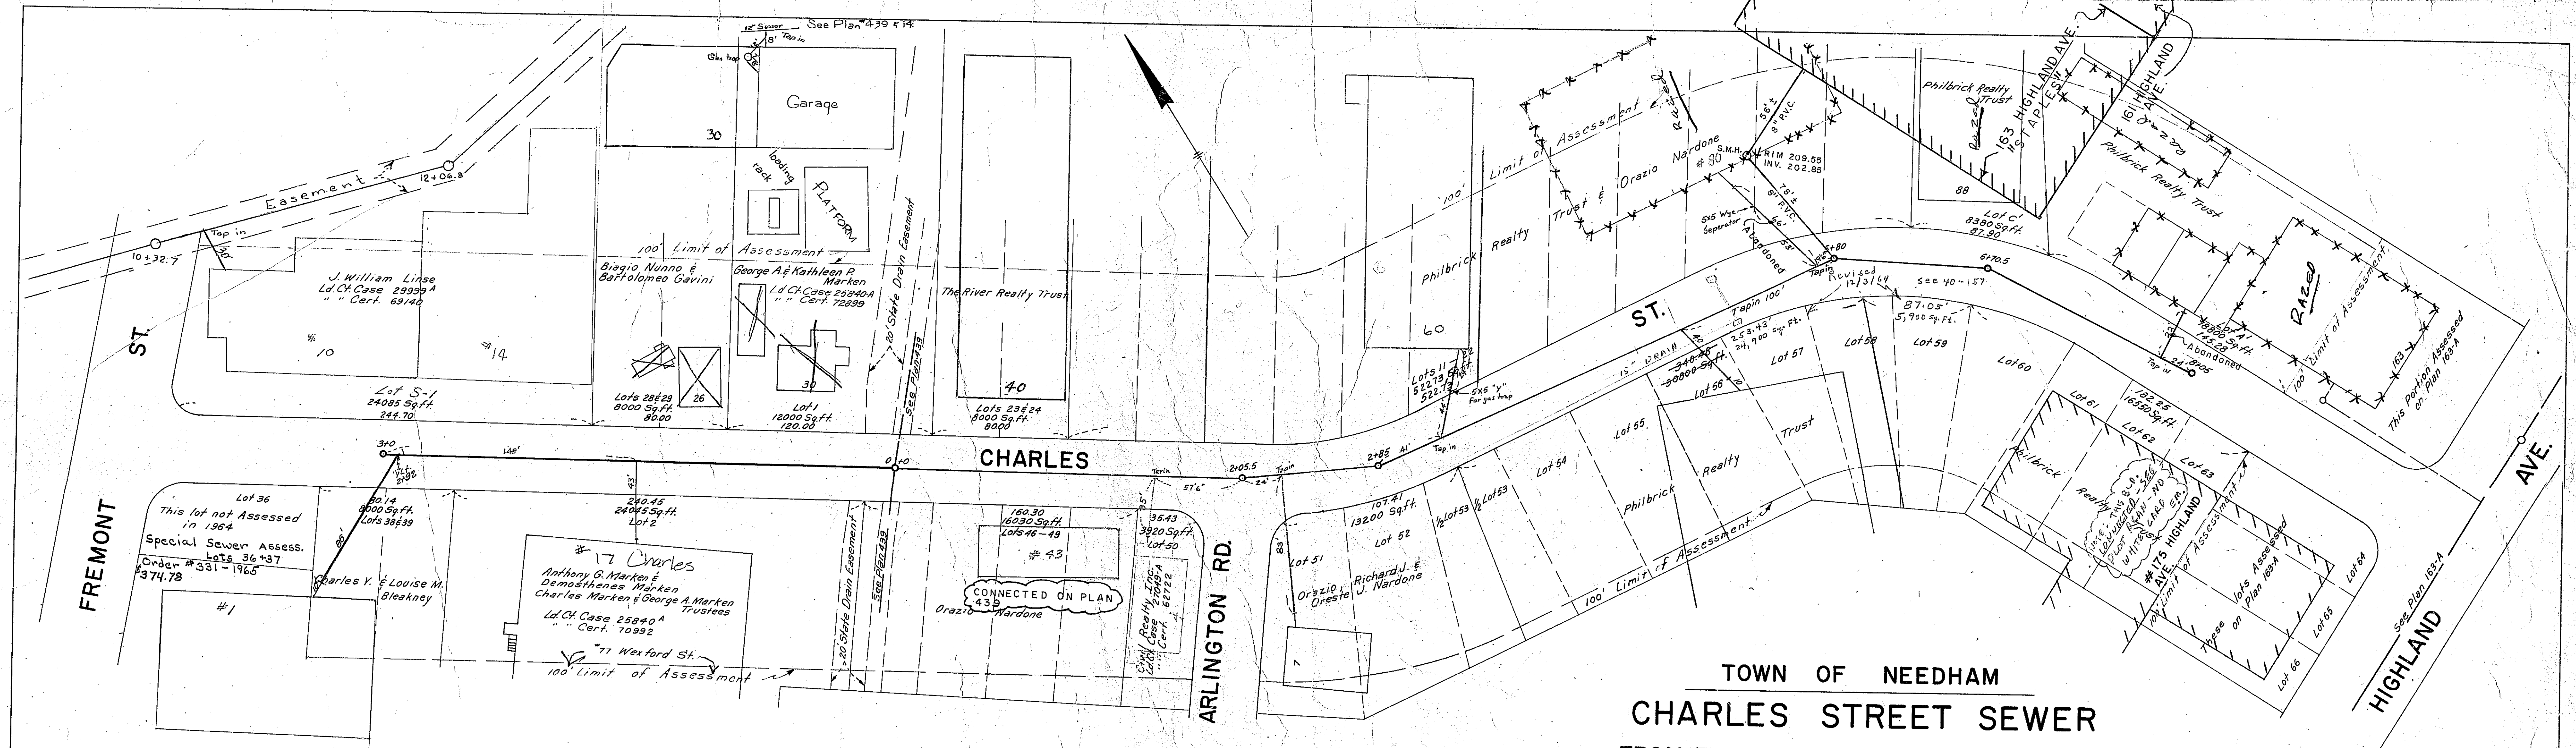


TOWN OF NEEDHAM
CHARLES STREET SEWER
FROM FREMONT ST. TO HIGHLAND AVE.
HOR. SCALE: 1IN. = 40FT. H.GORDON MARTIN
VERT. SCALE: 1IN. = 4FT. TOWN ENGINEER
JULY, 1964 NB.140 Pg. 5

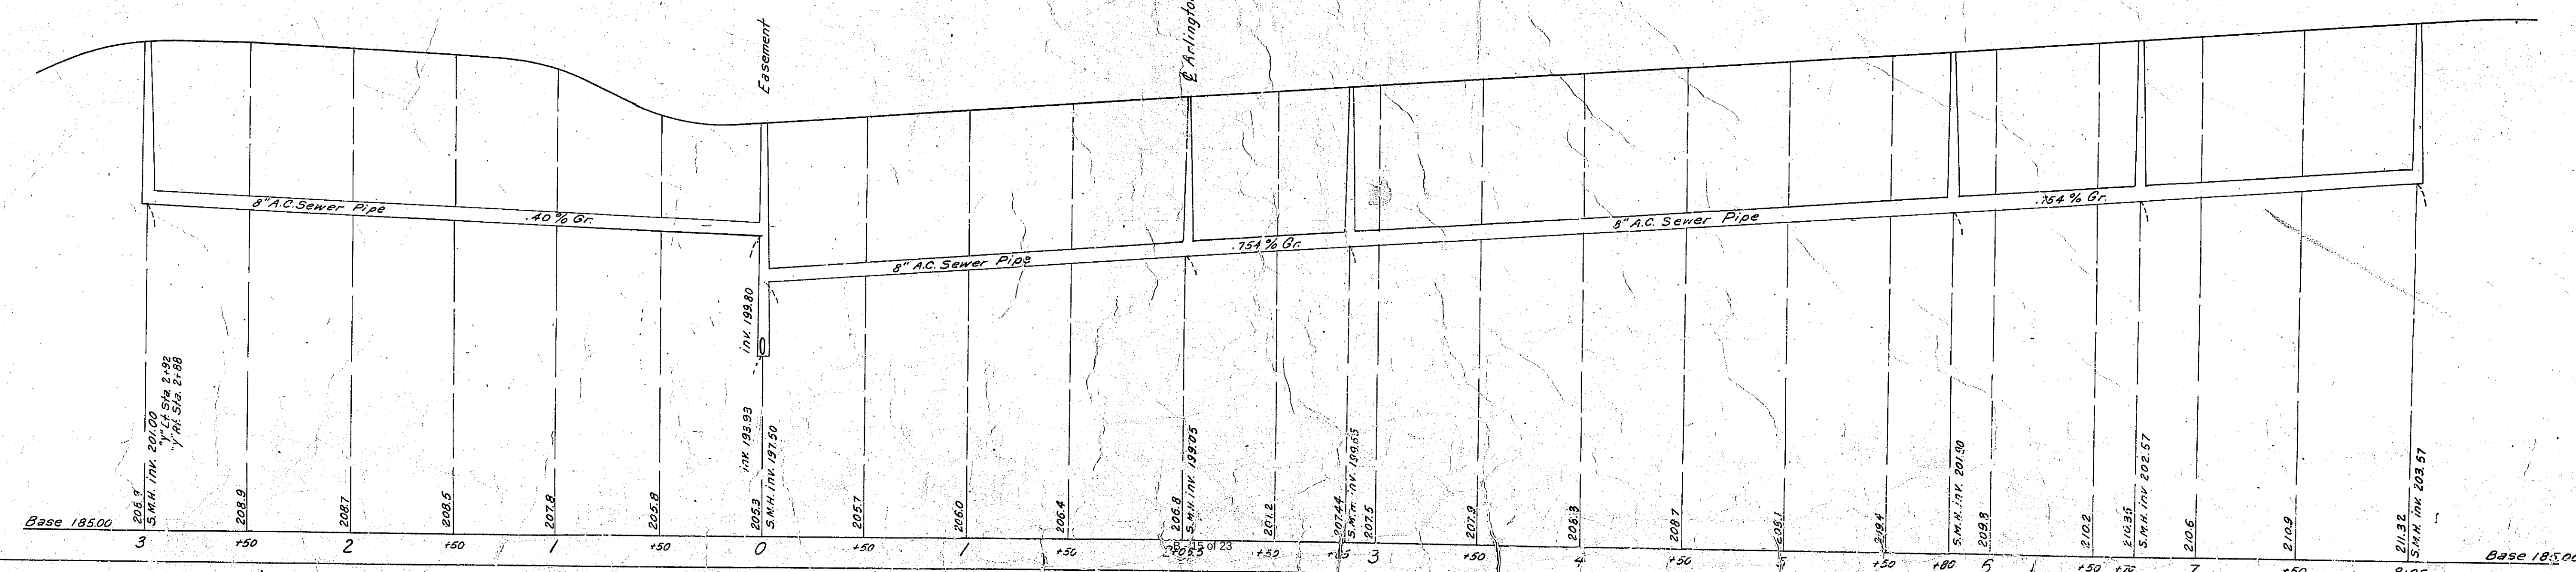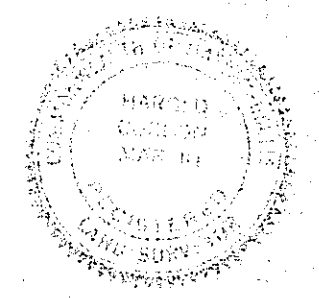





HOR. SCALE: 1IN.= 40FT. H.GORDON MARTIN
VERT. SCALE: 1IN.= 4FT. TOWN ENGINEER
SEPT. 1964 N.B.143 Pg 68

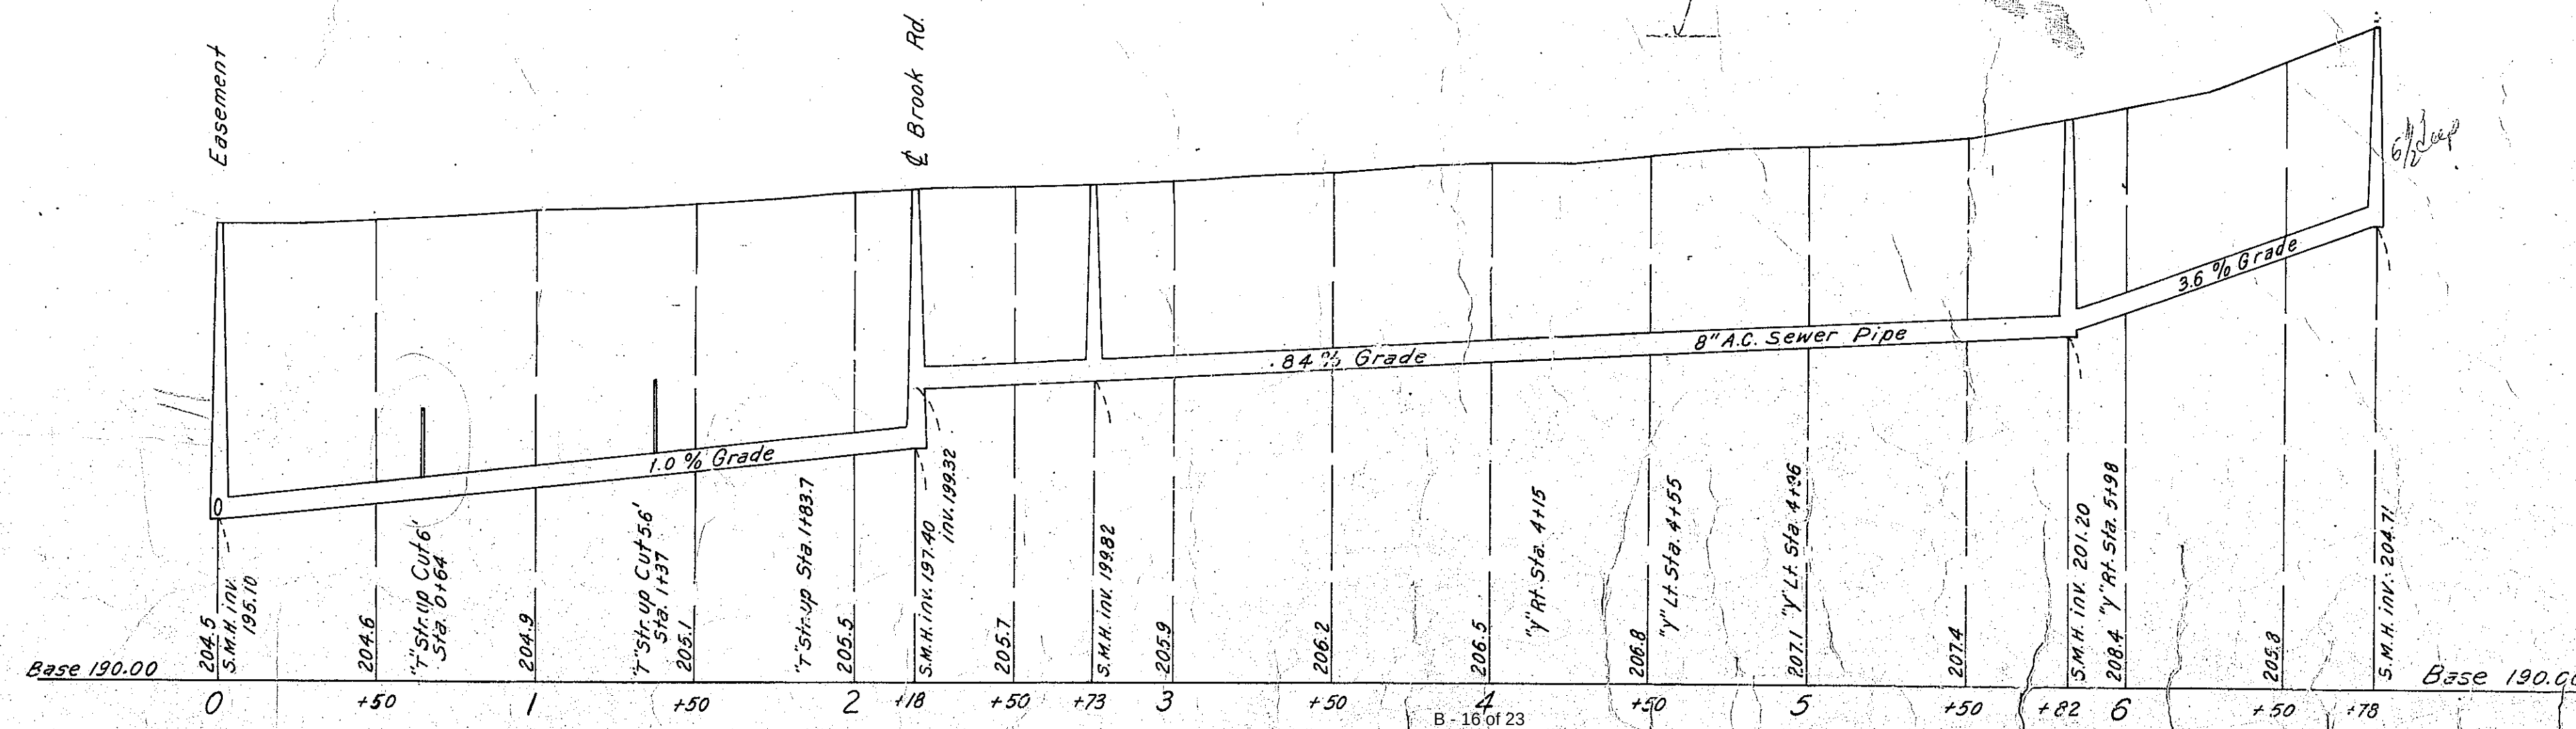

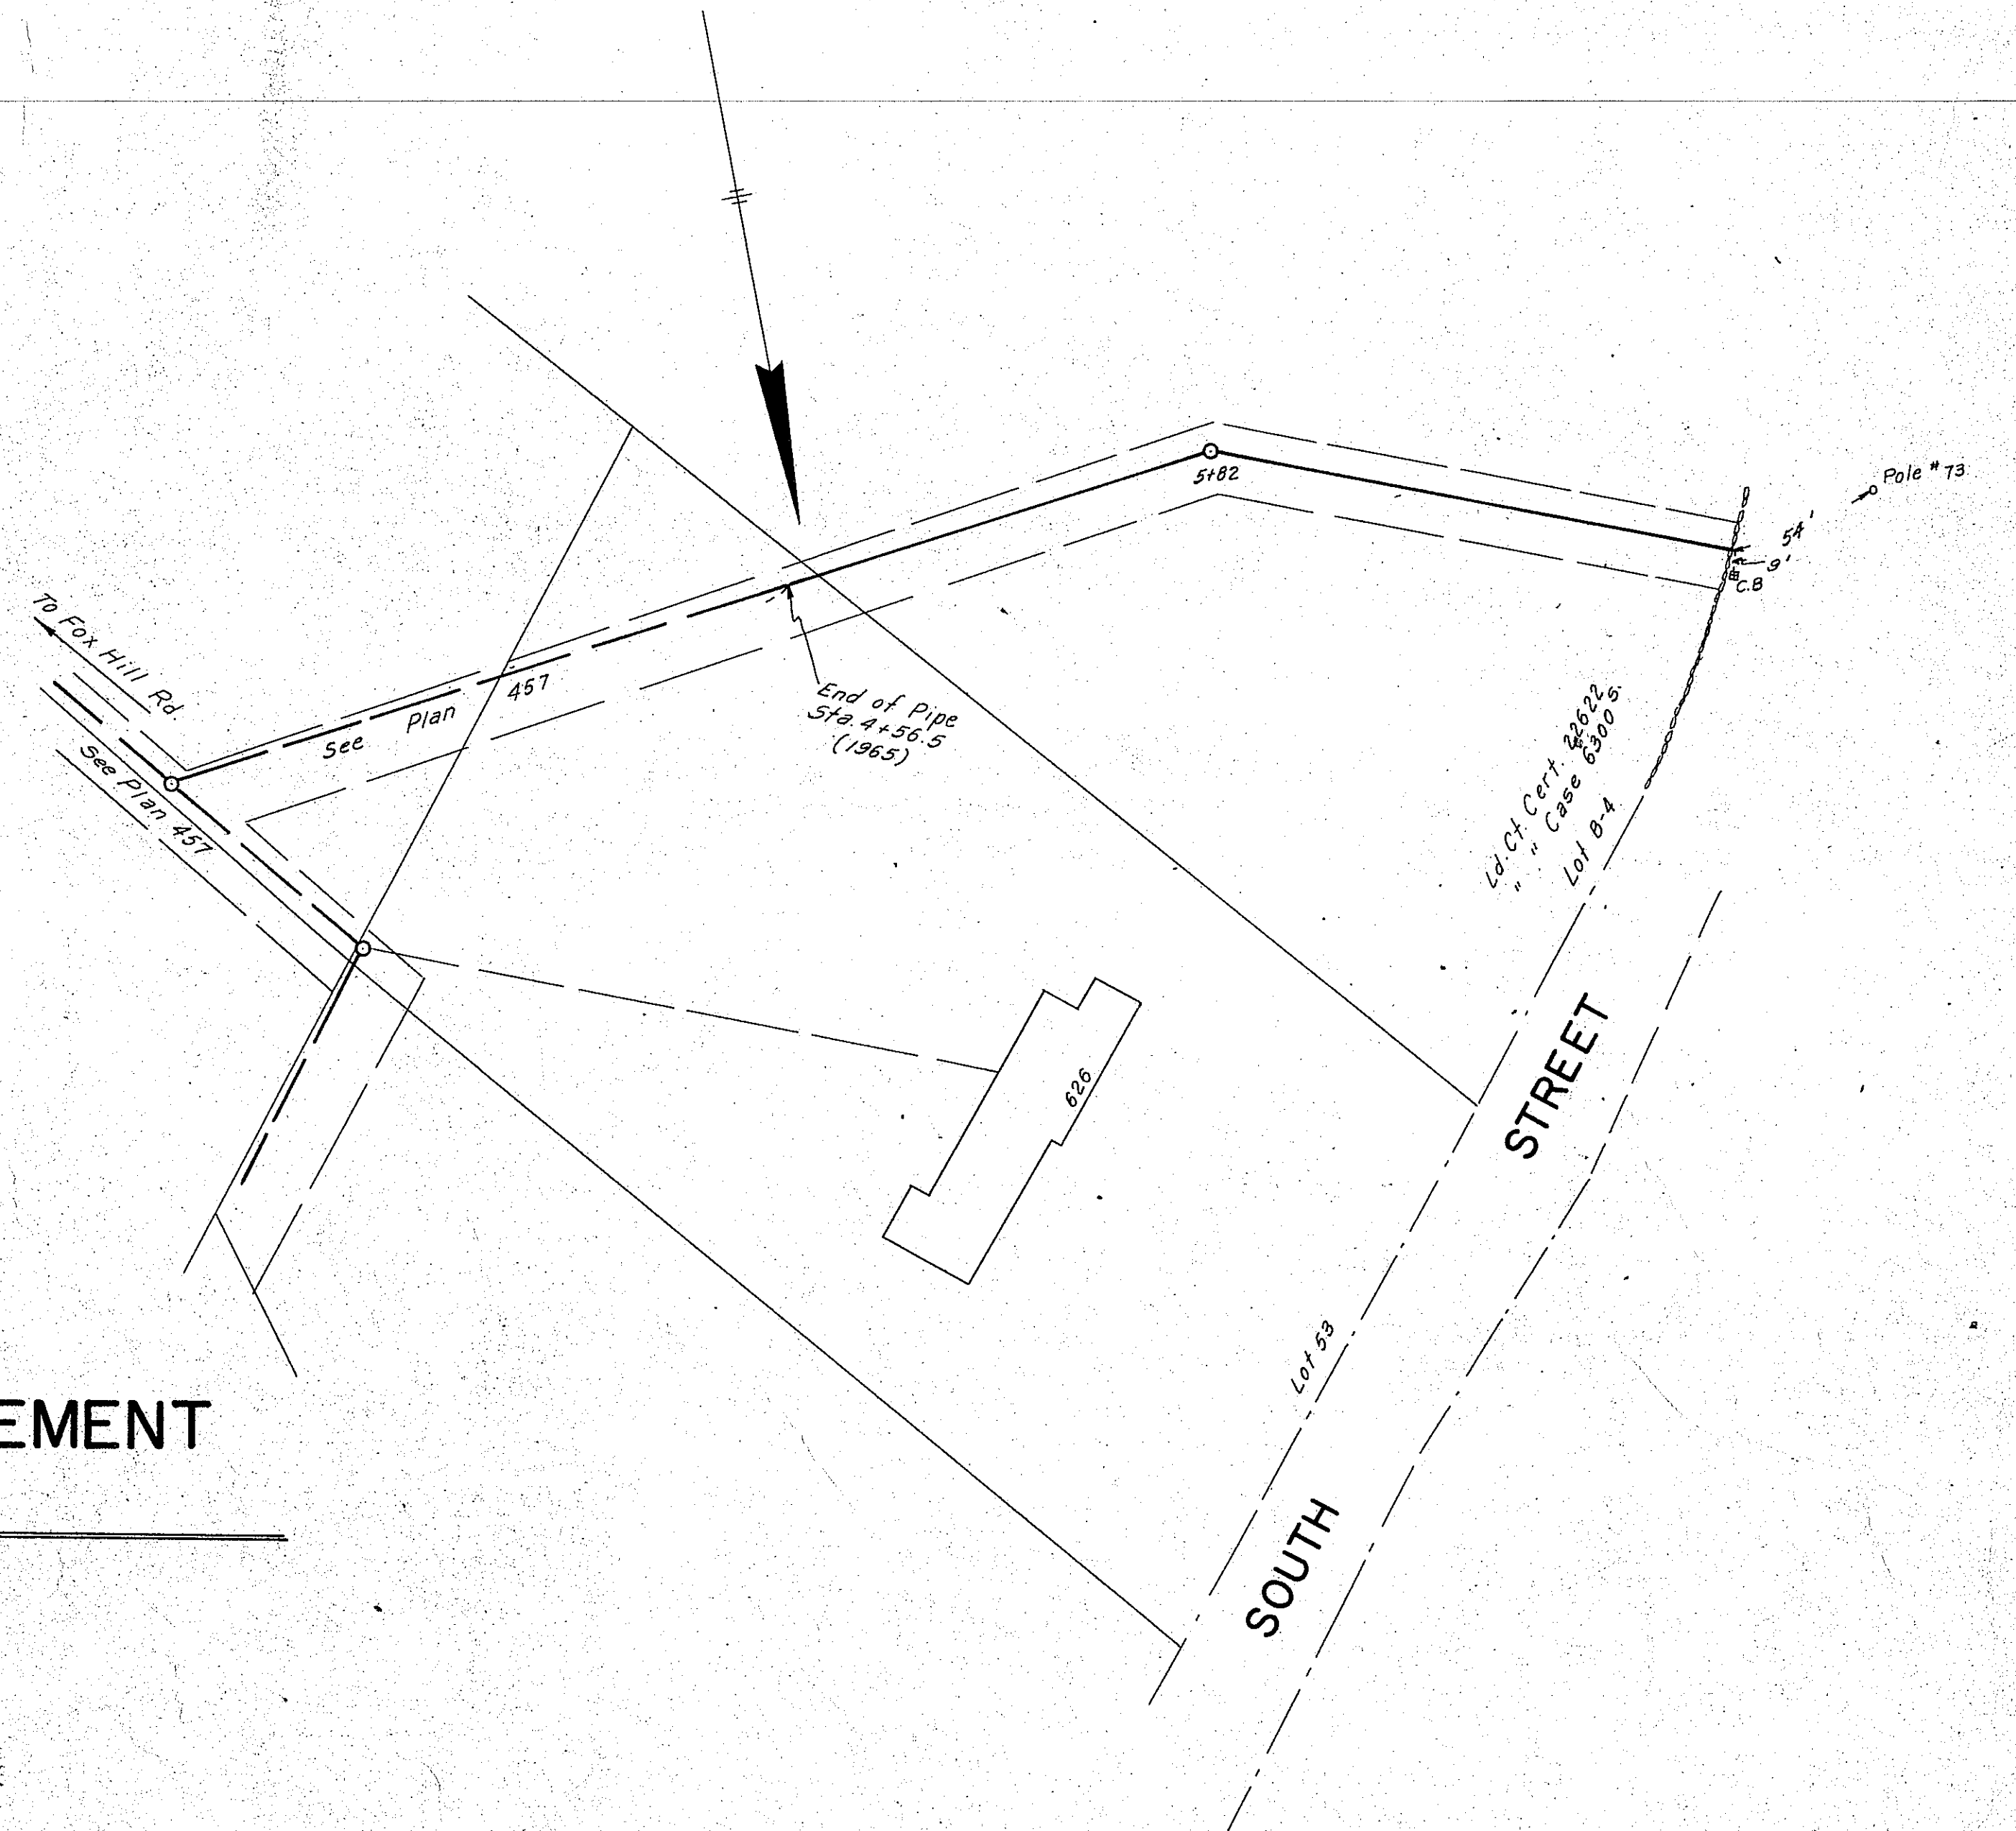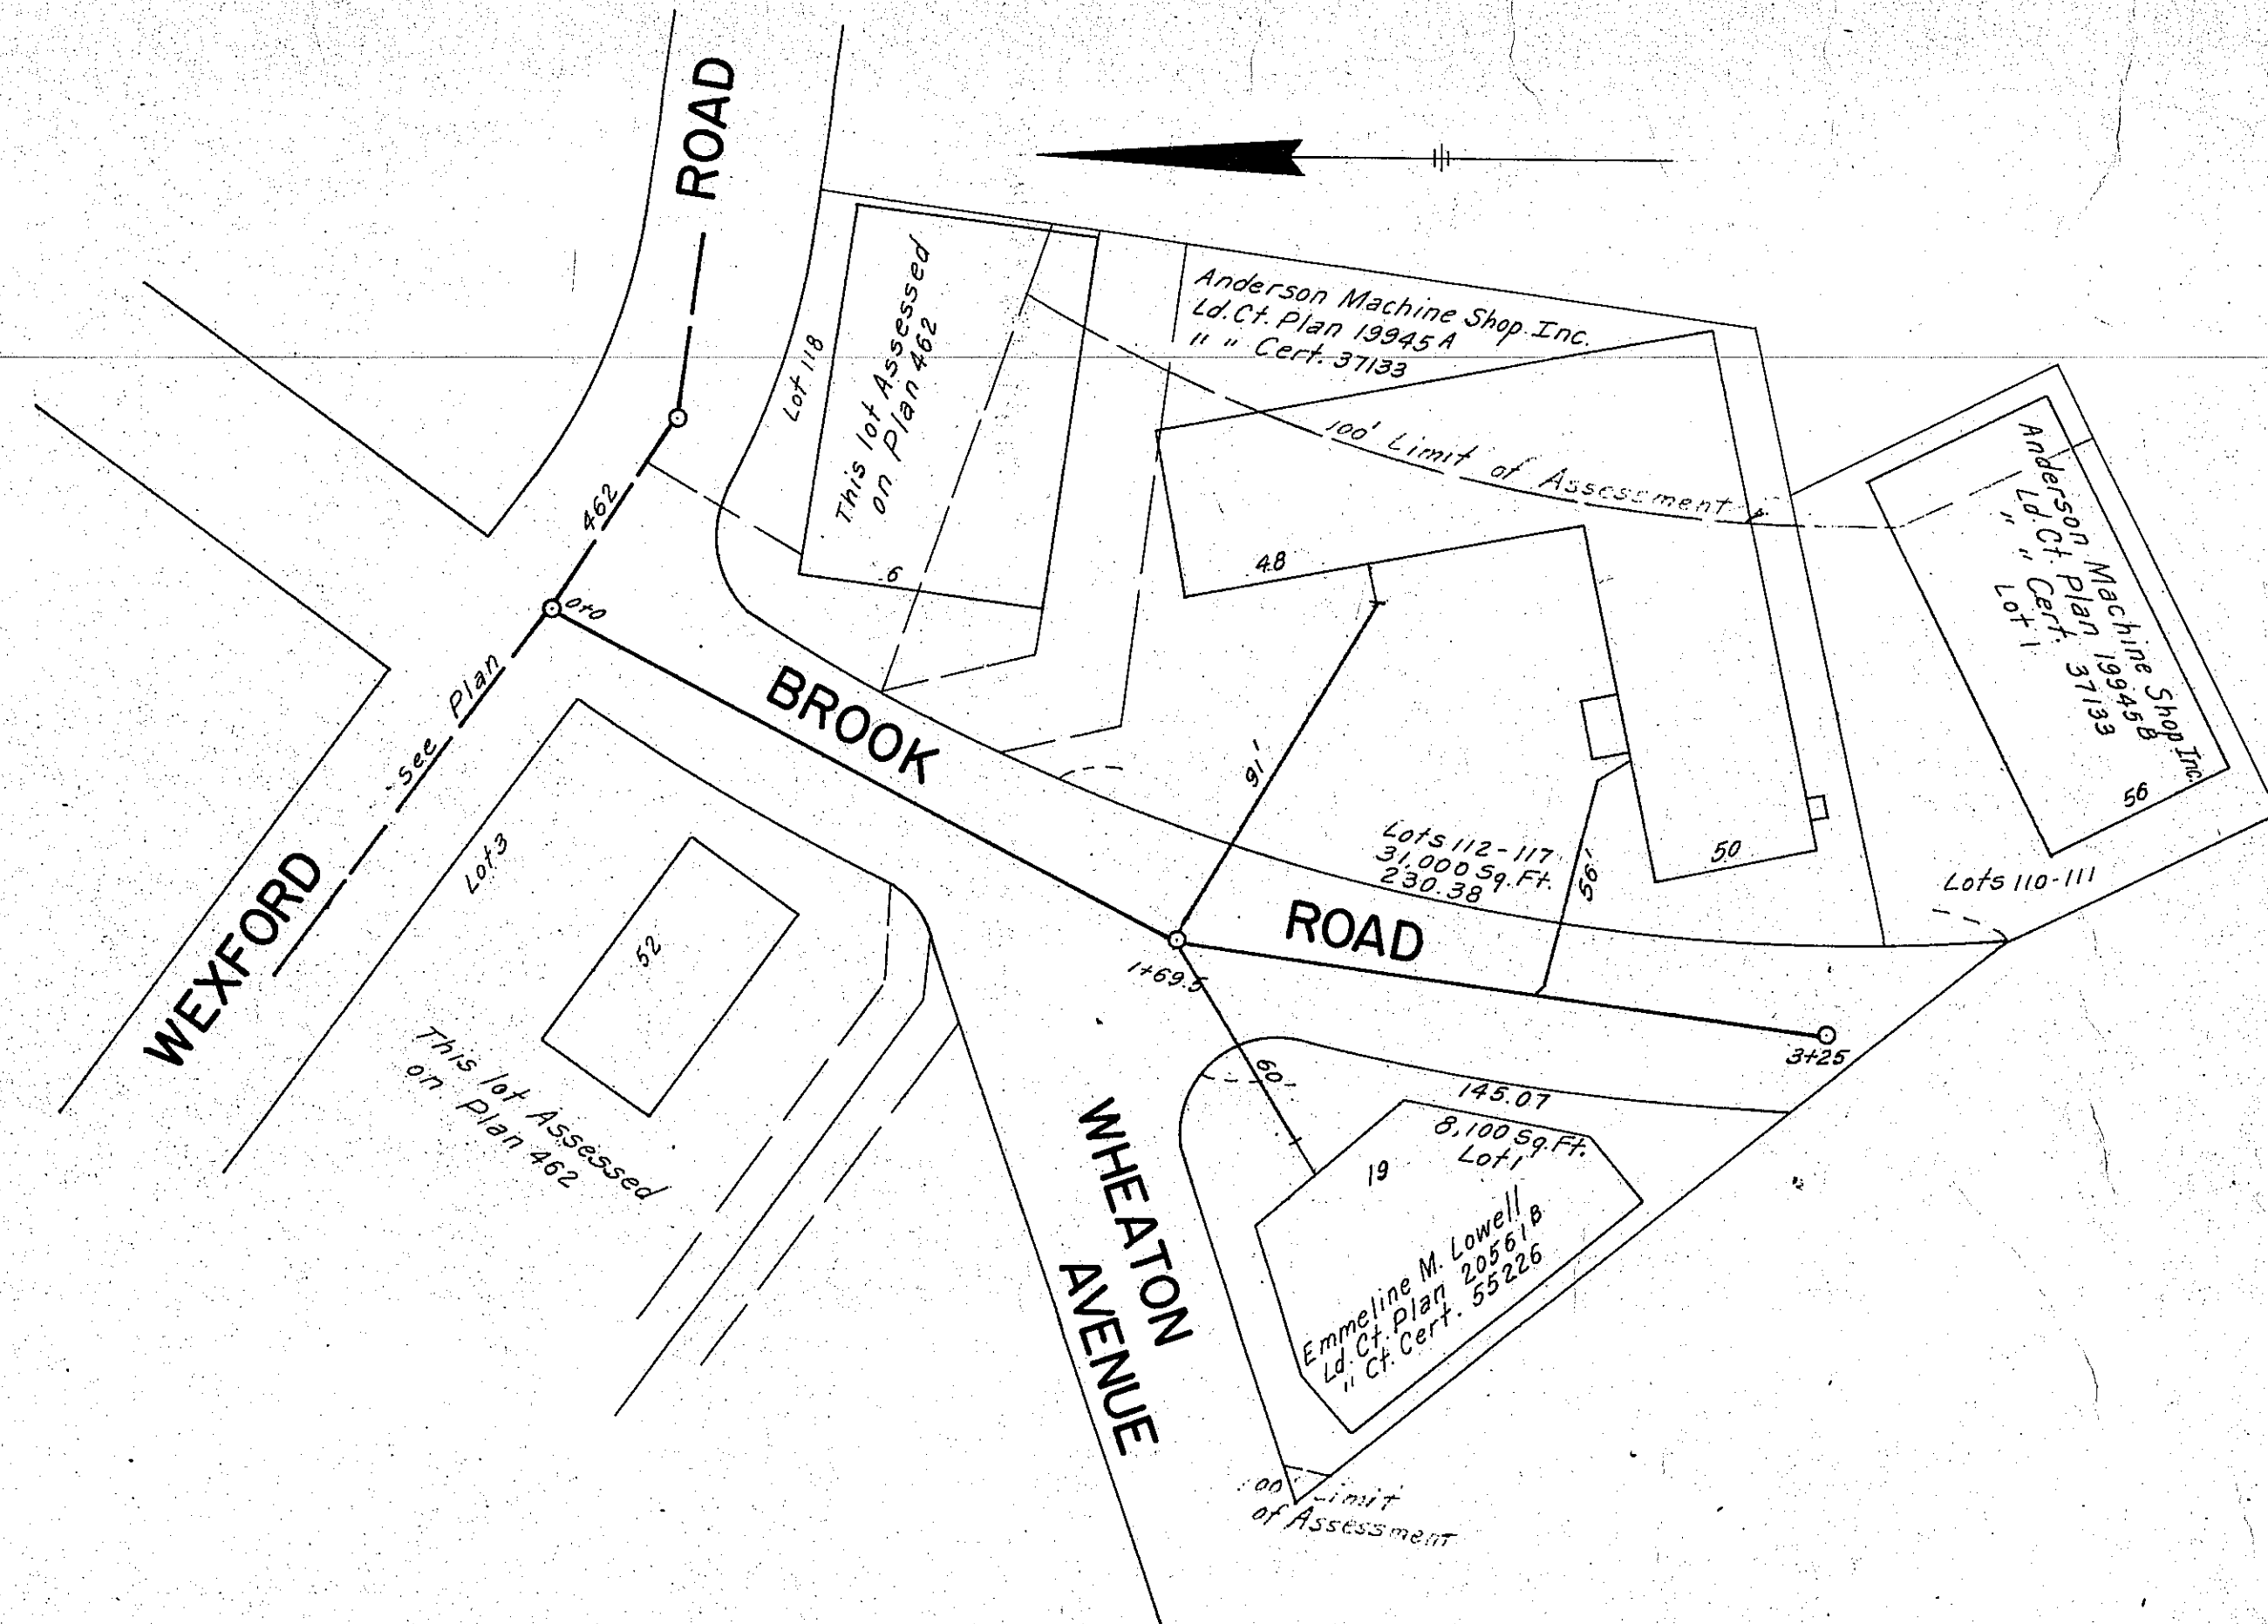



TOWN OF NEEDHAM, MASS.
 BROOK ROAD SEWER
 WEXFORD ST. TO END.
 SOUTH STREET-FOX HILL ROAD SEWER EASEMENT
 STA. 4+56.5 NORTHWESTERLY TO SOUTH ST.

HOR. SCALE: 1 IN. = 40 FT. H. GORDON MARTIN
 VERT. SCALE: 1 IN. = 4 FT. TOWN ENGINEER
 DECEMBER 1967 N.B. 149 Pg. 48
 143. Pg. 6

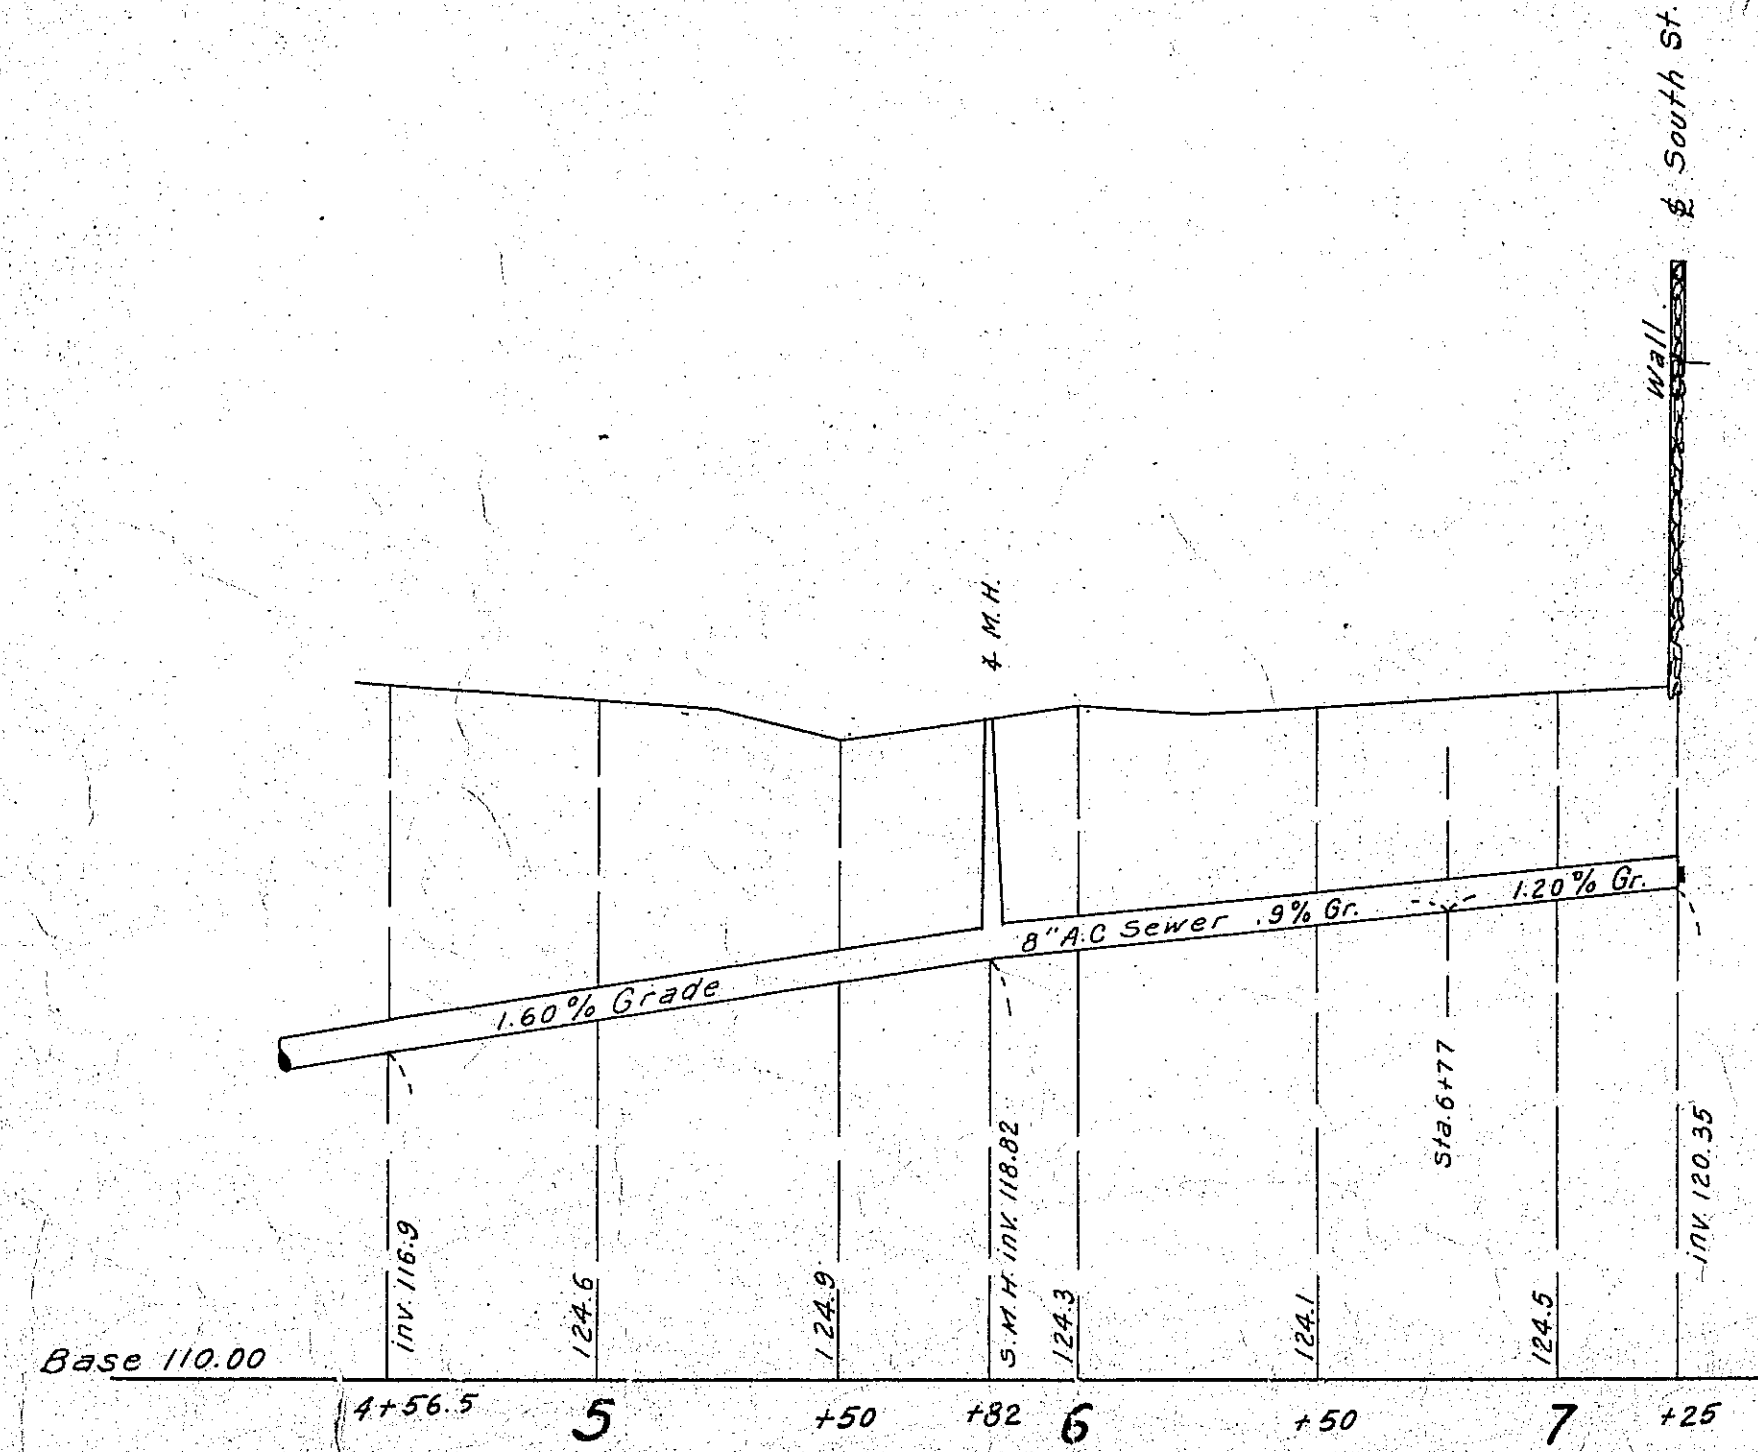
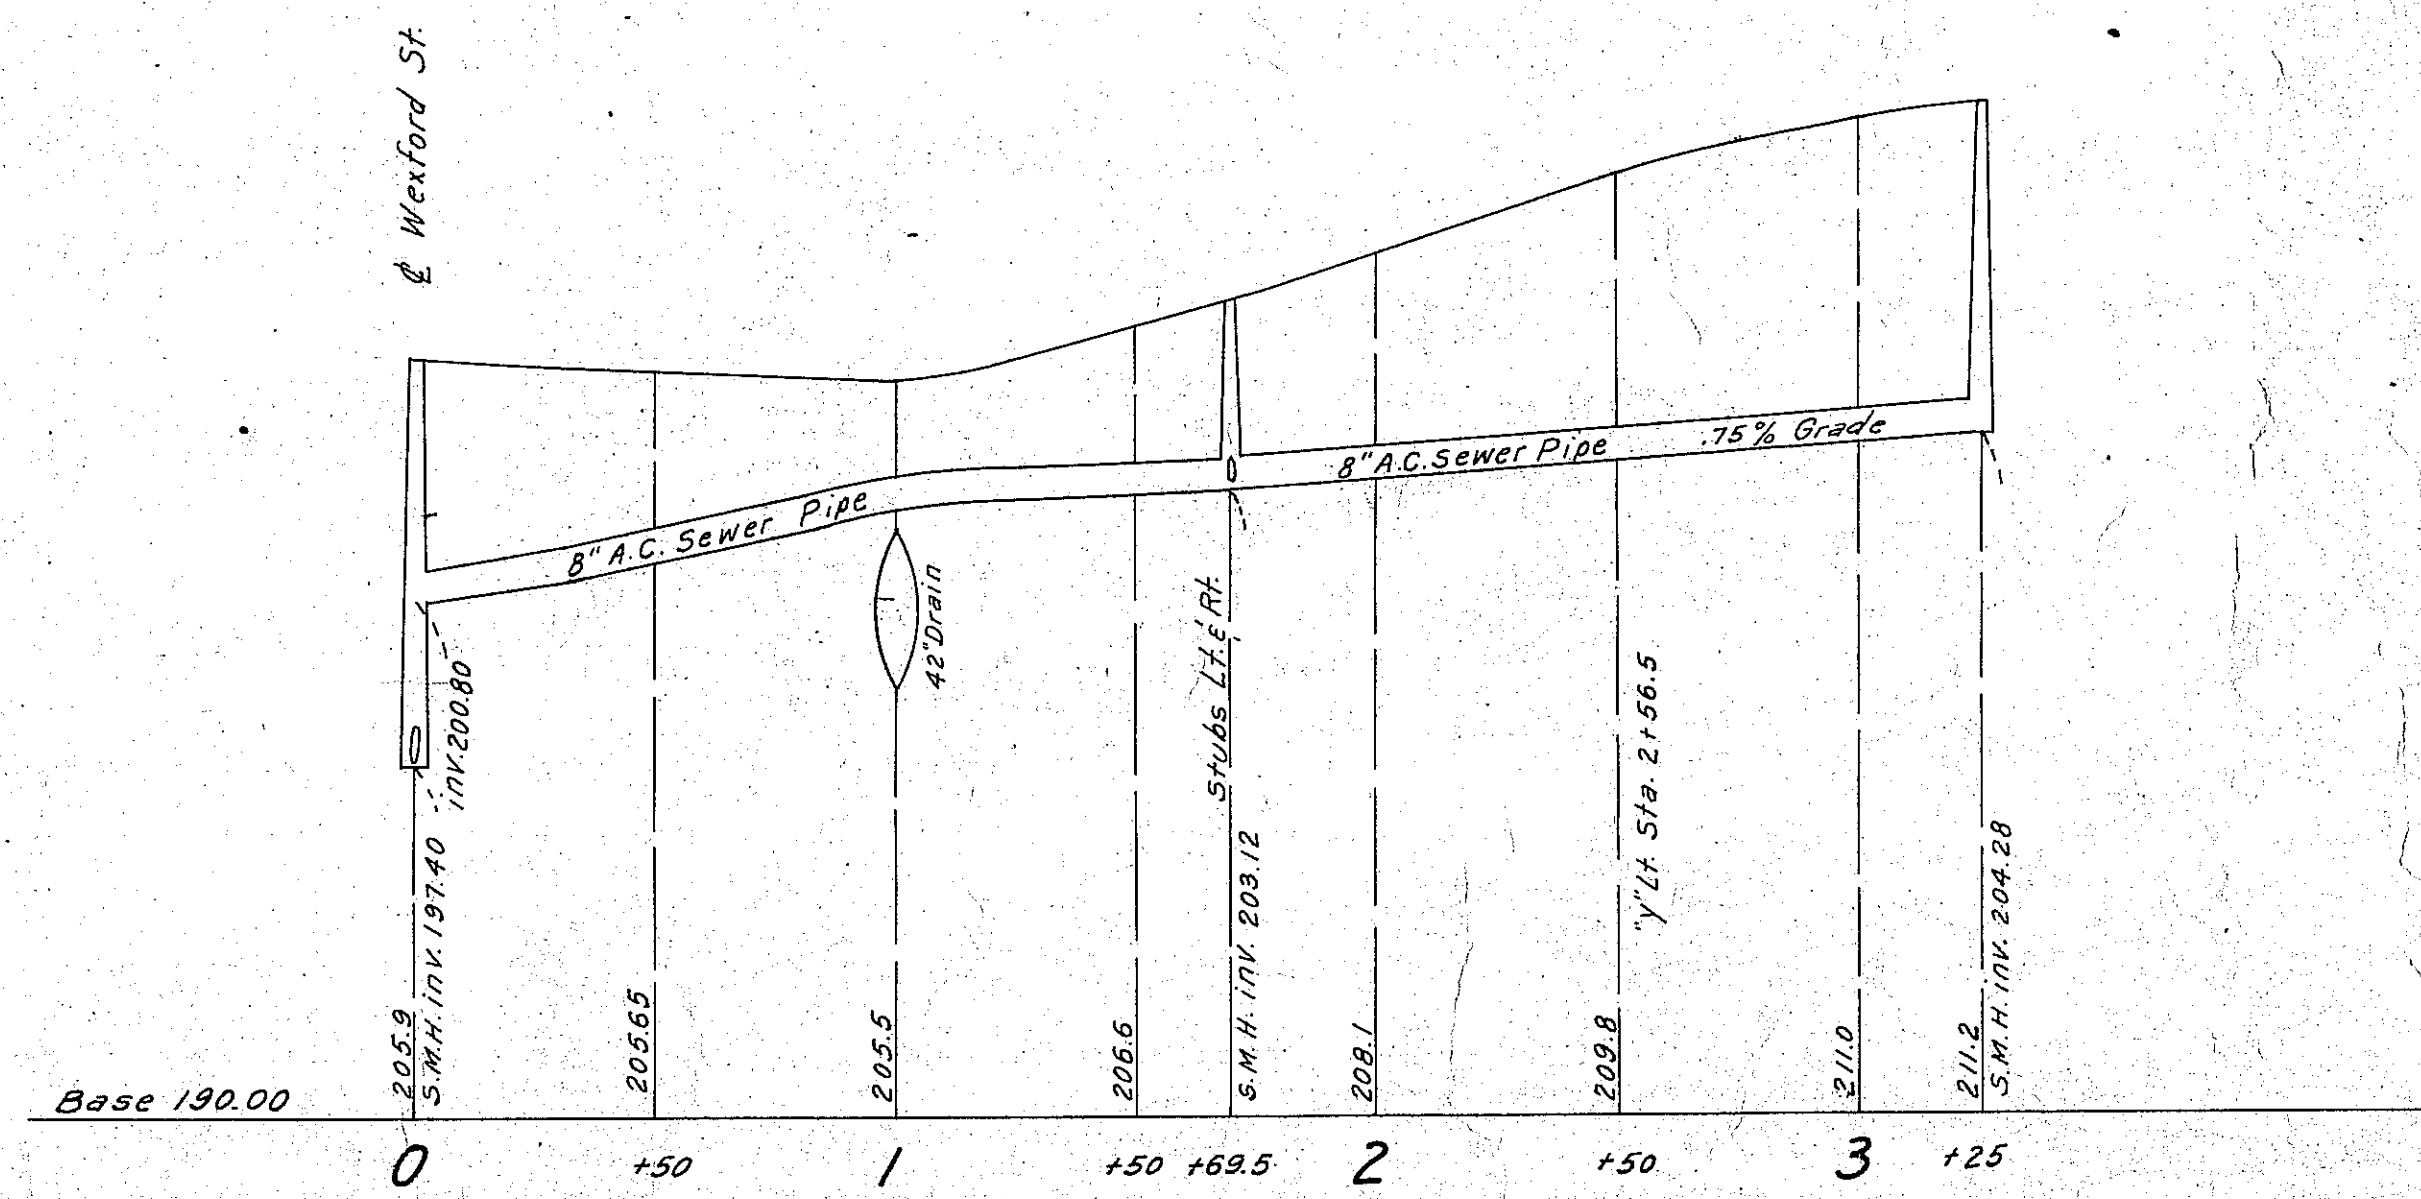
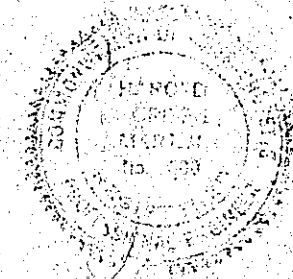
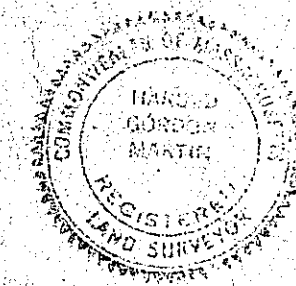


NEEDHAM WATER RECORD DRAWINGS

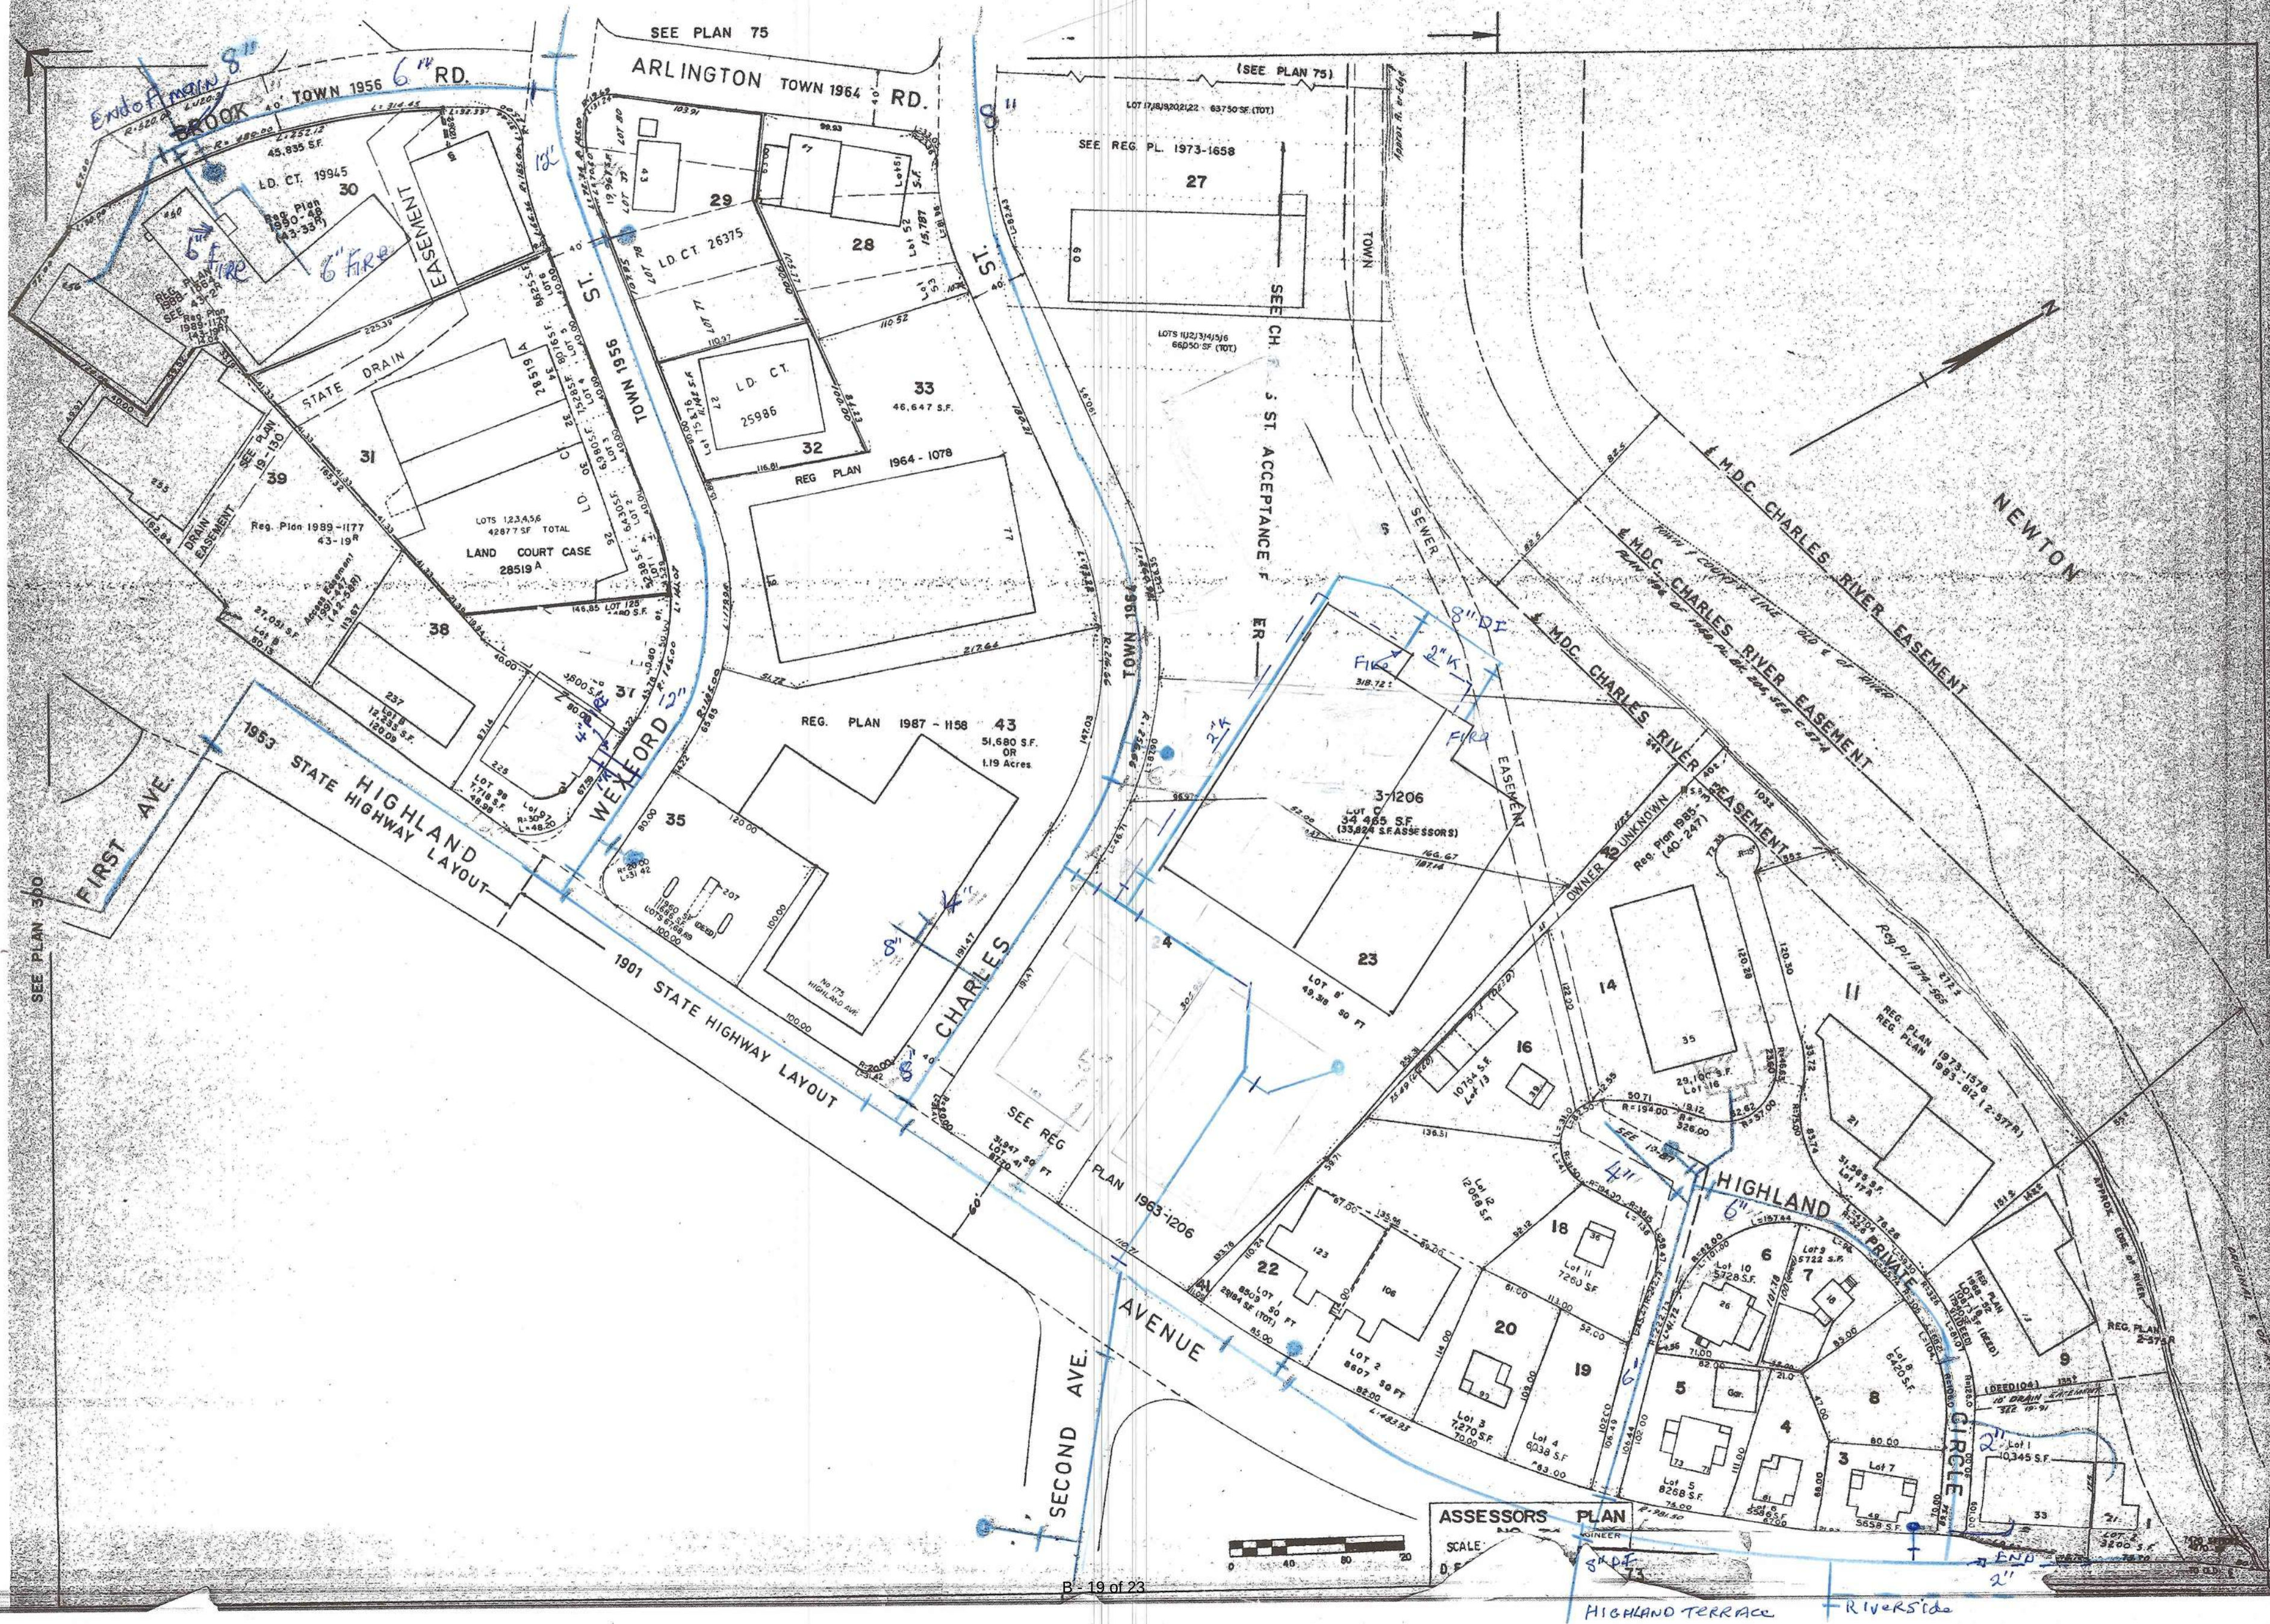

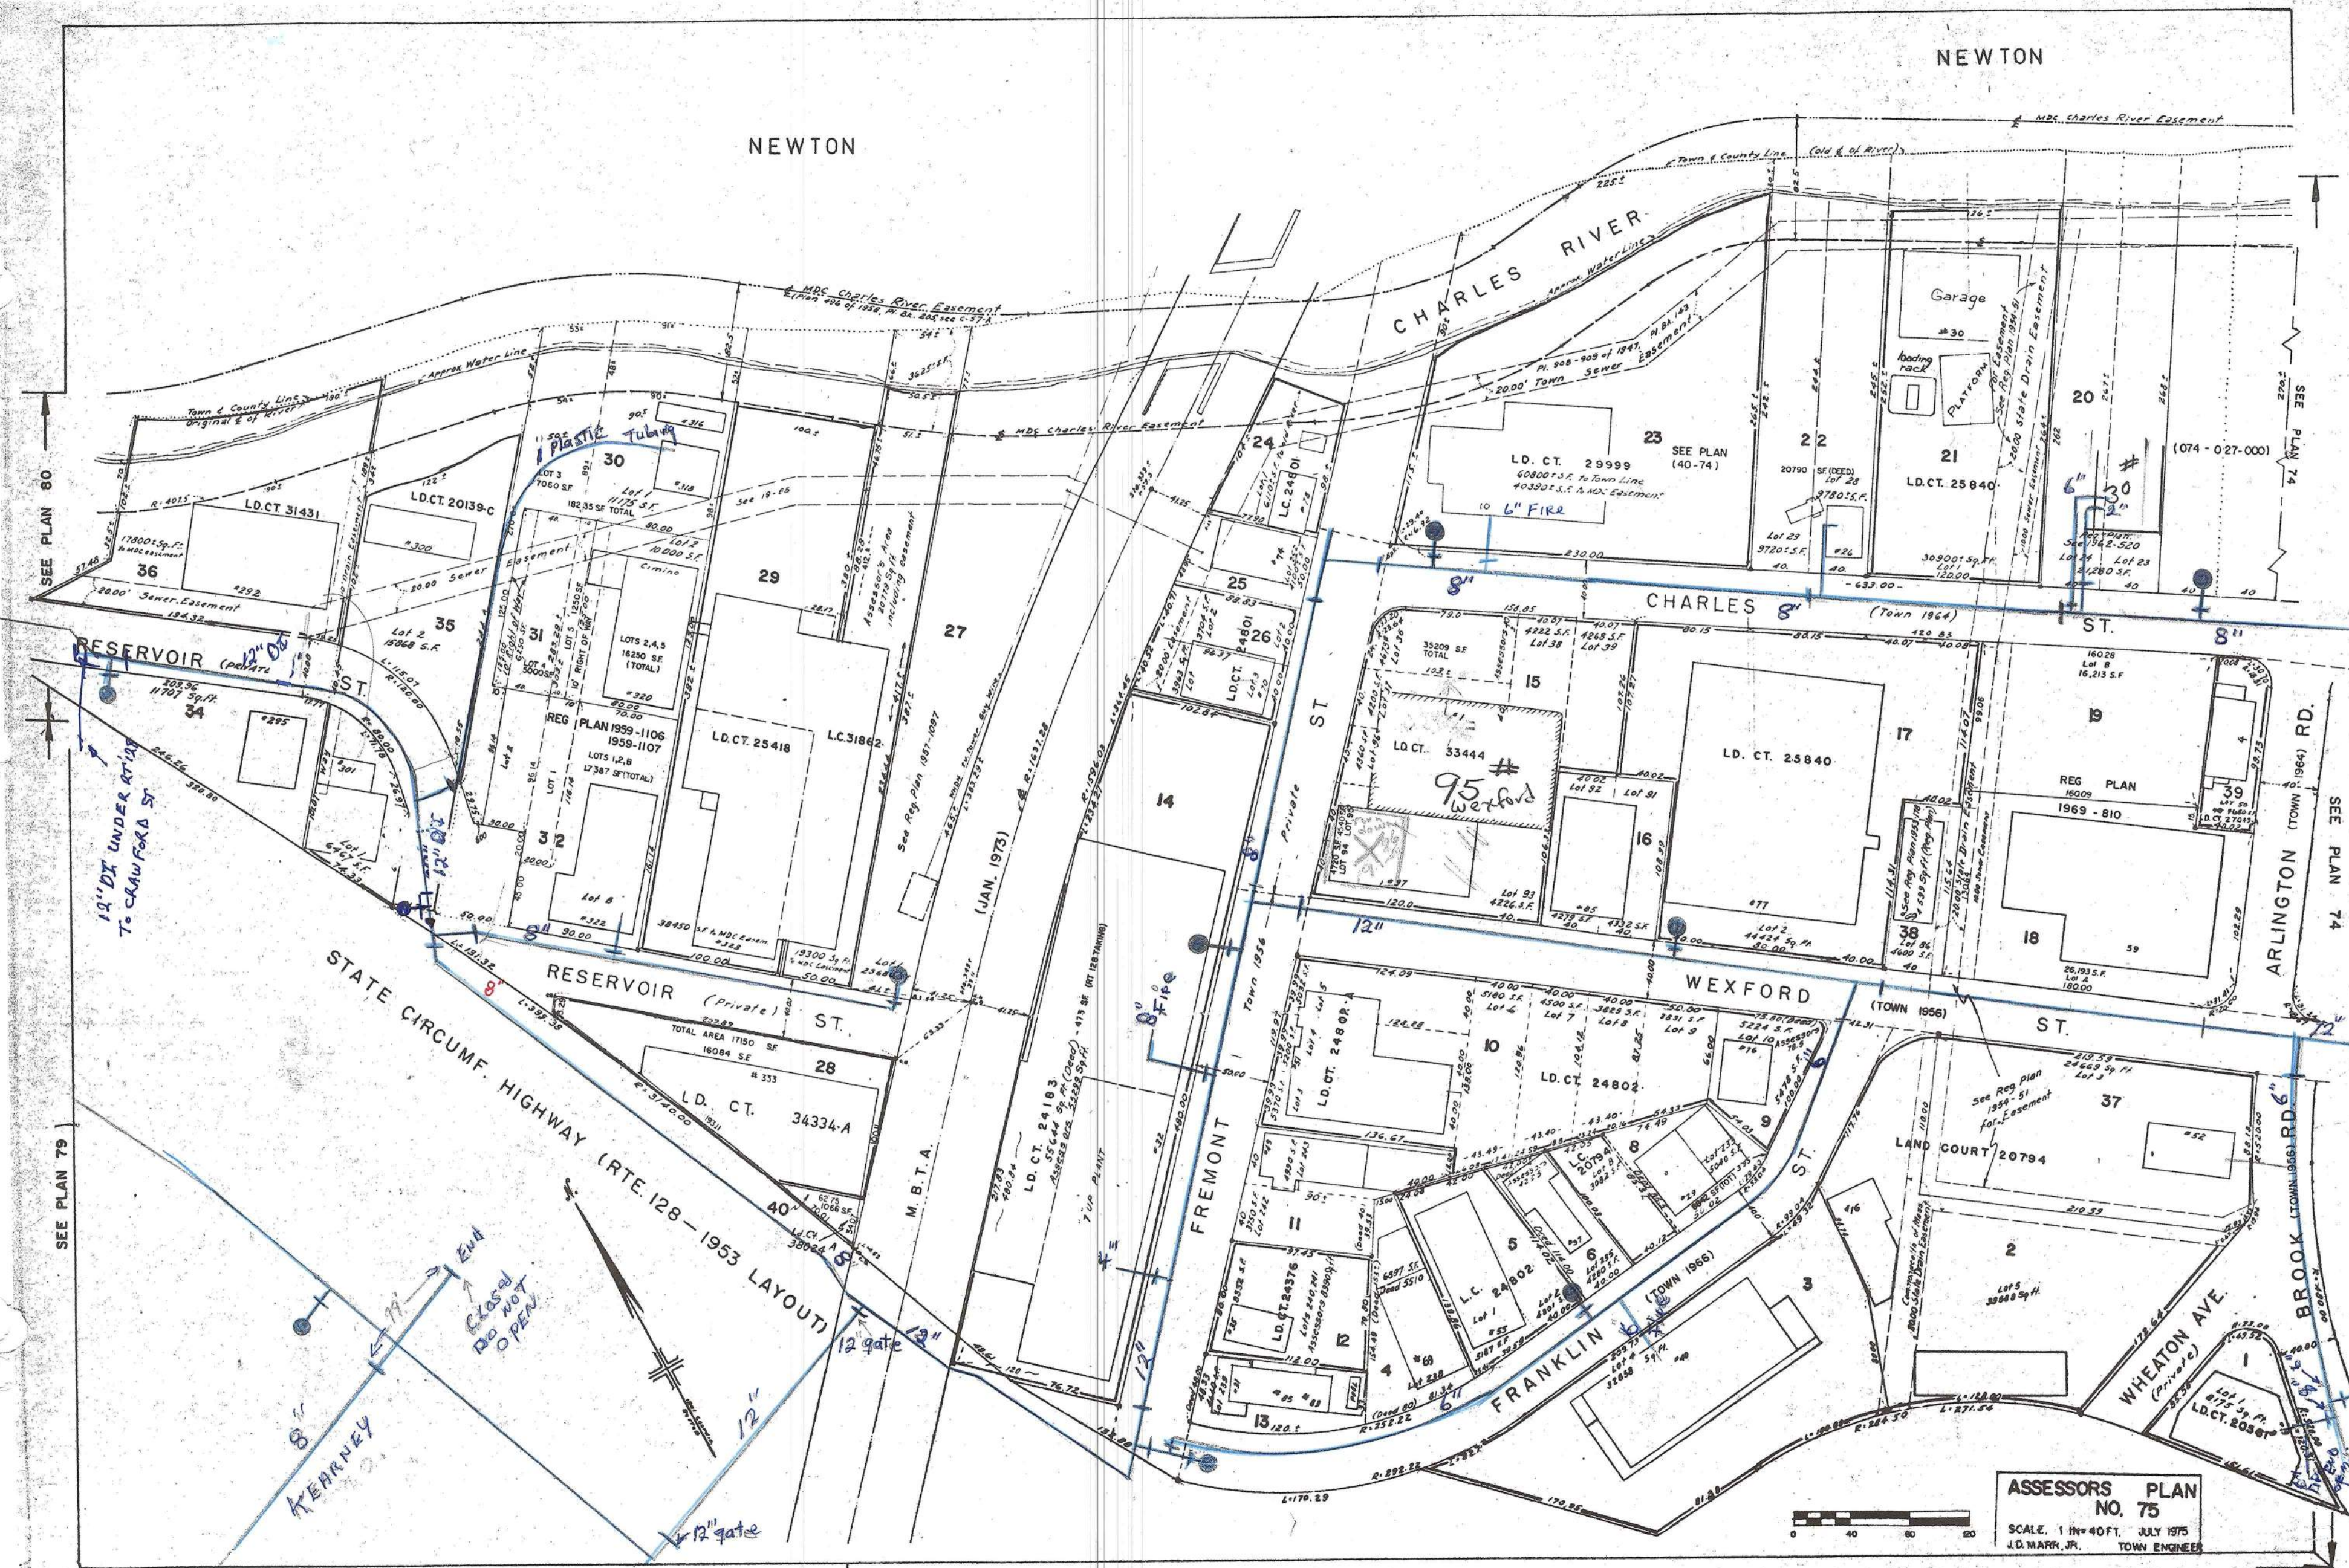

12" VC SEWER REPLACEMENT ~ STA 11+95

    REFERENCE:					CONTRACT NO. : 8086	CAD FILE NO. : 3-3-V-103		 MASSACHUSETTS WATER RESOURCES AUTHORITY	METROPOLITAN WATER TUNNEL PROGRAM CONTRACT PACKAGE 3.3 NEEDHAM DEWATERING DRAINAGE LINE	DRAWING NO. V-103
					ACCESSION NO. : N/A	SECTION NO. :				
					DATE: SEPTEMBER, 2026	DESIGNED BY: N/A				
						DRAWN BY: FV				
						CHECKED BY: GRR				
					SCALE: 1"=20'	APPROVED BY: DL				
	NO.	DATE	BY	CHK'D	REVISION	 			EXISTING CONDITIONS	
								PLAN 3 OF 3	07 of 41	

12" VC SEWER REPLACED WITH 12" PVC ~STA 11+95
- TRENCH DETAILS

